




51EC INC.

31 NORTH TEJON ST, SUITE 304
COLORADO SPRINGS, CO 80903
FIFTYONEEC.COM | 719.368.7394

BENT GRASS MEADOWS DR

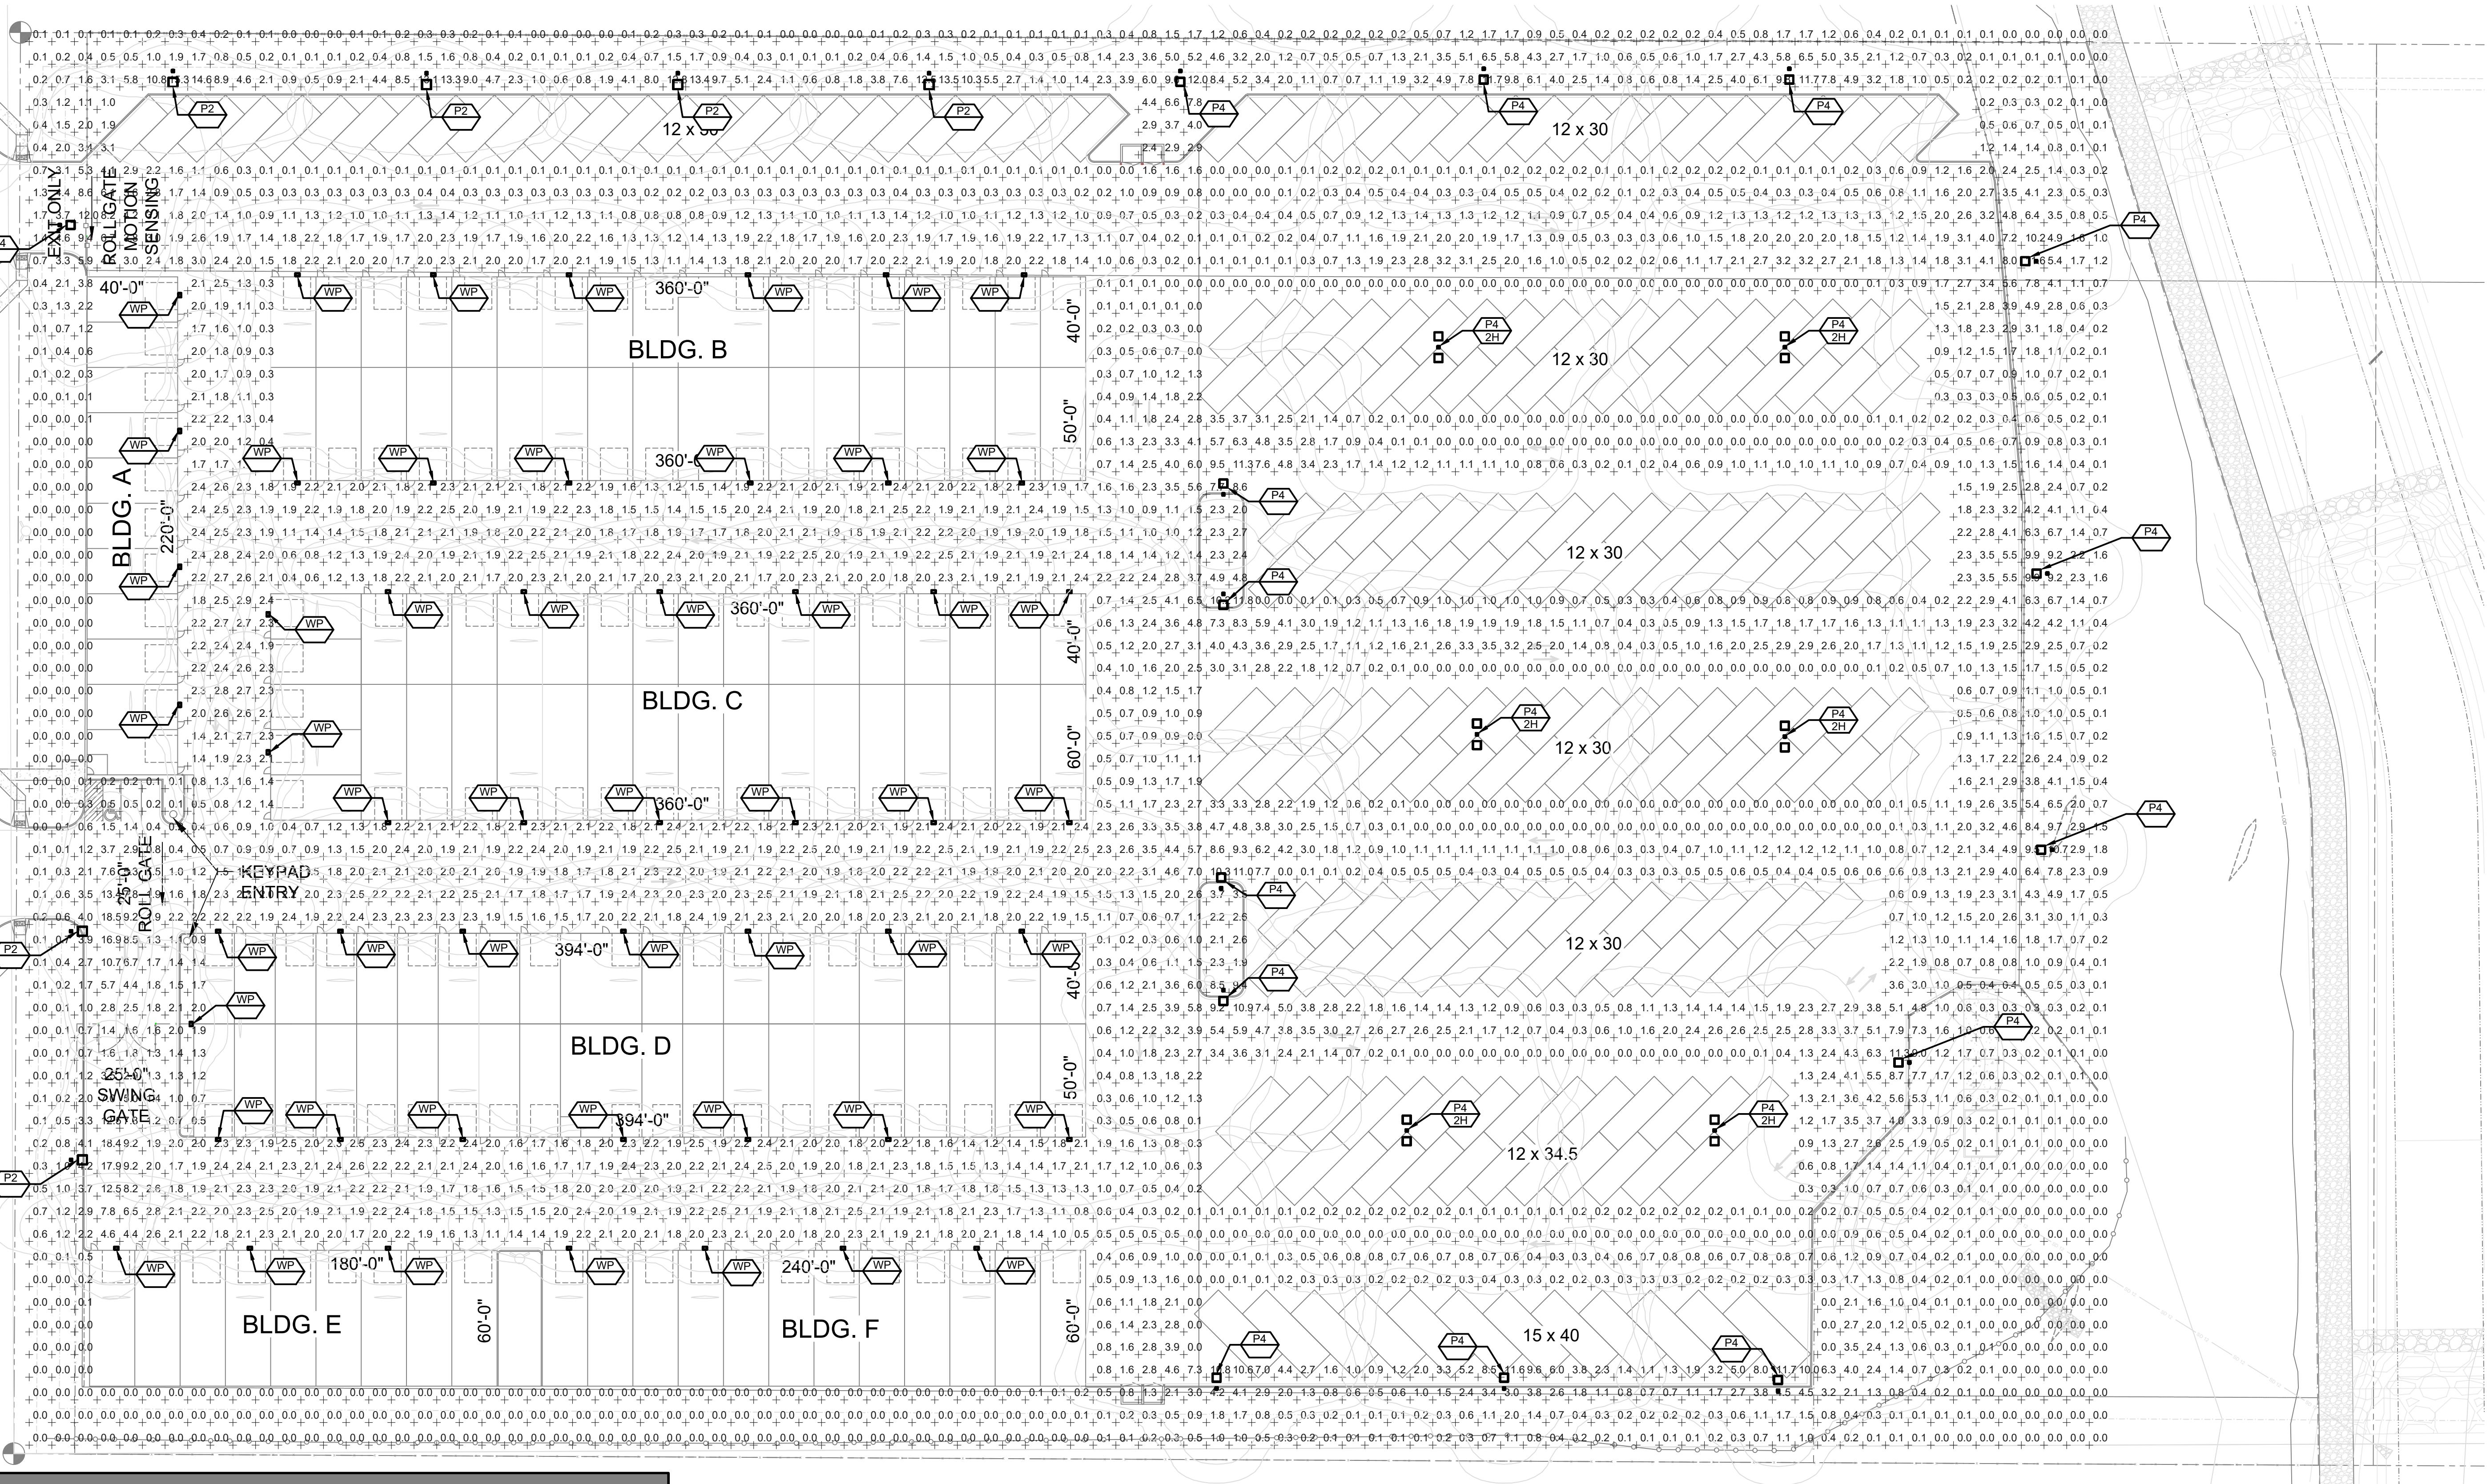

Schedule											
Symbol	Label	Image	Quantity	Manufacturer	Catalog Number	Description	Number Lamps	Lumens Per Lamp	Light Loss Factor	Wattage	Plot
□	WP		52	Lithonia Lighting	WDXE2 LED P4 40K 80CRI T2M	WDXE2 LED W/ P4 - PERFORMANCE PACKAGE, 4000K, 80CRI, TYPE 2 MEDIUM OPTIC	1	4267	0.92	46.6589	
□	P2		6	Lithonia Lighting	RSX2 LED P4 40K R2 HS	RSX LED Area Luminaire Size 2 P4 Lumen Package 4000K CCT Type R2 Distribution with HS shield	1	18970	0.92	189.54	
□	P4		15	Lithonia Lighting	RSX2 LED P4 40K R4	RSX Area Fixture Size 2 P4 Lumen Package 4000K CCT Type R4 Distribution	1	25328	0.92	189.54	
□	P4-2H		6	Lithonia Lighting	RSX2 LED P4 40K R4	RSX Area Fixture Size 2 P4 Lumen Package 4000K CCT Type R4 Distribution	1	25328	0.92	379.08	

SITE PLAN PHOTOMETRICS
SCALE: NTS



-Please depict a north arrow
-Please depict a scale for this map
-Please provide a date for prep of plan
-Please provide a map key so that knowing where the easements are clear to find and see
-Please depict the height of the lights on plan add code section "per section"

Statistics

Description	Symbol	Avg	Max	Min	Max/Min Avg/Min
Site	+	1.5 fc	18.5 fc	0.0 fc	N/A

NEW BUILD
MANCAVE RV STORAGE
BENT GRASS MEADOWS DR.
PEYTON, CO 80831

REV	DESCRIPTION	DRAWN	CHECK	APR	DATE

ISSUANCE:
ISSUED FOR REVIEW

CLIENT:
HAMMERS CONSTRUCTION
1411 WOOLSEY HEIGHTS
COLORADO SPRINGS, CO 80915

ARCHITECT:
HAMMERS CONSTRUCTION
1411 WOOLSEY HEIGHTS
COLORADO SPRINGS, CO 80915

PROJECT NO:
5151-20-01

TITLE:
SITE PLAN
PHOTOMETRICS

SHEET NO:

E-L-001



51EC INC.

31 NORTH TEJON ST, SUITE 304
COLORADO SPRINGS, CO 80903

FIFTYNEEC.COM | 719.368.7394



31 NORTH TEJON ST, SUITE 304
COLORADO SPRINGS, CO 80903

FIFTYNEEC.COM | 719.368.7394

NEW BUILD
MANCAVE RV STORAGE
BENT GRASS MEADOWS DR.
PEYTON, CO 80831

WDGE2 LED
Architectural Wall Sconce
Precision Refractive Optic

Catalog Number: WDGE2 LED P4 40K 80CRI T2M

Notes: QTY: 52

Type: WP

Kit the link or mouse over the page to see all interactive elements.

WDGE2 D03D WDGE2 LED Architectural Wall Sconce (specify field)

WDGE2P03D WDGE2 LED Architectural Wall Sconce (specify field)

Notes: QTY: 52

Type: WP

Kit the link or mouse over the page to see all interactive elements.

Accessories
DLC C-UL Buy American

Notes: QTY: 52

Type: WP

Kit the link or mouse over the page to see all interactive elements.

WDGE2 LED family is designed to meet specifier's every wall mounted lighting need in a widely accepted shape that blends with any architectural. The clean recessed design comes in four sizes with lumen packages ranging from 1,200 to 25,000 lumens, providing a true site-wide solution. Embedded with 18W cold temperature options, including an 18W cold temperature option, the WDGE2 becomes the ideal wall-mounted lighting solution for pedestrian scale applications in any environment.

Introduction
The new WDGE2 family is designed to meet specifier's every wall mounted lighting need in a widely accepted shape that blends with any architectural. The clean recessed design comes in four sizes with lumen packages ranging from 1,200 to 25,000 lumens, providing a true site-wide solution. Embedded with 18W cold temperature options, including an 18W cold temperature option, the WDGE2 becomes the ideal wall-mounted lighting solution for pedestrian scale applications in any environment.

Performance Data
Lumen Output

Lumen values are from photometric tests performed in accordance with IESNA LM-79-08. Data is considered to be representative of the configurations shown, within the tolerances allowed by Lighting Facts. Contact factory for performance data on any configurations not shown here.

RSX2 LED
Area Luminaire

Catalog Number: RSX2 LED P4 40K R2 HS

Notes: QTY: 6

Type: P2

Kit the link or mouse over the page to see all interactive elements.

RSX2 D03D RSX2 LED P4 40K R2 HS

Notes: QTY: 6

Type: P2

Kit the link or mouse over the page to see all interactive elements.

Performance Data
Lumen Output

Lumen values are from photometric tests performed in accordance with IESNA LM-79-08. Data is considered to be representative of the configurations shown, within the tolerances allowed by Lighting Facts. Contact factory for performance data on any configurations not shown here.

Specifications
EPA (ft²@0°): 0.69 ft² (0.06 m²)

Length: 29.3" (74.4 cm) (SPA mount)

Width: 13.4" (34.0 cm)

Height: 3.0" (7.6 cm) Main Body
7.2" (18.3 cm) Arm

Weight: (SPA mount) 30.0 lbs (13.6 kg)

Performance Data
Lumen Output

Lumen values are from photometric tests performed in accordance with IESNA LM-79-08. Data is considered to be representative of the configurations shown, within the tolerances allowed by Lighting Facts. Contact factory for performance data on any configurations not shown here.

Performance Data
Lumen Output

Lumen values are from photometric tests performed in accordance with IESNA LM-79-08. Data is considered to be representative of the configurations shown, within the tolerances allowed by Lighting Facts. Contact factory for performance data on any configurations not shown here.

Specifications
Depth (D1): 7"
Depth (D2): 1.5"
Height: 9"
Width: 11.5"
Weight: (without options) 13.5 lbs

WDGE2 LED Family Overview

Luminaire Type Standard EM, FPC Cold Em, 20°C Sensor Approximate Lumens (4000K, 2000)

Luminaire	Optics	Standard EM, FPC	Cold Em, 20°C	Sensor	P1	P2	P3	P4	P5	P6
WDGE1 LED	Visual Comfort	4W	—	—	750	1,200	2,000	—	—	—
WDGE2 LED	Visual Comfort	10W	Standalone, R/Wlight	—	1,200	2,000	3,000	4,500	6,000	—
WDGE2 LED	Precision-Reflective	10W	Standalone, R/Wlight	700	1,200	2,000	3,200	4,200	—	—
WDGE3 LED	Precision-Reflective	15W	Standalone, R/Wlight	—	7,500	8,500	10,000	12,000	—	—
WDGE4 LED	Precision-Reflective	—	Standalone, R/Wlight	—	12,000	16,000	18,000	20,000	22,000	25,000

Ordering Information

EXAMPLE: WDGE2 LED P3 40K 80CRI VF MVOLT SPA DDBXD

Series Package Color Temperature CX Distribution Voltage Mounting

WDGE2 LED P01 27K 27000 27K^{b1} T15 Type 1 Short 34^{b1} 48^{b1} Shipped included SRM Surface mounting bracket ICW Indirect Canopy/Ceiling Mounting Options (damp location only!)

P02 40K 30000 1W/Limited TSM Type 1 Medium 48^{b1} Shipped separately AWS 3.0inch Architectural wall spacer PBWB 5 surface mounted back box top, left, right conduit entry. Use when there is no junction box available.

P03 50K 50000 TFM Forward Throw Medium

PE^{b1} AMB Amber

Options

Finish:

E10WH Emergency battery backup, Certified in CA Title 20 MAERS

E20WC Emergency battery backup, Certified in CA Title 20 MAERS

PE^{b1} Photocell, Button Type

DAC^{b1} 0-10V dimming wires pulled outside fixture (for use with networked controls, control separate)

BCE Bottom contact entry for back box (PBWB). Total of 4 entry points.

BAA Buy America(A) Act Compliant

See page 4 for full functionality.

LITHONIA LIGHTING COMMERCIAL OUTDOOR One Lithonia Way • Conyers, Georgia 30012 • Phone: 1-800-705-SERV (7378) • www.lithonia.com

© 2019-2022 Acuity Brands Lighting, Inc. All rights reserved.

WDGE2 LED Rev. 03/01/22

WDGE2 LED

Commercial Outdoor

One Lithonia Way • Conyers, Georgia 30012 • Phone: 1-800-705-SERV (7378) • www.lithonia.com

© 2019-2022 Acuity Brands Lighting, Inc. All rights reserved.

WDGE2 LED Rev. 03/01/22

WDGE2 LED

Commercial Outdoor

One Lithonia Way • Conyers, Georgia 30012 • Phone: 1-800-705-SERV (7378) • www.lithonia.com

© 2019-2022 Acuity Brands Lighting, Inc. All rights reserved.

WDGE2 LED Rev. 03/01/22

WDGE2 LED

Commercial Outdoor

One Lithonia Way • Conyers, Georgia 30012 • Phone: 1-800-705-SERV (7378) • www.lithonia.com

© 2019-2022 Acuity Brands Lighting, Inc. All rights reserved.

WDGE2 LED Rev. 03/01/22

WDGE2 LED

Commercial Outdoor

One Lithonia Way • Conyers, Georgia 30012 • Phone: 1-800-705-SERV (7378) • www.lithonia.com

© 2019-2022 Acuity Brands Lighting, Inc. All rights reserved.

WDGE2 LED Rev. 03/01/22

WDGE2 LED

Commercial Outdoor

One Lithonia Way • Conyers, Georgia 30012 • Phone: 1-800-705-SERV (7378) • www.lithonia.com

© 2019-2022 Acuity Brands Lighting, Inc. All rights reserved.

WDGE2 LED Rev. 03/01/22

WDGE2 LED

Commercial Outdoor

One Lithonia Way • Conyers, Georgia 30012 • Phone: 1-800-705-SERV (7378) • www.lithonia.com

© 2019-2022 Acuity Brands Lighting, Inc. All rights reserved.

WDGE2 LED Rev. 03/01/22

WDGE2 LED

Commercial Outdoor

One Lithonia Way • Conyers, Georgia 30012 • Phone: 1-800-705-SERV (7378) • www.lithonia.com

© 2019-2022 Acuity Brands Lighting, Inc. All rights reserved.

WDGE2 LED Rev. 03/01/22

WDGE2 LED

Commercial Outdoor

One Lithonia Way • Conyers, Georgia 30012 • Phone: 1-800-705-SERV (7378) • www.lithonia.com

© 2019-2022 Acuity Brands Lighting, Inc. All rights reserved.

WDGE2 LED Rev. 03/01/22

WDGE2 LED

Commercial Outdoor

One Lithonia Way • Conyers, Georgia 30012 • Phone: 1-800-705-SERV (7378) • www.lithonia.com

© 2019-2022 Acuity Brands Lighting, Inc. All rights reserved.

WDGE2 LED Rev. 03/01/22

WDGE2 LED

Commercial Outdoor

One Lithonia Way • Conyers, Georgia 30012 • Phone: 1-800-705-SERV (7378) • www.lithonia.com

© 2019-2022 Acuity Brands Lighting, Inc. All rights reserved.

WDGE2 LED Rev. 03/01/22

WDGE2 LED

Commercial Outdoor

One Lithonia Way • Conyers, Georgia 30012 • Phone: 1-800-705-SERV (7378) • www.lithonia.com

© 2019-2022 Acuity Brands Lighting, Inc. All rights reserved.

WDGE2 LED Rev. 03/01/22

WDGE2 LED

Commercial Outdoor

One Lithonia Way • Conyers, Georgia 30012 • Phone: 1-800-705-SERV (7378) • www.lithonia.com

© 2019-2022 Acuity Brands Lighting, Inc. All rights reserved.

WDGE2 LED Rev. 03/01/22

WDGE2 LED

Commercial Outdoor

One Lithonia Way • Conyers, Georgia 30012 • Phone: 1-800-705-SERV (7378) • www.lithonia.com

© 2019-2022 Acuity Brands Lighting, Inc. All rights reserved.

WDGE2 LED Rev. 03/01/22

WDGE2 LED

Commercial Outdoor

One Lithonia Way • Conyers, Georgia 30012 • Phone: 1-800-705-SERV (7378) • www.lithonia.com

© 2019-2022 Acuity Brands Lighting, Inc. All rights reserved.

WDGE2 LED Rev. 03/01/22

WDGE2 LED

Commercial Outdoor

One Lithonia Way • Conyers, Georgia 30012 • Phone: 1-800-705-SERV (7378) • www.lithonia.com

© 2019-2022 Acuity Brands Lighting, Inc. All rights reserved.

WDGE2 LED Rev. 03/01/22

WDGE2 LED

Commercial Outdoor

One Lithonia Way • Conyers, Georgia 30012 • Phone: 1-800-705-SERV (7378) • www.lithonia.com

© 2019-2022 Acuity Brands Lighting, Inc. All rights reserved.

WDGE2 LED Rev. 03/01/22

WDGE2 LED

Commercial Outdoor

One Lithonia Way • Conyers, Georgia 30012 • Phone: 1-800-705-SERV (7378) • www.lithonia.com

© 2019-2022 Acuity Brands Lighting, Inc. All rights reserved.

WDGE2 LED Rev. 03/01/22

WDGE2 LED

Commercial Outdoor

One Lithonia Way • Conyers, Georgia 30012 • Phone: 1-800-705-SERV (7378) • www.lithonia.com

© 2019-2022 Acuity Brands Lighting, Inc. All rights reserved.

WDGE2 LED Rev. 03/01/22

WDGE2 LED

Commercial Outdoor

<div data-bbox="1055 435 1065 45