


LEGEND


	PROPOSED FULL DEPTH ASPHALT
	EXISTING RIGHT OF WAY
	EXISTING PROPERTY LINE
	EXISTING CENTERLINE
	EXISTING FENCE
	EXISTING GAS LINE
	EXISTING STORM DRAIN
	EXISTING TELEPHONE LINE
	PROPOSED STORM DRAIN

NOTE
 EXISTING UTILITIES SHOWN BASE UPON ABOVE GROUND EVIDENCE AND FLAGGING. CONTRACTOR TO VERIFY EXISTING UTILITY LAYOUT WITH POTHOLE AND UTILITY LOCATES PRIOR TO CONSTRUCTION ACTIVITIES.


**INTERIM CULVERT 1 PROFILE
 STA 1+00.00 TO 1+63.59**

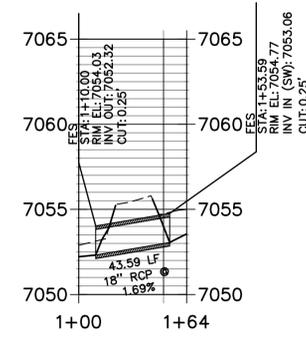

**INTERIM CULVERT 2 PROFILE
 STA 1+00.00 TO 1+65.28**

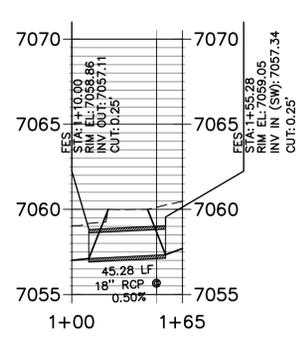

**INTERIM CULVERT 3 PROFILE
 STA 1+00.00 TO 1+67.54**

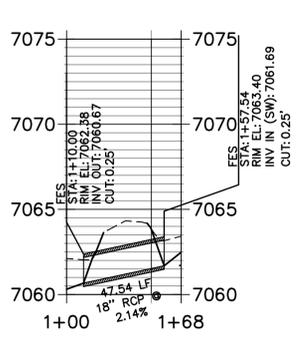

**WARNING
 HIGH-PRESSURE PIPELINE(S)**
 EXCAVATION AND/OR CONSTRUCTION PROHIBITED WITHOUT COMPLIANCE WITH STATE ONE-CALL, AND WITHOUT WRITTEN PERMISSION FROM
 MAGELLAN PIPELINE COMPANY, L.P.



ENGINEER'S STATEMENT
 PREPARED UNDER MY DIRECT SUPERVISION AND ON BEHALF OF JR ENGINEERING
 Mike A. Bramlett, P.E.
 COLORADO P.E. 32314
 FOR AND ON BEHALF OF JR ENGINEERING, INC. LOCAL ENGINEER
 DATE: 07/17/23

UNTIL SUCH TIME AS THESE DRAWINGS ARE APPROVED BY THE APPROPRIATE REVIEWING AGENCIES, JR ENGINEERING APPROVES THEIR USES DESIGNATED BY WRITTEN AUTHORIZATION.

PREPARED FOR
SR LAND, LLC
 20 BOULDER CRESCENT SUITE 201
 COLORADO SPRINGS, CO 80903
 JAMES F. MORLEY (719) 471-1742

J.R. ENGINEERING
 A Westman Company
 Centennial 303-740-9888 • Colorado Springs 719-589-2593
 Fort Collins 970-491-9888 • www.jrengineering.com


BY	DATE	REVISION

H-SCALE: 1"=50'
 V-SCALE: 1"=5'
 DATE: 07/17/23
 DESIGNED BY: CWC
 DRAWN BY: D/JG
 CHECKED BY:

VOLLMER ROAD (BARBARICK) - INTERIM CONDITION
PLAN VIEW

SHEET 3 OF 6
 JOB NO. 25188.01











X:\25188\01\Drawings\Sheet\Drawings\Vollmer Road\Barbarick Interim\Plan View\Vollmer Road\Barbarick Interim\Plan View\01.dwg, PlotD1, 01/18/2023 3:08:37 PM, JRE Remote

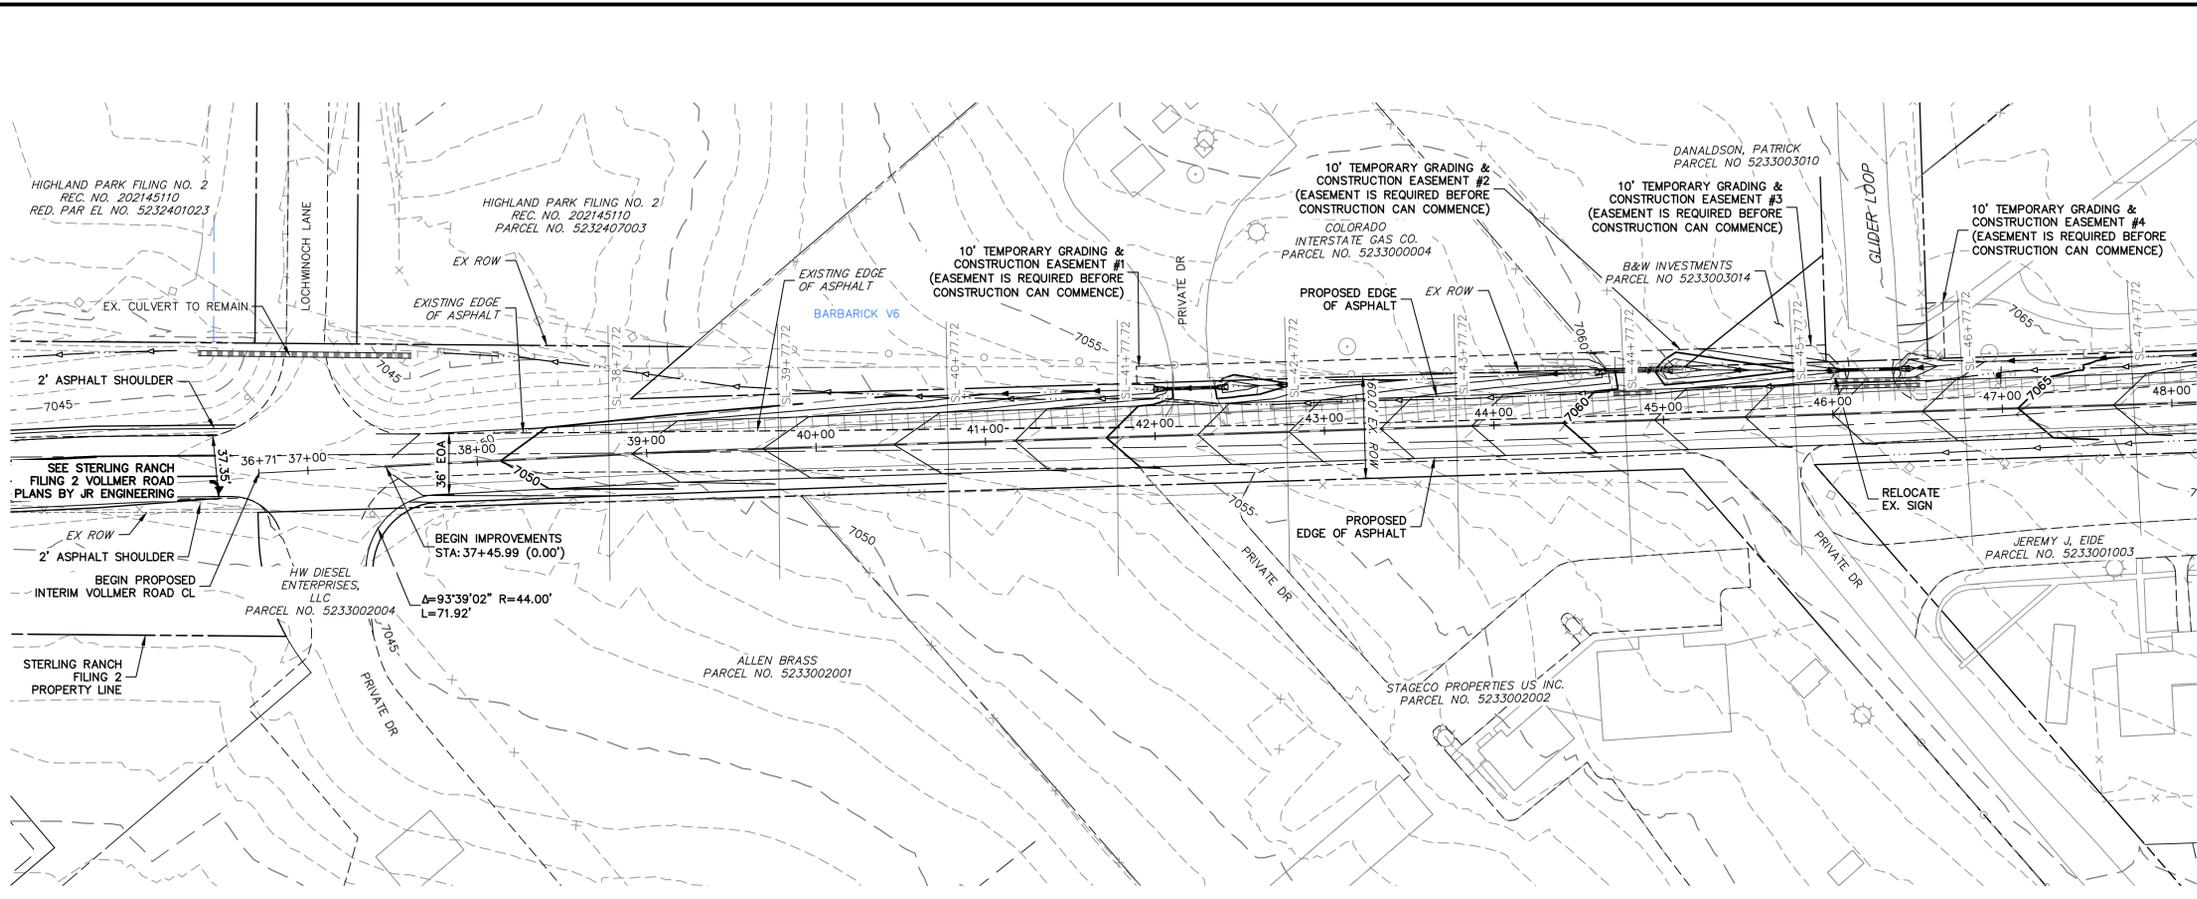


SEE SHEET 5

- LEGEND**
- PROPOSED FULL DEPTH ASPHALT
 - EXISTING RIGHT OF WAY
 - EXISTING PROPERTY LINE
 - EXISTING CENTERLINE
 - EXISTING FENCE
 - EXISTING GAS LINE
 - EXISTING STORM DRAIN
 - EXISTING TELEPHONE LINE
 - PROPOSED STORM DRAIN
 - EXISTING INDEX CONTOUR
 - EXISTING TELEPHONE LINE
 - PROPOSED INDEX CONTOUR
 - PROPOSED MINOR CONTOUR

NOTE
EXISTING UTILITIES SHOWN BASE UPON ABOVE GROUND EVIDENCE AND FLAGGING. CONTRACTOR TO VERIFY EXISTING UTILITY LAYOUT WITH POT HOLE AND UTILITY LOCATES PRIOR TO CONSTRUCTION ACTIVITIES.

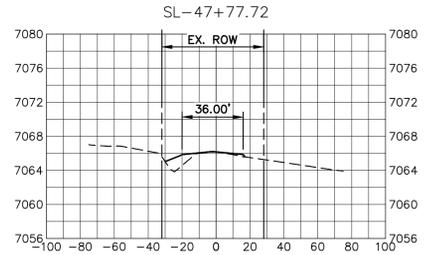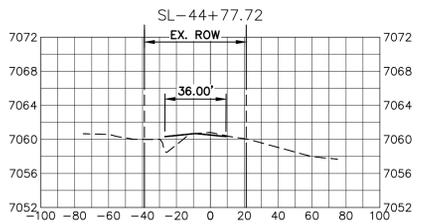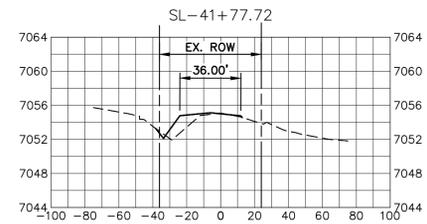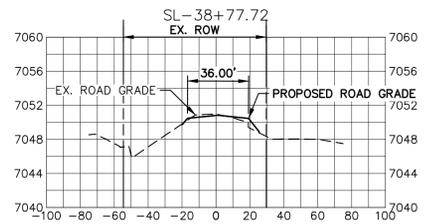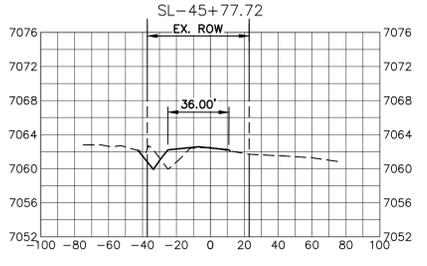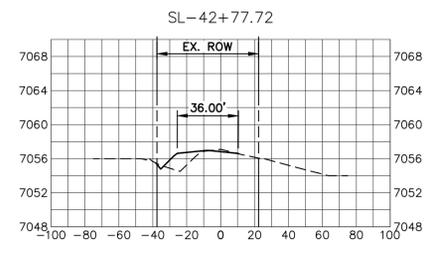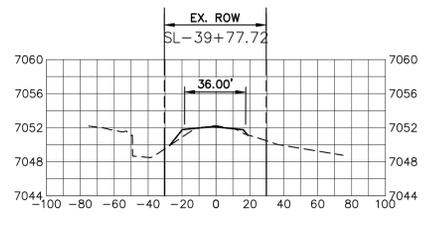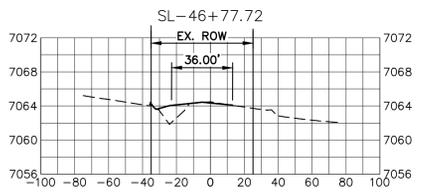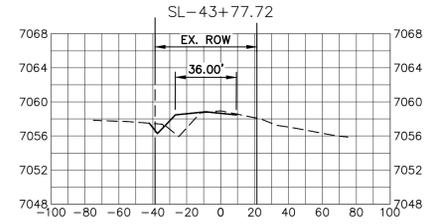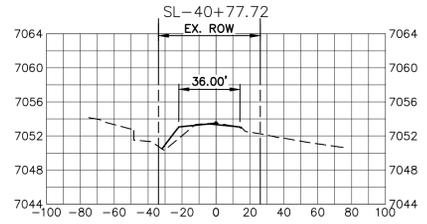

VOLLMER ROAD - INTERIM CONDITION
STA 38+77.72 TO 47+77.72

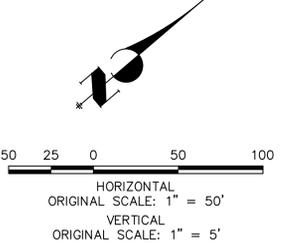

UNTIL SUCH TIME AS THESE DRAWINGS ARE APPROVED BY THE APPROPRIATE REVIEWING AGENCIES, JR ENGINEERING APPROVES THEIR USE. ANY CHANGES DESIGNATED BY WRITTEN AUTHORIZATION.


PREPARED FOR
SR LAND, LLC
20 BOULDER CRESCENT
SUITE 201
COLORADO SPRINGS, CO 80903
JAMES F. MORLEY
(719) 471-1742

J.R. ENGINEERING
A Westman Company
Central 303-740-9888 • Colorado Springs 719-583-2583
Fort Collins 970-491-9888 • www.jrengineering.com



NO.	REVISION	BY	DATE

H-SCALE	1"=50'
V-SCALE	1"=5'
DATE	07/17/23
DESIGNED BY	CWC
DRAWN BY	DUG
CHECKED BY	

VOLLMER ROAD (BARBARICK) - INTERIM CONDITION
CROSS SECTIONS

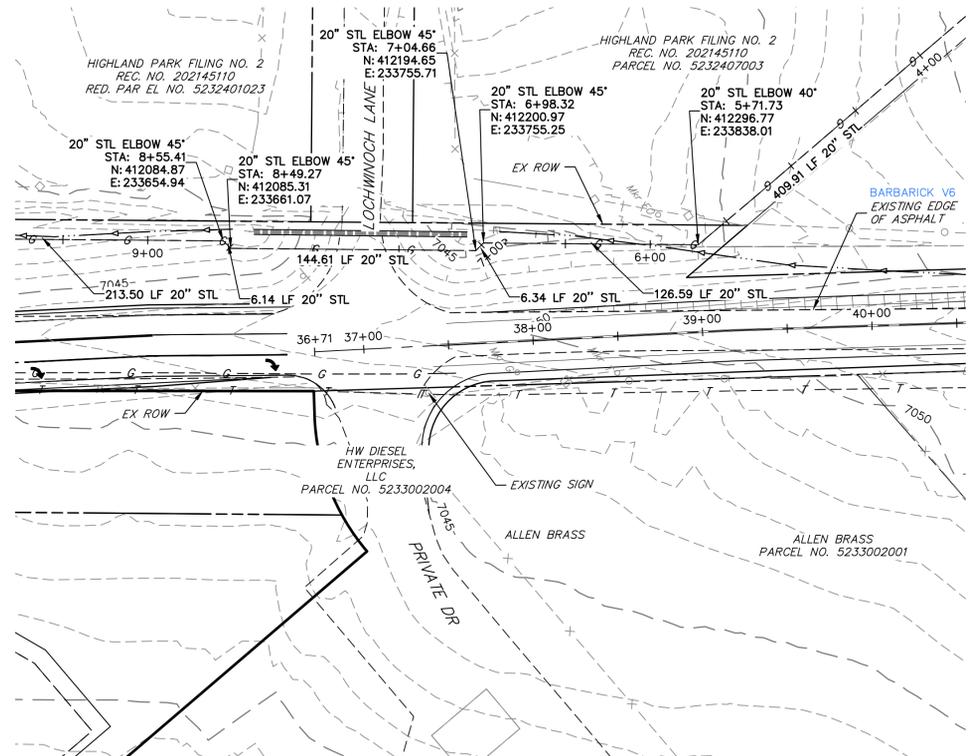

**CSU GASLINE START TO 26+71 PROFILE
STA 5+00.00 TO 9+00.00**

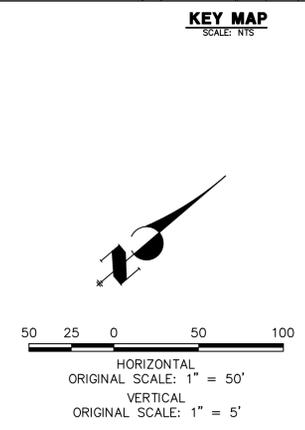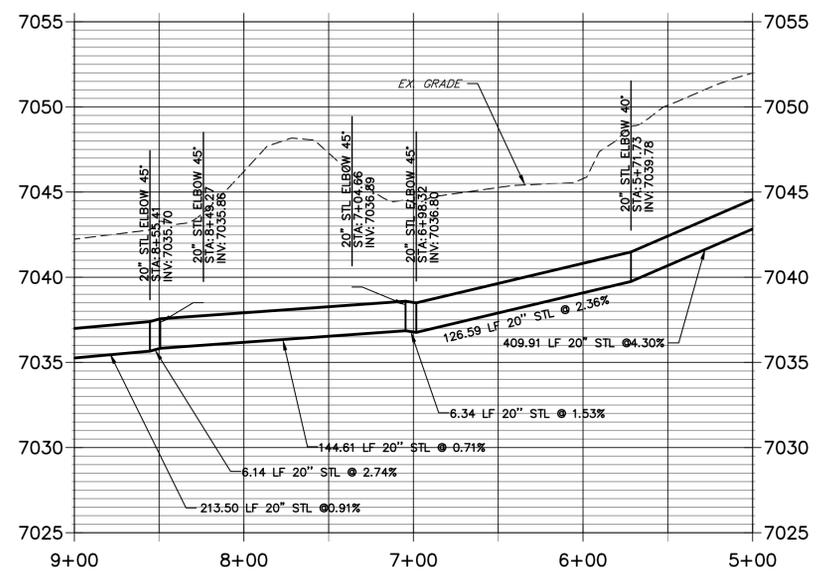

LEGEND

- EXISTING RIGHT OF WAY
- EXISTING PROPERTY LINE
- EXISTING CENTERLINE
- - - x - - - EXISTING FENCE
- - - G - - - EXISTING GAS LINE
- EXISTING STORM DRAIN
- - - T - - - EXISTING TELEPHONE LINE
- PROPOSED STORM DRAIN

NOTE

EXISTING UTILITIES SHOWN BASE UPON ABOVE GROUND EVIDENCE AND FLAGGING. CONTRACTOR TO VERIFY EXISTING UTILITY LAYOUT WITH POTHOLE AND UTILITY LOCATES PRIOR TO CONSTRUCTION ACTIVITIES.

WARNING
HIGH-PRESSURE PIPELINE(S)
EXCAVATION AND/OR CONSTRUCTION PROHIBITED WITHOUT COMPLIANCE WITH STATE ONE-CALL, AND WITHOUT WRITTEN PERMISSION FROM
MAGELLAN PIPELINE COMPANY, L.P.

ENGINEER'S STATEMENT

PREPARED UNDER MY DIRECT SUPERVISION AND ON BEHALF OF JR ENGINEERING

 MIKE A. BRAMLETT, P.E.
 COLORADO P.E. 32314
 FOR AND ON BEHALF OF JR ENGINEERING
 DATE 07/17/23



UNTIL SUCH TIME AS THESE DRAWINGS ARE APPROVED BY THE APPROPRIATE REVIEWING AGENCIES, JR ENGINEERING APPROVES THEIR USE DESIGNATED BY WRITTEN AUTHORIZATION.

PREPARED FOR
SR LAND, LLC
 20 BOULDER CRESCENT
 SUITE 201
 COLORADO SPRINGS, CO 80903
 JAMES F. MORLEY
 (719) 471-1742

J.R. ENGINEERING
 A Westman Company

 Centennial 303-740-9888 • Colorado Springs 719-583-2583
 Fort Collins 970-491-9888 • www.jrengineering.com

BY	DATE	No.	REVISION
		1"	50'
		1"	5'
		DATE	07/17/23
		DESIGNED BY	CWC
		DRAWN BY	D/JG
		CHECKED BY	

VOLLMER ROAD (BARBARICK) - INTERIM CONDITION
 GAS LINE PLAN AND PROFILE
 SHEET 6 OF 6
 JOB NO. 25188.01

SEE ABOVE

X:\2518801\Drawings\Sheet\Drawings\Sheet (Barbarick Interim) Gas P&P.dwg, GPV1, 07/18/2023, 3:10:30 PM, ARE Remote