SITE LIGHT FIXTURE SCHEDULE										
TYPE	MFGR.	CATALOG NO.	LAMPS QUAN. WATT TYPE		MTG.	DESCRIPTION	NOTES	VOLTS	TOTAL WATTS	
WP1	LITHONIA	DSXW2 LED 30C 700 40K T4M MVOLT	1	71	LED	SURFACE	DSXW2 LED WITH 3 LIGHT ENGINES, 30 LED's, 700mA DRIVER, 4000K LED, TYPE 4 MEDIUM OPTIC		120	71
WP2	LITHONIA	DSXW1 LED 10C 350 40K T2S MVOLT	1	13.3	LED	SURFACE	DSXW1 LED WITH (1) 10 LED LIGHT ENGINES, TYPE T2S OPTIC, 4000K, @ 350mA.		120	13.3



SITE PHOTOMETRIC PLAN


ES1.1 SCALE: 1" = 30'-0"



2 \ DSXW2 LED WALLPACK LUMINAIRE (WP1) ES1.1 SCALE: NONE



DSXW1 LED WALLPACK LUMINAIRE (WP2) ES1.1 SCALE: NONE

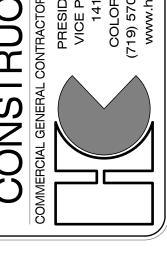


THIS DRAWING CONTAINS MATERIAL & INFORMATION WHICH MAY NOT BE REPRODUCED WITHOUT WRITTEN CONSE OF HAMMERS CONSTRUCTION, INC. TH DRAWINGS ARE INTENDED TO BE USED ONLY BY HAMMERS CONSTRUCTION & I REPRESENTATIVES. THESE DRAWINGS HAVE NOT BEEN PREPARED FOR ANY OTHER PURPOSE THAN TO INDICATE THE GENERAL FEATURES AND PLACEMENT OF THE PROPOSED PROJECT. COPYRIGHT 2018 HAMMERS CONSTRUCTION






DATE: SEPT. 14, 2018 DRAWN BY: C.C.F. PROJ. MNGR: Z. CRABTREE SCALE: SEE PLAN APPROVED BY: JOB NO: 18-973

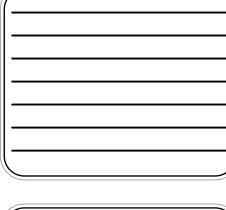

ES1.1

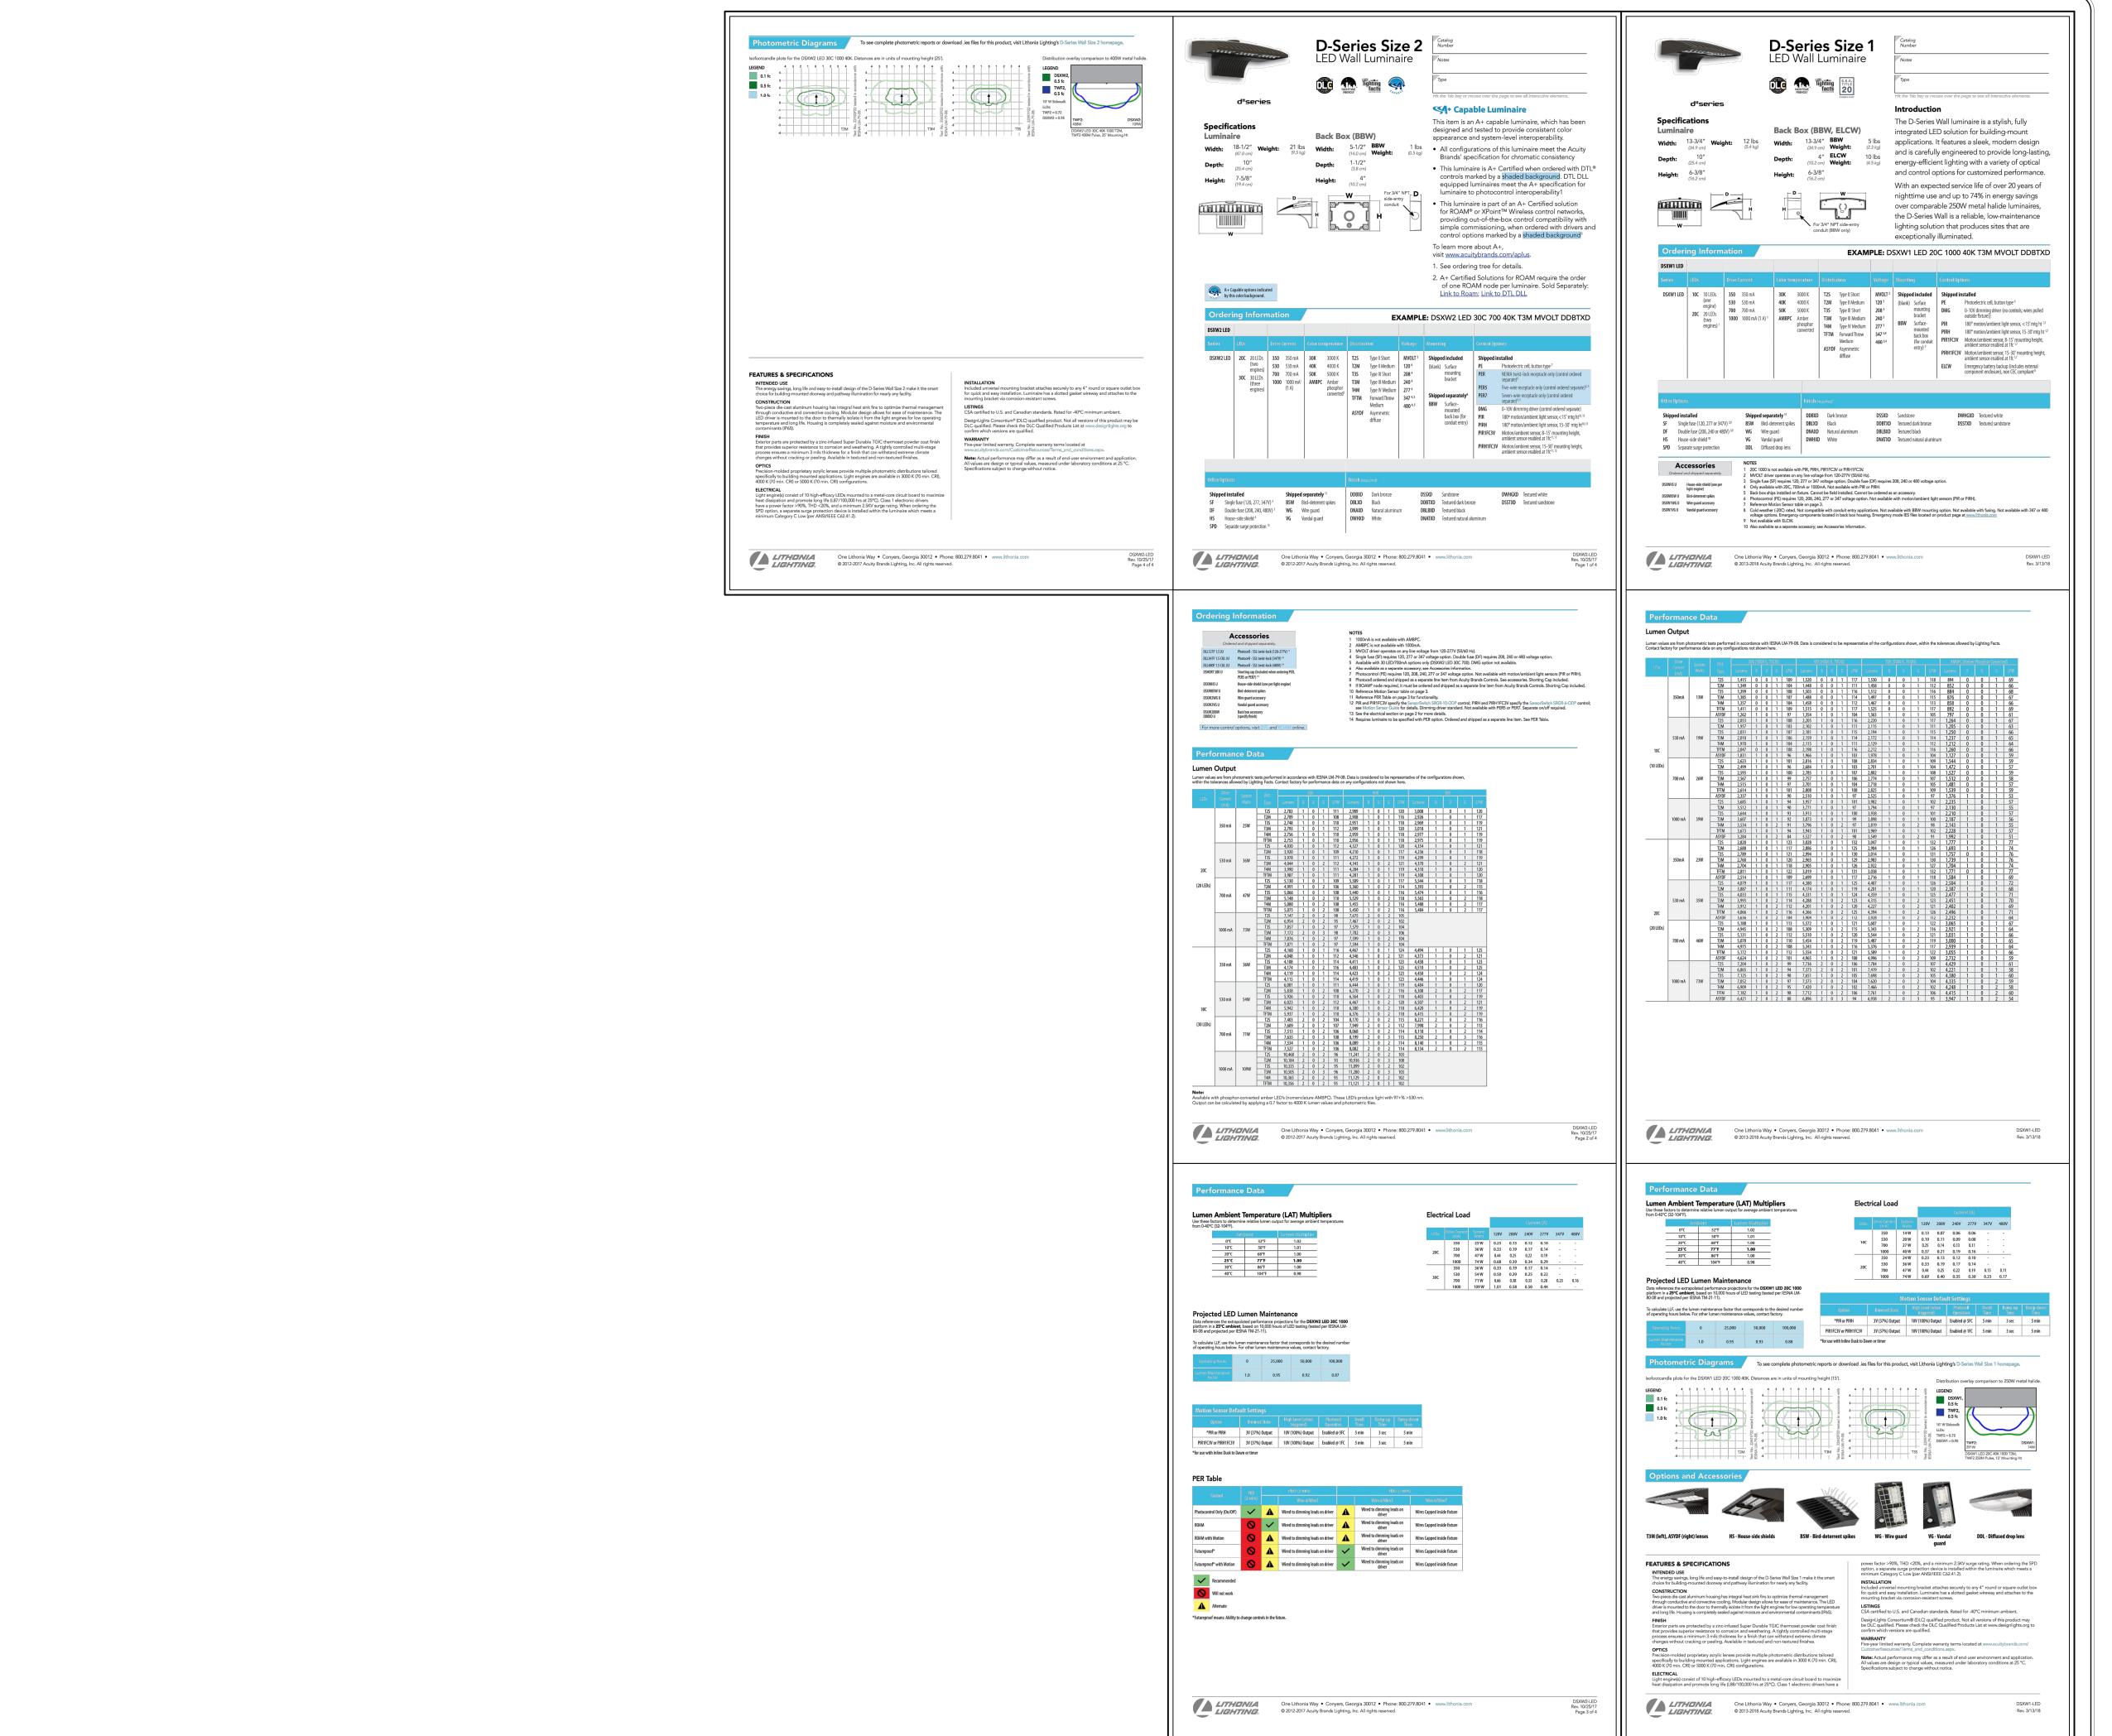

HAMMERS

NSTRUCTION INC.

GENERAL CONTRACTORS SPECIALIZING IN DESIGN/BL


PRESIDENT: STEVE R. HAMMERS

THIS DRAWING CONTAINS MATERIAL & INFORMATION WHICH MAY NOT BE REPRODUCED WITHOUT WRITTEN CONSENT OF HAMMERS CONSTRUCTION, INC. THESE DRAWINGS ARE INTENDED TO BE USED ONLY BY HAMMERS CONSTRUCTION & ITS REPRESENTATIVES. THESE DRAWINGS HAVE NOT BEEN PREPARED FOR ANY OTHER PURPOSE THAN TO INDICATE THE GENERAL FEATURES AND PLACEMENT OF THE PROPOSED PROJECT. COPYRIGHT © 2018 HAMMERS CONSTRUCTION


Y BY HAMMERS CONSTRUCTION
RESENTATIVES. THESE DRAWING
E NOT BEEN PREPARED FOR AN
ER PURPOSE THAN TO INDICATE
ERAL FEATURES AND PLACEMEN
PROPOSED PROJECT. COPYRIG
B HAMMERS CONSTRUCTION

WOODFORD - ADD. 2
2121 WAYNOKA ROAD
COLORADO SPRINGS, CO 80915
EL PASO COUNTY, COLORADO



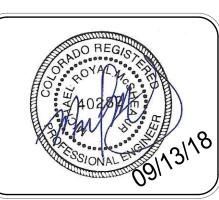

DATE: SEPT. 14, 2018
DRAWN BY: C.C.F.
PROJ. MNGR: Z. CRABTREE
SCALE: SEE PLAN
APPROVED BY:
JOB NO: 18-973

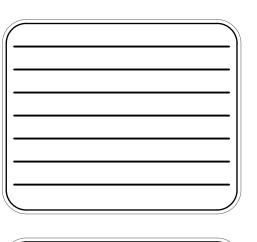

ES1.2