

**MONUMENT
ACADEMY**

DEVELOPMENT PLAN

OWNERSHIP OF INSTRUMENTS OF SERVICE:
 ALL REPORTS, PLANS, SPECIFICATIONS,
 COMPUTER FILES, FIELD DATA, NOTES AND
 OTHER DOCUMENTS AND INSTRUMENTS
 PREPARED BY DESIGN PROFESSIONAL AS
 INSTRUMENTS OF SERVICE SHALL REMAIN THE
 PROPERTY OF THE OWNER. THE DESIGN
 PROFESSIONAL SHALL RETAIN ALL
 COMMON LAW STATUTORY AND OTHER
 RESERVED RIGHTS INCLUDING THE COPYRIGHT
 THEREOF.


CRP ARCHITECTS AIA
 100 East St. Vrain, Suite 300
 Colorado Springs, CO 80903

**ELECTRICAL SITE
DEVELOPMENT PLAN**


SCALE: AS NOTED

**DATE: 01-31-19
DRAWN BY: BMG
CHECKED: ELE
REVISED:**

ES1

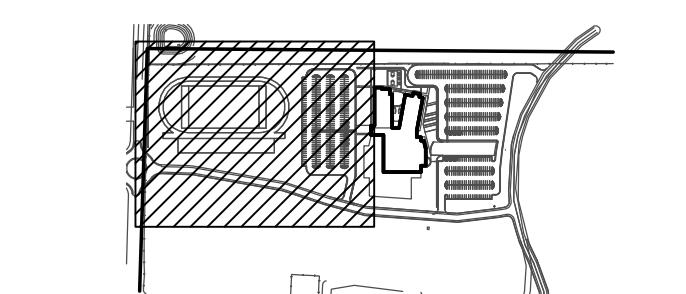

KEYPLAN

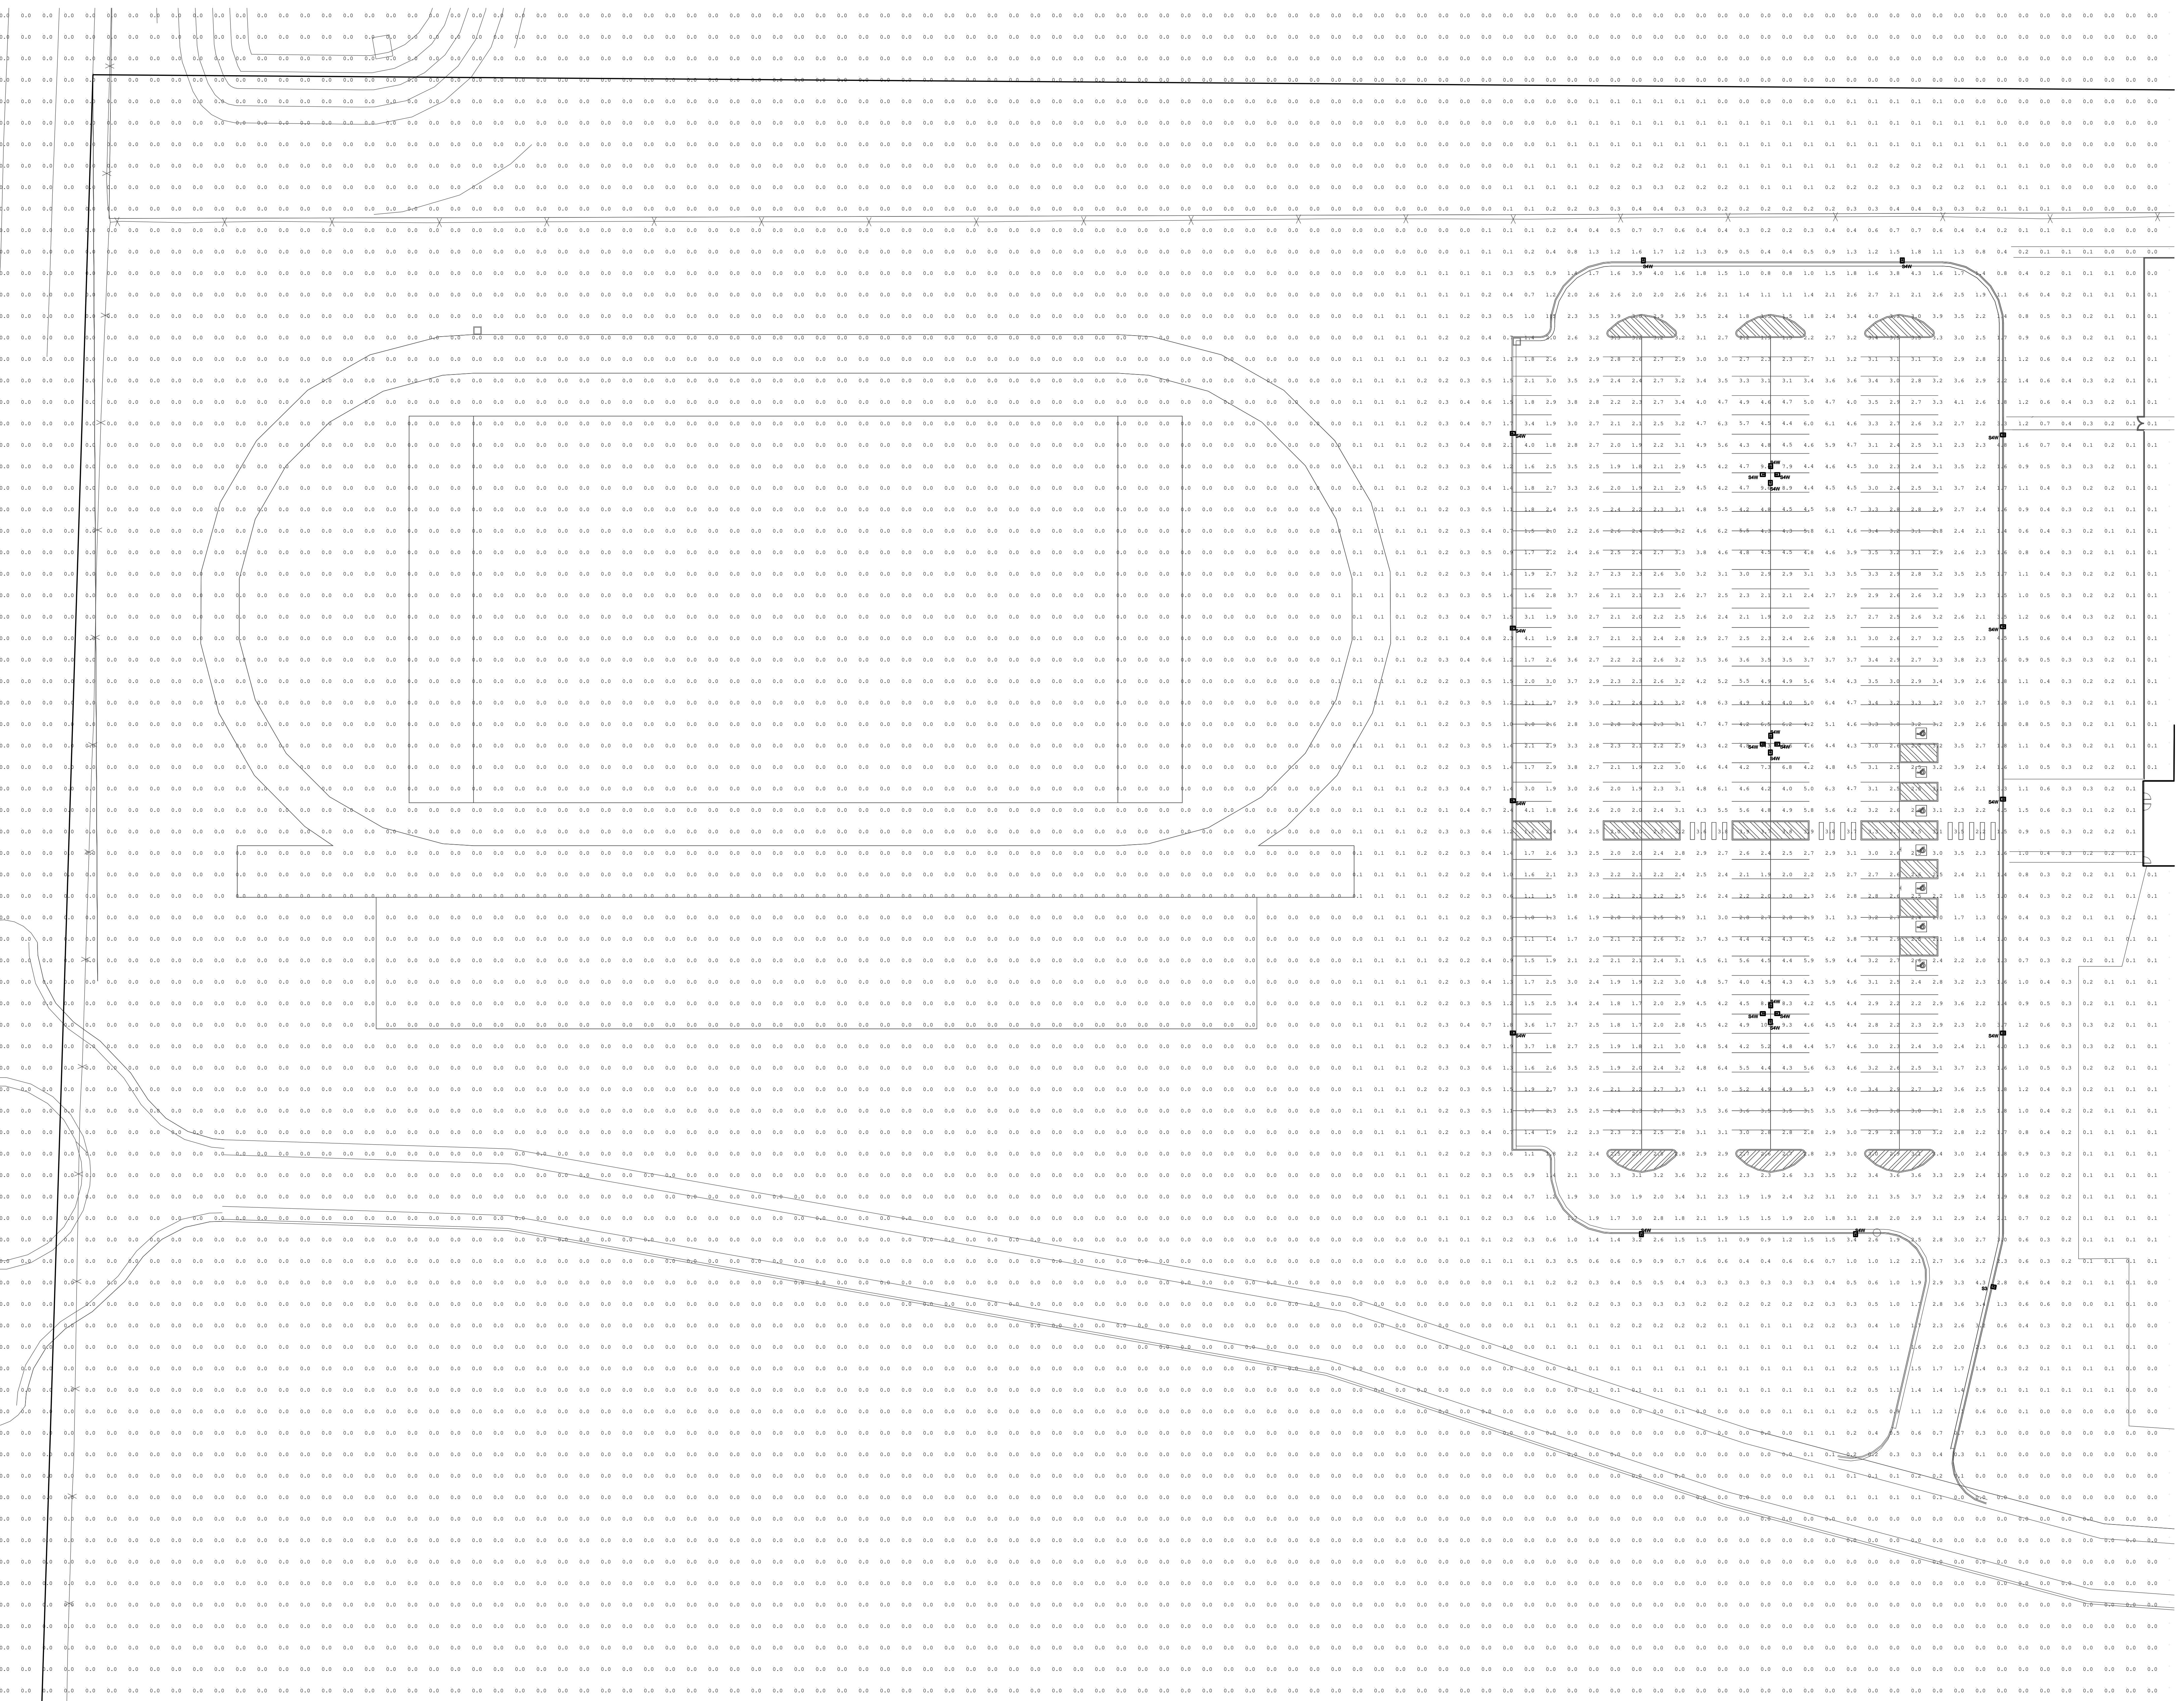


SITE LIGHTING PHOTOMETRICS				
ESI	1"	= 30'		

ME Engineers, Inc. 3425 austin bluffs pkwy, ste 201 colorado springs, co 80918 L719360000/L719360007 www.me-engineers.com

MONUMENT ACADEMY

DEVELOPMENT PLAN

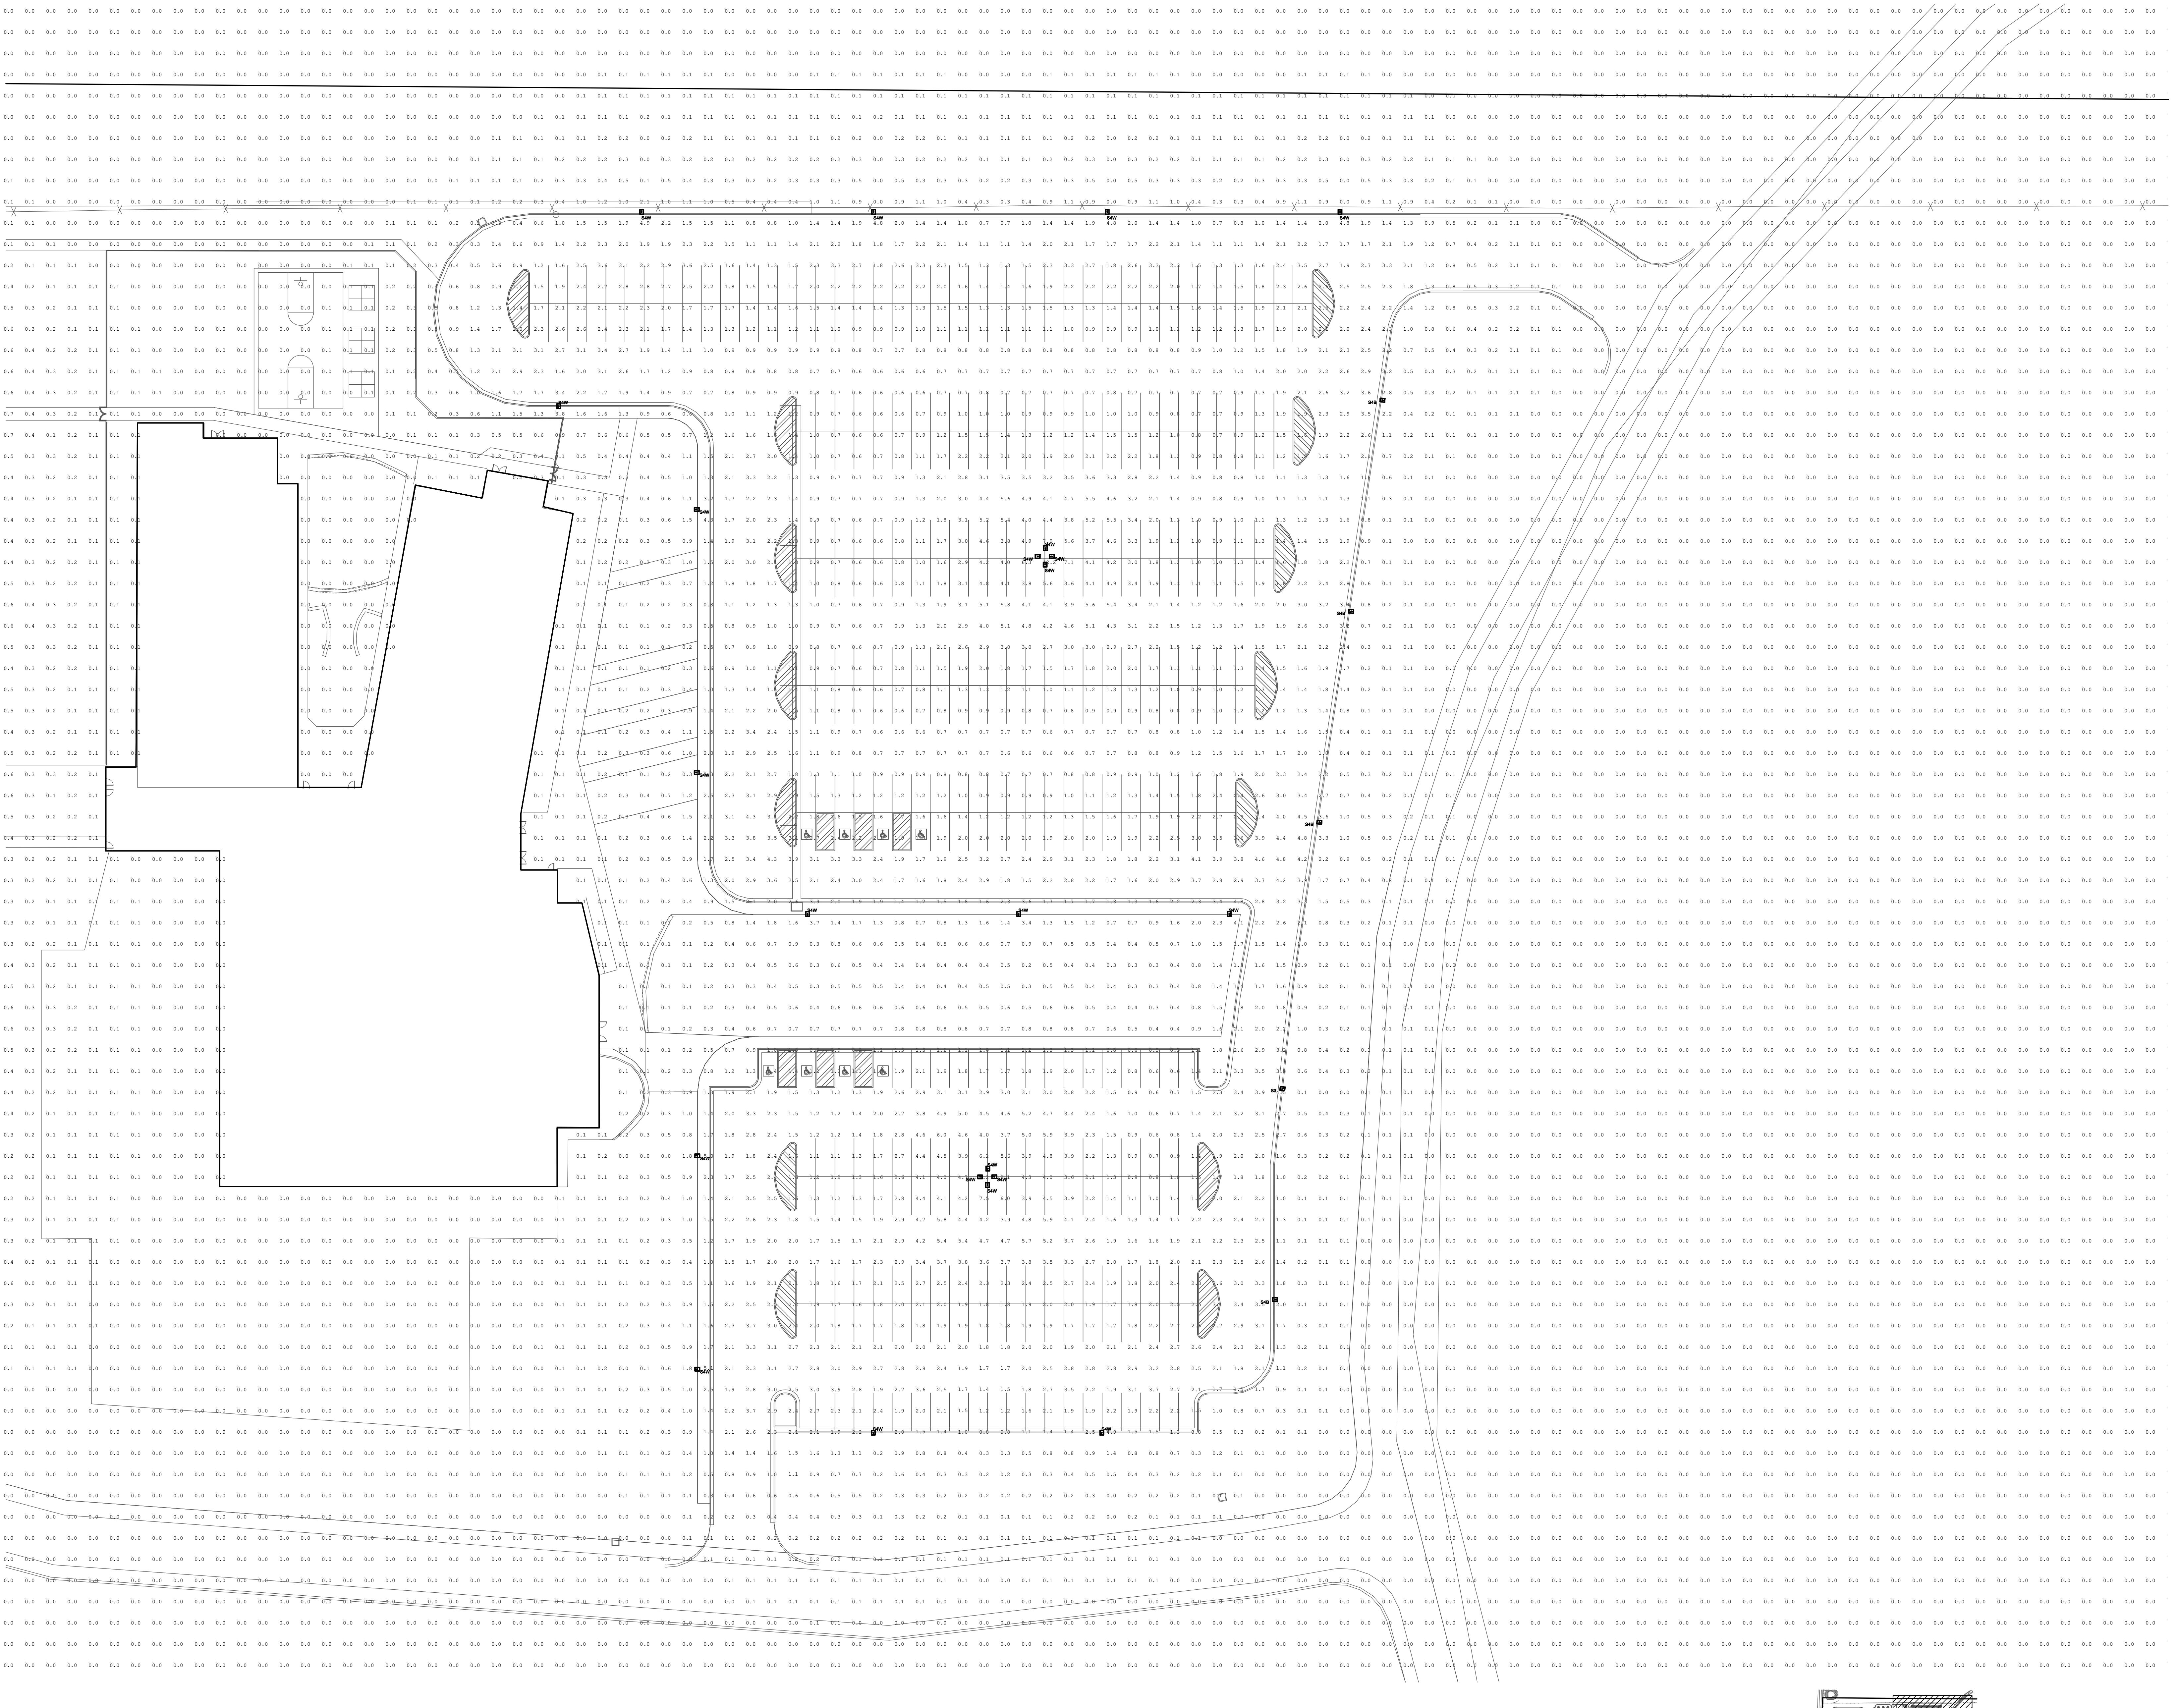

OWNERSHIP OF INSTRUMENTS OF SERVICE:
ALL REPORTS, PLANS, SPECIFICATIONS,
COMPUTER FILES, FIELD DATA, NOTES AND
OTHER DOCUMENTS AND INSTRUMENTS
PREPARED BY DESIGN PROFESSIONAL AS
INSTRUMENTS OF SERVICE SHALL REMAIN THE
PROPERTY OF THE DESIGN PROFESSIONAL.
THE DESIGN PROFESSIONAL SHALL RETAIN ALL
COMMON LAW STATUTORY AND OTHER
RESERVED RIGHTS INCLUDING THE COPYRIGHT
THEREOF.


CRP ARCHITECTS AIA
100 East St. Vrain, Suite 300
Colorado Springs, CO 80903

**ELECTRICAL SITE
DEVELOPMENT PLAN**

SCALE: AS NOTED

**DATE: 01-31-19
DRAWN BY: BMG
CHECKED: ELE
REVISED:**

me engineers
ME Engineers, Inc.
3425 Austin Bluffs Pkwy, Ste 201
Colorado Springs, CO 80918
L719360000/L7193600007
www.me-engineers.com

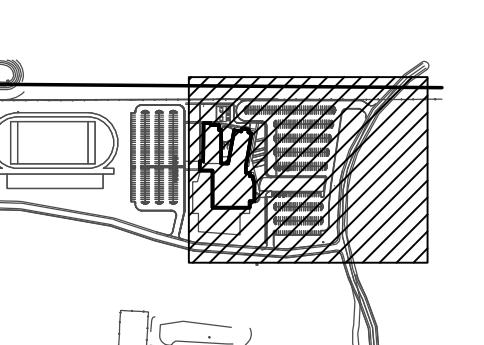


KEYPLAN

SITE LIGHTING PHOTOMETRICS

ES2 1" = 30'

Luminaire Schedule				
Symbol	Tag	Qty	LLF	Description
S4W	46	0.850	LARGE LED SITE POLE, 135W, TYPE 4	
S3	2	0.850	LARGE LED SITE POLE, 135W, TYPE 3	
S4B	4	0.850	LARGE LED SITE POLE, 135W, TYPE 4 BACKLIGHT CONTROL	

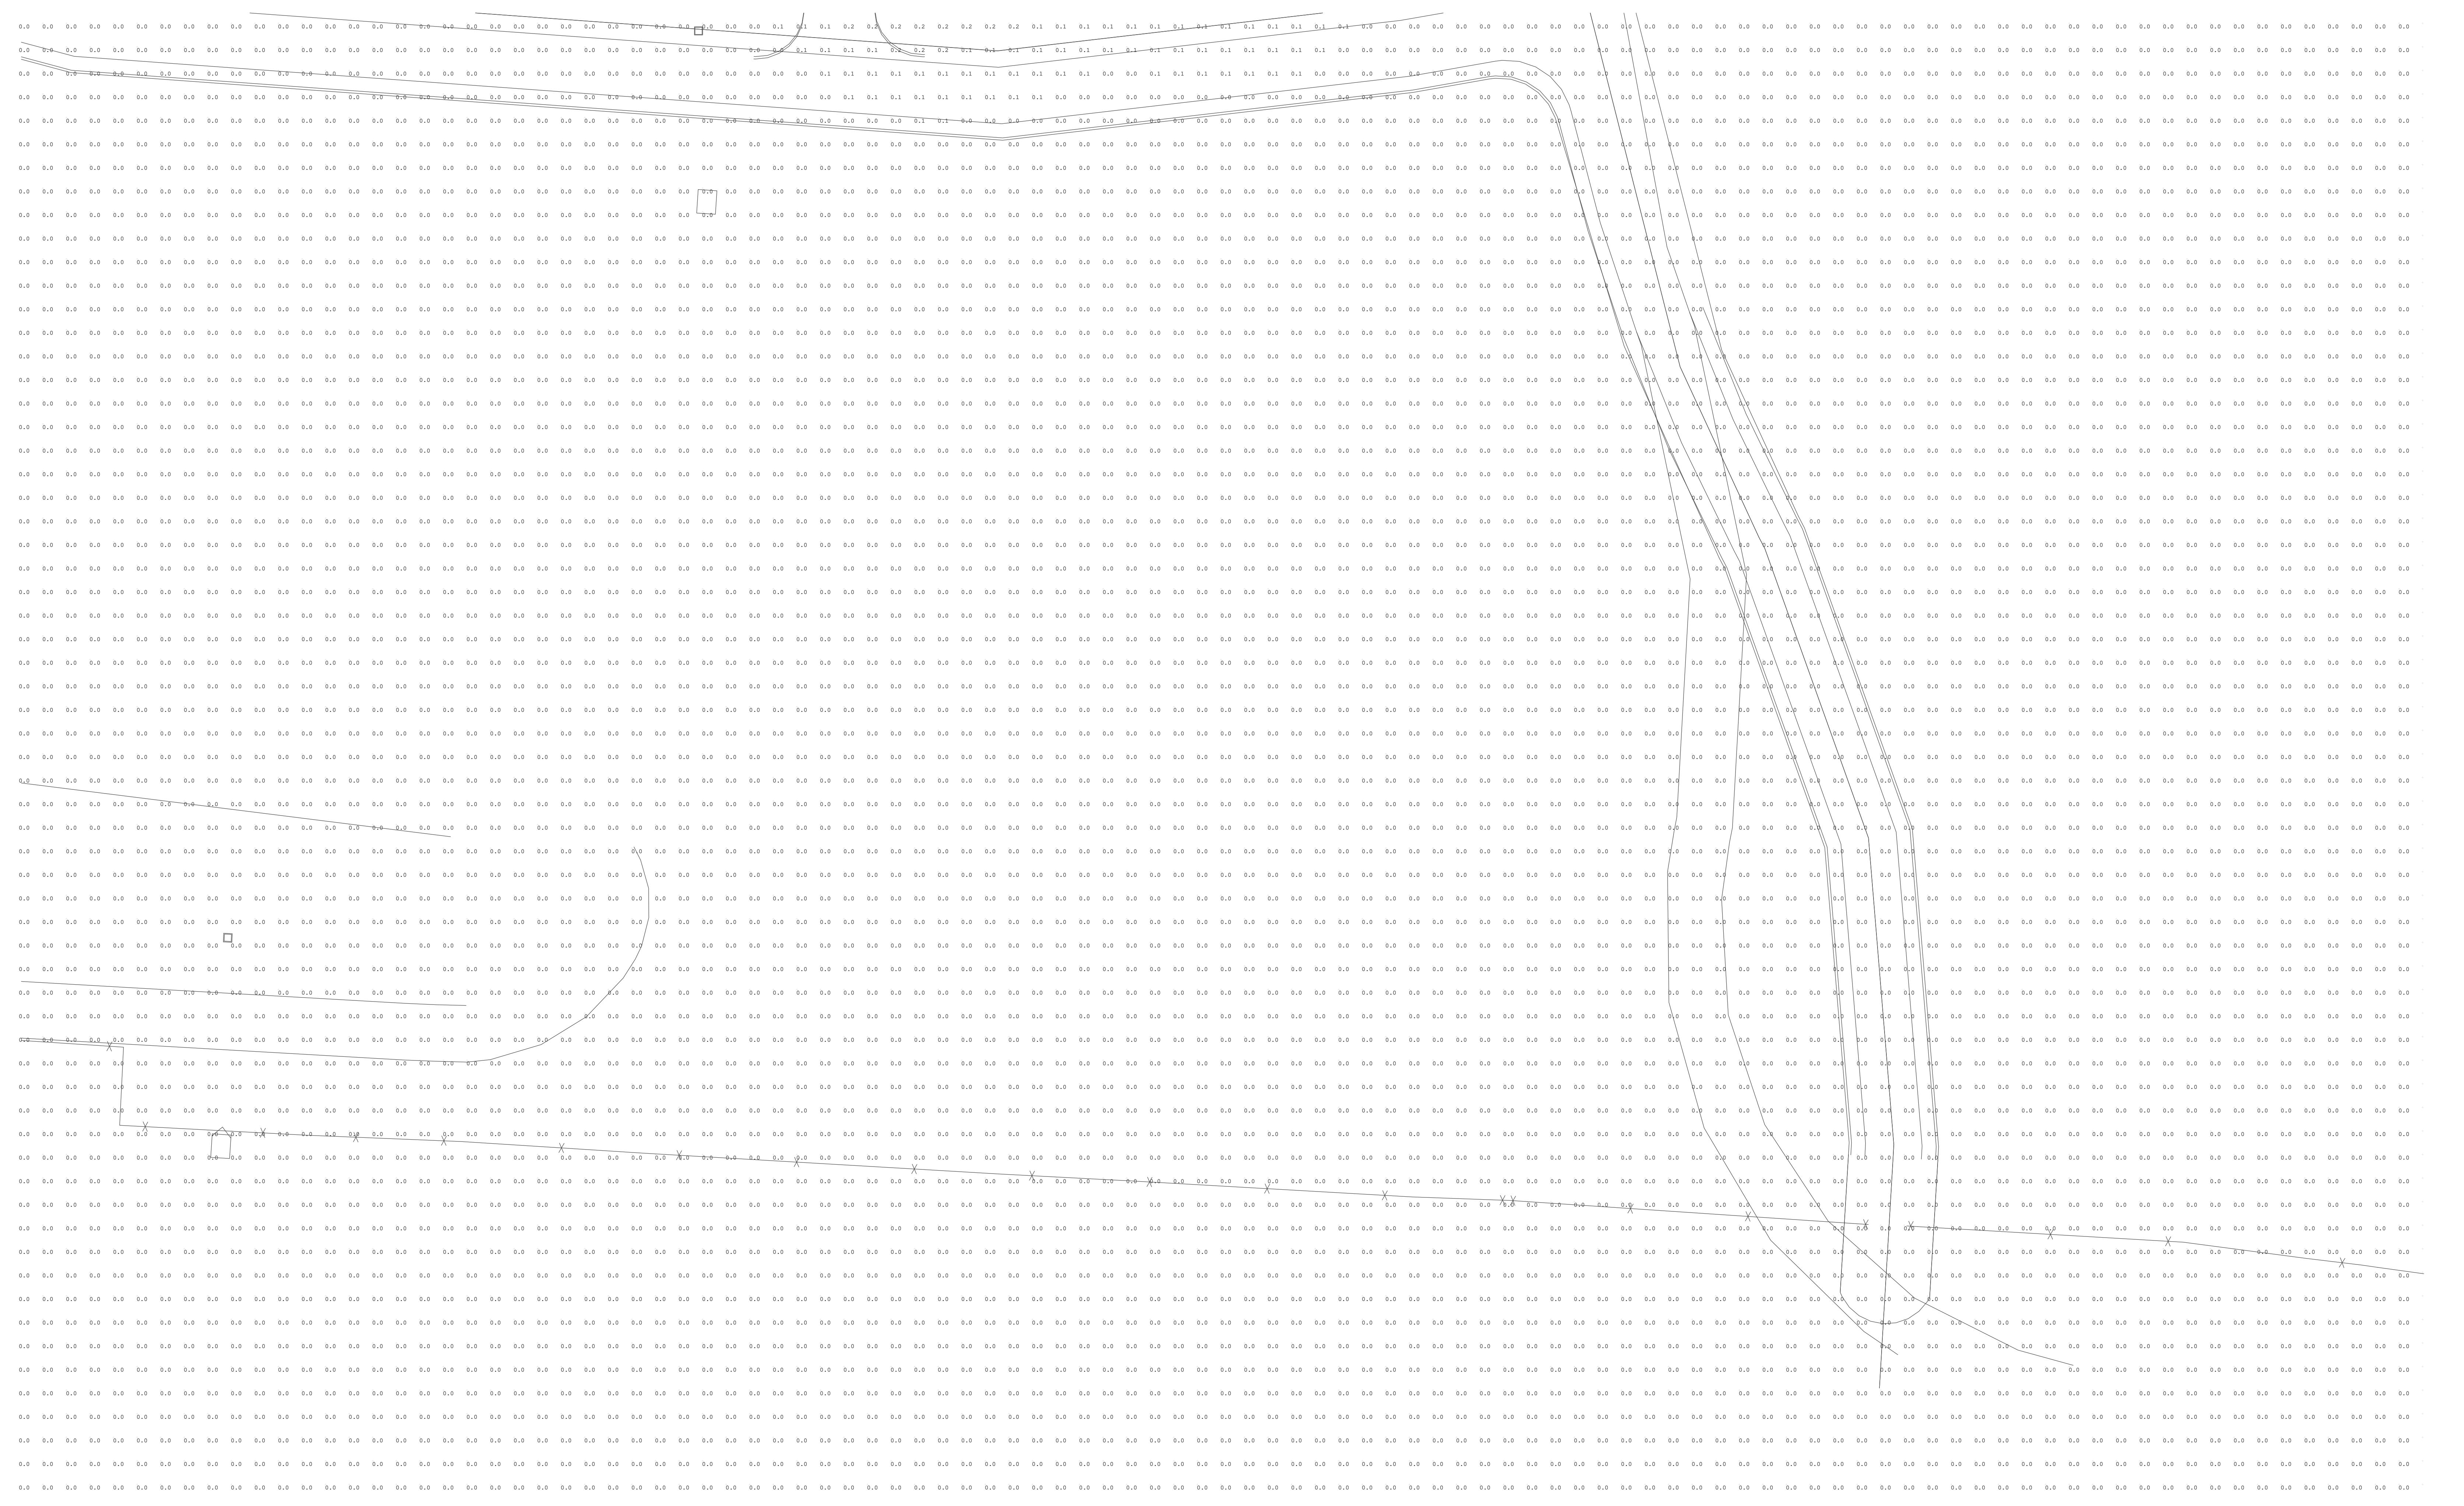

DEVELOPMENT PLAN

OWNERSHIP OF INSTRUMENTS OF SERVICE:
ALL REPORTS, PLANS, SPECIFICATIONS,
COMPUTER FILES, FIELD DATA, NOTES AND
OTHER DOCUMENTS AND INSTRUMENTS
PREPARED BY DESIGN PROFESSIONAL AS
INSTRUMENTS OF SERVICE SHALL REMAIN THE
PROPERTY OF THE DESIGN PROFESSIONAL.
THE DESIGN PROFESSIONAL SHALL RETAIN ALL
COMMON LAW STATUTORY AND OTHER
RESERVED RIGHTS INCLUDING THE COPYRIGHT
THERETO.

CRP ARCHITECTS AIA
100 East St. Vrain, Suite 300
Colorado Springs, CO 80903

ELECTRICAL SITE
DEVELOPMENT PLAN


SCALE: AS NOTED

DATE: 01-31-19
DRAWN BY: BMG
CHECKED: ELE
REVISED:

ES3

Luminaire Schedule				
Symbol	Tag	Qty	LLF	Description
[Symbol]	S4W	46	0.850	LARGE LED SITE POLE, 135W, TYPE 4
[Symbol]	S3	2	0.850	LARGE LED SITE POLE, 135W, TYPE 3
[Symbol]	S4B	4	0.850	LARGE LED SITE POLE, 135W, TYPE 4 BACKLIGHT CONTROL

1 SITE LIGHTING PHOTOMETRICS
ES3 1" = 30'

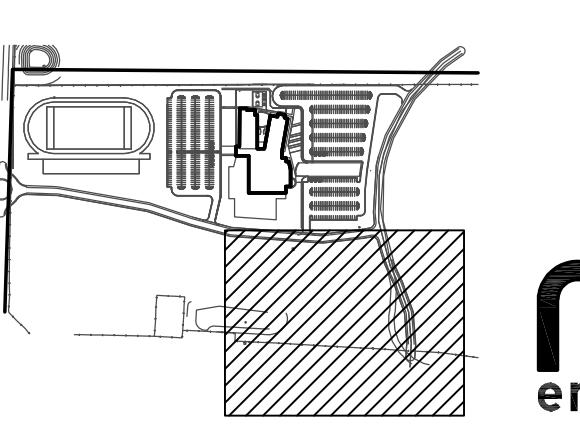

me
engineers

ME Engineers, Inc.
3425 austin bluffs pkwy, ste 201
colorado springs, co 80918
L719360000/L719360007
www.me-engineers.com