

PRESENTED TO



#5934 Powers & Palmer Park
SEC of Powers Blvd. & Palmer Park Blvd., Colorado Springs, CO.



National Sign & Marketing Corporation

GOVERNING CODES:
2022 California Building Code
2022 California Fire Codes
2022 California Mechanical Codes
2022 California Electrical Codes
2022 California Energy Conservation Codes

DRAWING #31130R1


13580 5th Street • Chino, CA 91710 • Tel: 909.591.4742 • FAX: 909.747.6446 • Toll Free: 877.877.NSMC

SCOPE OF WORK - NON-ILLUMINATED SIGNS

- H** NEW SINTRA ADDRESS NUMERALS
- I** **J** NEW HANDICAP PARKING SIGNS
- K** NEW SERVING HOURS PLAQUE
- L** NEW TEAM MEMBER ONLY VINYL
- M** NEW RESTROOM ONLY VINYL
- N** NEW PICKUP SIGN
- O** **P** NEW ORDER SIGN

Install Only
Manufacturing By Others

- 3** **4** DRIVE-THRU CLEARANCE ARM
- 5** FLAG POLE

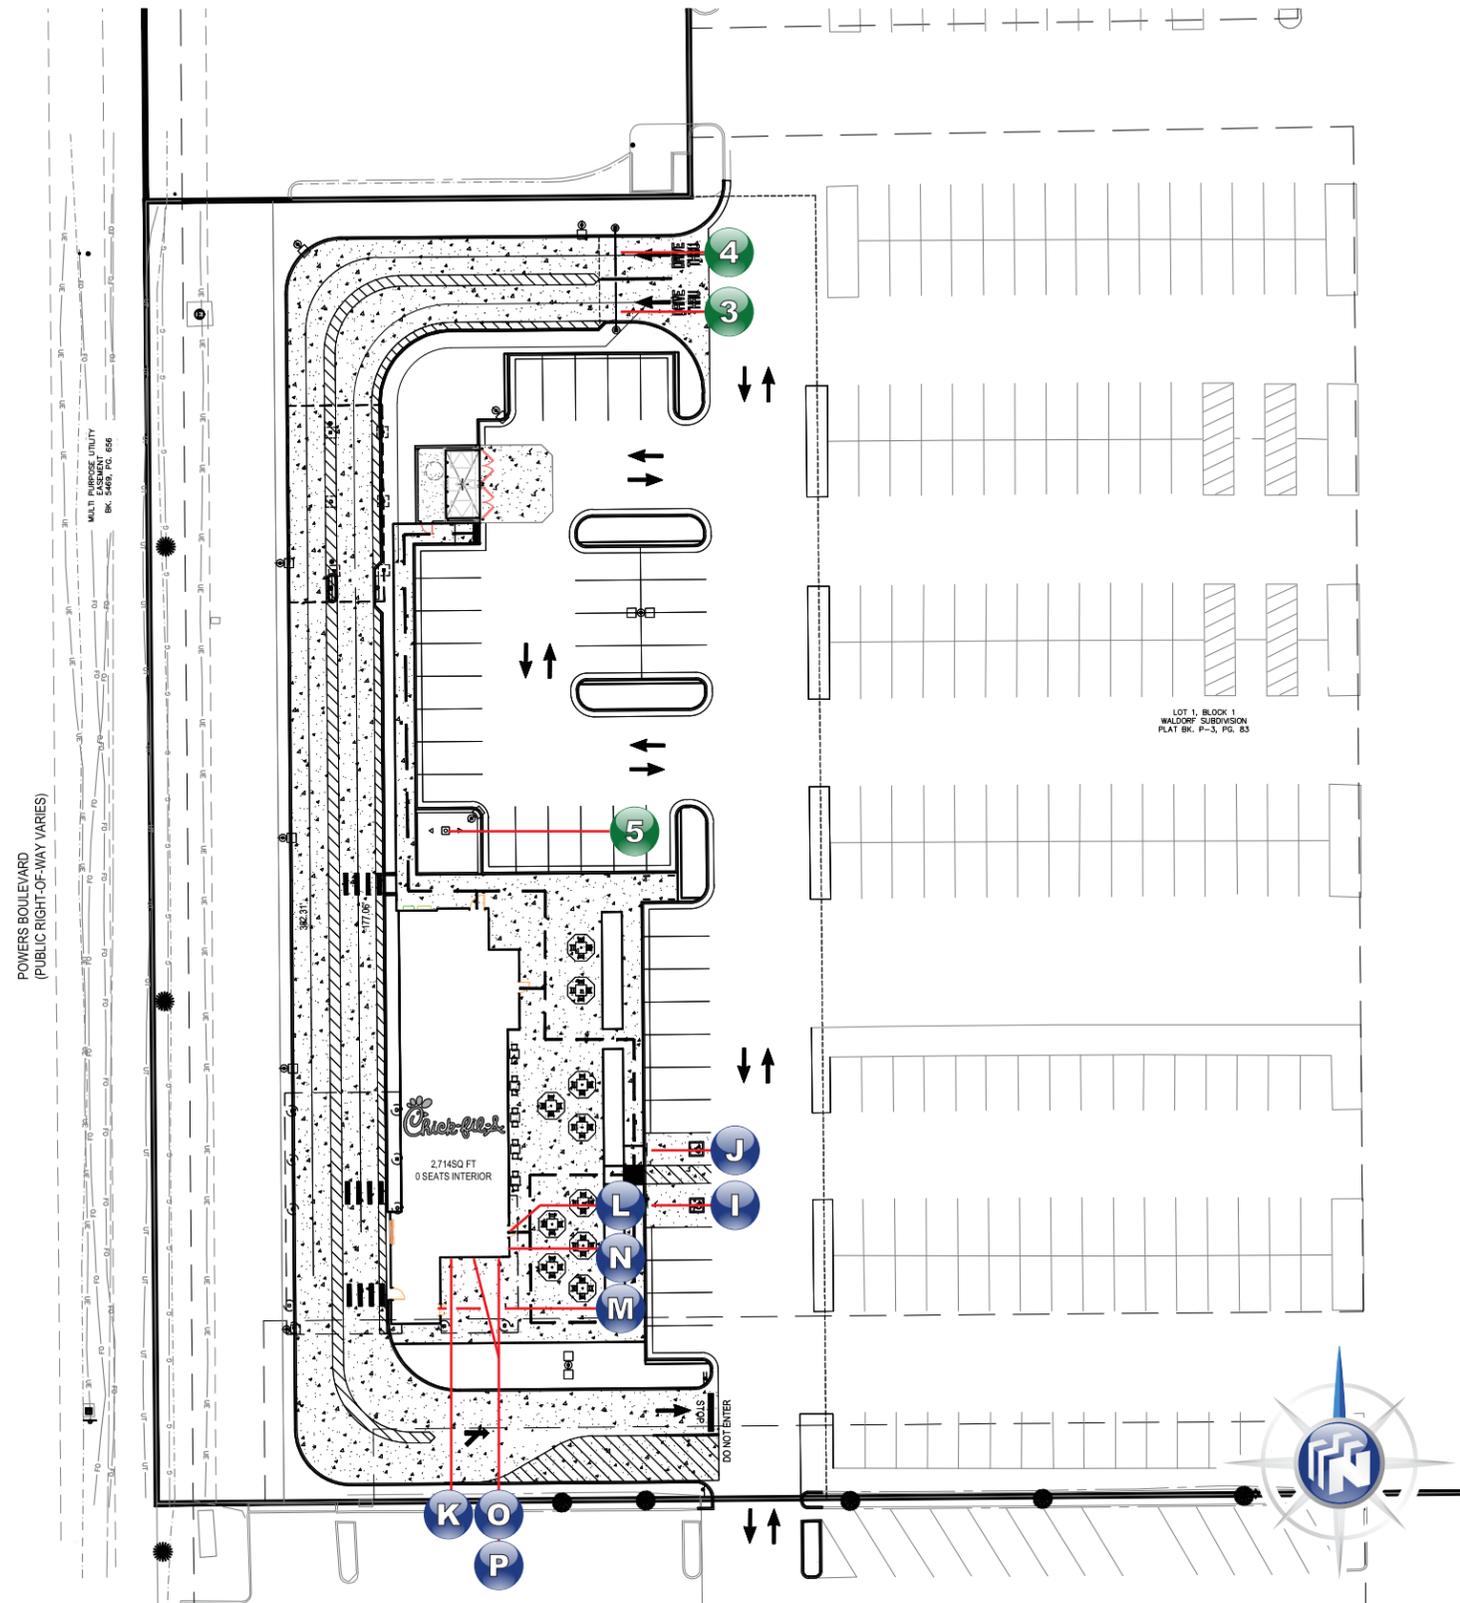

SIGN ID LETTER	FACE A	FACE B
H	0000	N/A
I		N/A
J		N/A
K		
L	Team Members Only	N/A
M	Restroom Only	N/A
N	Pick Up	N/A
O P	Order	N/A
3		N/A
4		N/A
5		N/A



National Sign & Marketing Corporation
13580 5th St., Chino, CA 91710
Tel 909.591.4742 Fax 909.747.6446
e-mail: sales@nsmc.com
Lic# 745030 - Exp. 01/31/26

Project Name:
Chick-fil-A #5934
Powers & Palmer Park

Address:
SEC Power Blvd. & Palmer Park Blvd.
Colorado Springs, CO.

Account Mgr.
Steve Rosenbloom

Approved by:

Date:

Drawing Number
31130R1

Revision
02/21/25 TB: Update A to canopy mounted, add C. Pylon goes to addendum.

Designer: T Behrman
Date: 01/10/2025

Page 2

Scale:

THIS IS AN ORIGINAL UNPUBLISHED DRAWING CREATED FOR YOUR PERSONAL USE IN CONNECTION WITH A PROJECT PLANNED FOR YOU BY NSMC. IT IS NOT TO BE SHOWN OUTSIDE YOUR ORGANIZATION NOR USED, REPRODUCED, COPIED OR EXHIBITED IN ANY FASHION UNLESS AUTHORIZED IN WRITING BY AN OFFICER OF NSMC.

This sign intended to be in accordance with the requirements of Article 600 of the National Electrical Code and/or other applicable local codes. This includes proper grounding and bonding of this sign.





National Sign & Marketing Corporation
 13580 5th St., Chino, CA 91710
 Tel 909.591.4742 Fax 909.747.6446
 e-mail: sales@nsmc.com
 Lic# 745030 - Exp. 01/31/26

Project Name:
 Chick-fil-A
 #5934
 Powers & Palmer Park

Address:
 SEC Power Blvd. &
 Palmer Park Blvd.
 Colorado Springs, CO.

Account Mgr.
 Steve Rosenbloom

Approved by:

Date:

Drawing Number
31130R1

Revision
 02/21/25 TB: Update A to canopy mounted.
 add C. Pylon goes to addendum.

Designer: T Behrman
Date: 01/10/2025


ELEVATIONS

Page 3

Scale: 3/32" = 1'-0"


THIS IS AN ORIGINAL UNPUBLISHED DRAWING CREATED FOR YOUR PERSONAL USE IN CONNECTION WITH A PROJECT PLANNED FOR YOU BY NSMC. IT IS NOT TO BE SHOWN OUTSIDE YOUR ORGANIZATION NOR USED, REPRODUCED, COPIED OR EXHIBITED IN ANY FASHION UNLESS AUTHORIZED IN WRITING BY AN OFFICER OF NSMC.

This sign intended to be in accordance with the requirements of Article 600 of the National Electrical Code and/or other applicable local codes. This includes proper grounding and bonding of this sign.

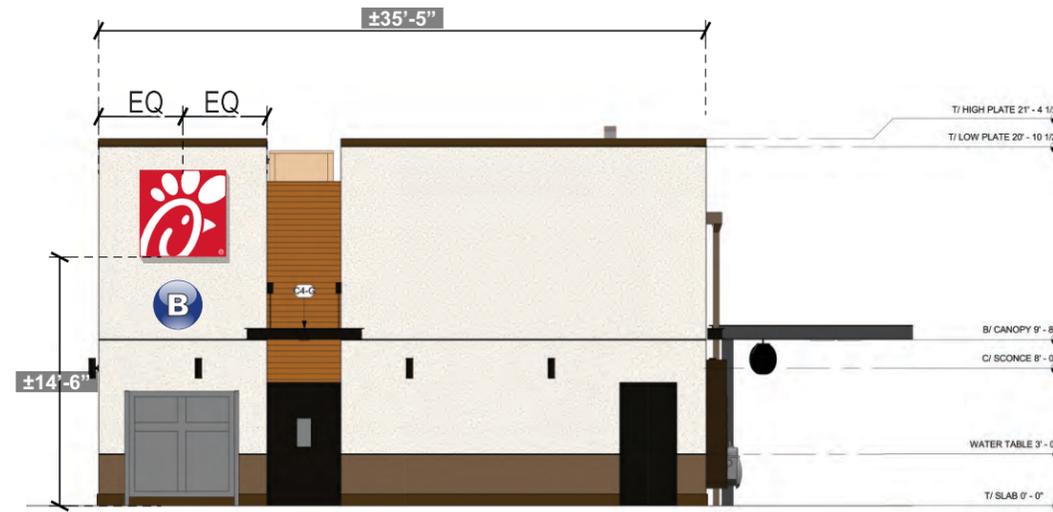

B NEW 5'-0" ILLUM. "CHICK-FIL-A" ICON LOGO CABINET

North Elevation

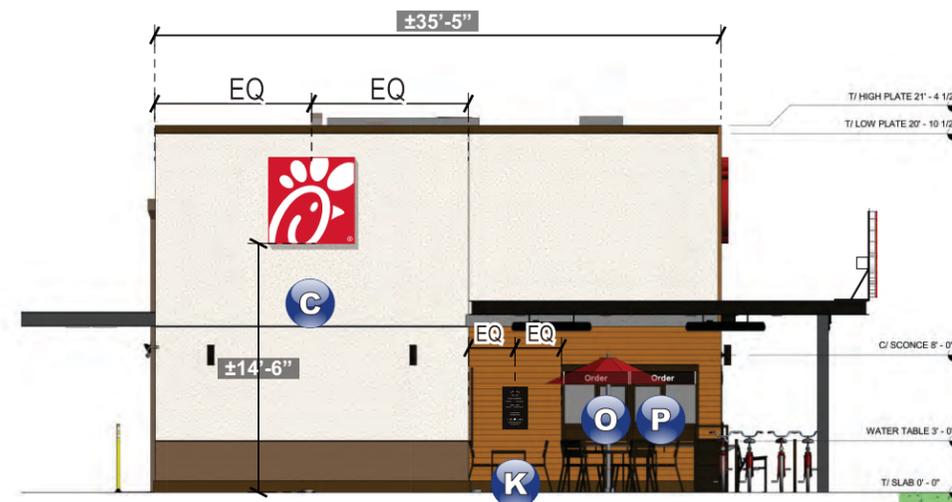

O P NEW ORDER SIGN

K NEW SERVING HOURS PLAQUE

C NEW 5'-0" ILLUM. "CHICK-FIL-A" ICON LOGO CABINET

South Elevation



National Sign & Marketing Corporation
 13580 5th St., Chino, CA 91710
 Tel 909.591.4742 Fax 909.747.6446
 e-mail: sales@nsmc.com
 Lic# 745030 - Exp. 01/31/26

Project Name:
 Chick-fil-A
 #5934
 Powers & Palmer Park

Address:
 SEC Power Blvd. &
 Palmer Park Blvd.
 Colorado Springs, CO.

Account Mgr.
 Steve Rosenbloom

Approved by:

Date:

Drawing Number
31130R1

Revision
 02/21/25 TB: Update A to canopy mounted.
 add C. Pylon goes to addendum.

Designer: T Behrman
Date: 01/10/2025


ELEVATIONS

Page 4

Scale: 3/32" = 1'-0"


THIS IS AN ORIGINAL UNPUBLISHED DRAWING CREATED FOR YOUR PERSONAL USE IN CONNECTION WITH A PROJECT PLANNED FOR YOU BY NSMC. IT IS NOT TO BE SHOWN OUTSIDE YOUR ORGANIZATION NOR USED, REPRODUCED, COPIED OR EXHIBITED IN ANY FASHION UNLESS AUTHORIZED IN WRITING BY AN OFFICER OF NSMC.

This sign intended to be in accordance with the requirements of Article 600 of the National Electrical Code and/or other applicable local codes. This includes proper grounding and bonding of this sign.

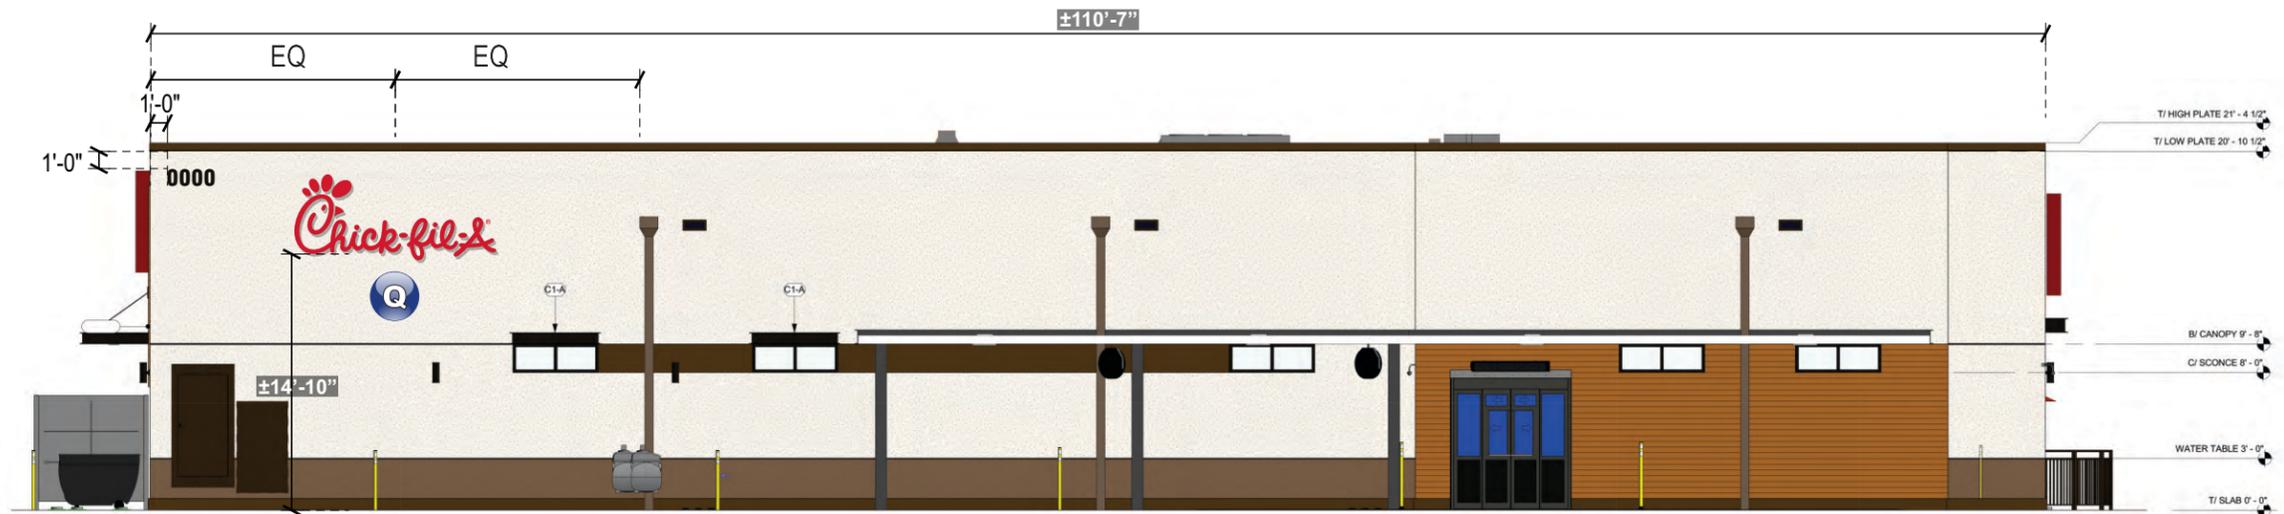

Q NEW 5'-0" ILLUM. "CHICK-FIL-A" CHANNEL LETTERS

West Elevation

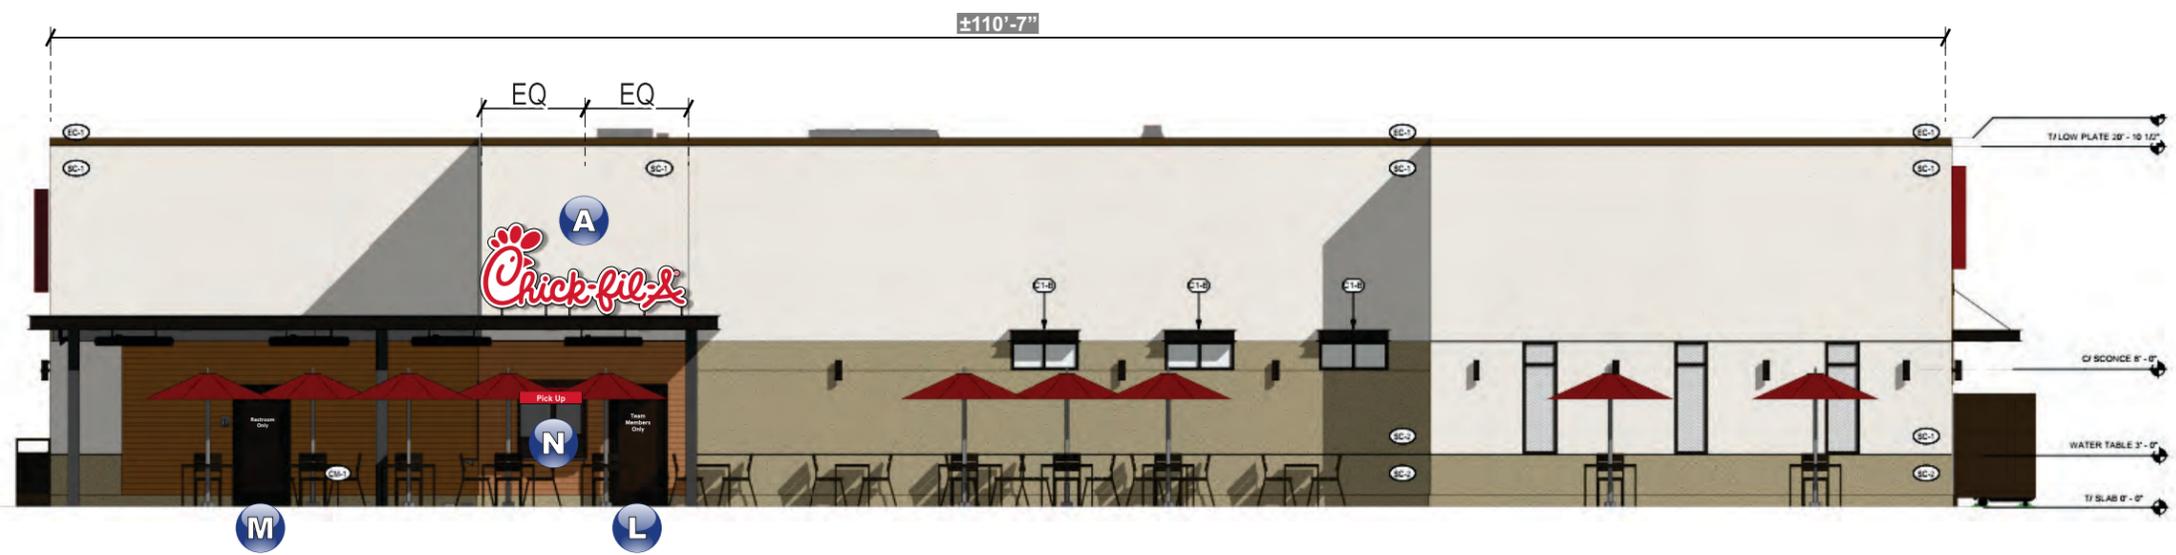

M NEW RESTROOM ONLY VINYL

L NEW TEAM MEMBER ONLY VINYL

N NEW PICKUP SIGN

A NEW 5'-0" ILLUM. "CHICK-FIL-A" CHANNEL LETTERS ON BACKER SIGN

East Elevation

NOTE:

*GC TO SUPPLY PRIMARY POWER SOURCE ALL

*COMPONENTS TO BE U.L. LISTED AND APPROVED.

*THE LOCATION OF THE DISCONNECT SWITCH AFTER INSTALLATION SHALL COMPLY WITH ARTICLE 600.6(A) (1) OF THE NATIONAL ELECTRICAL CODE.



National Sign & Marketing Corporation
 13580 5th St., Chino, CA 91710
 Tel 909.591.4742 Fax 909.747.6446
 e-mail: sales@nsmc.com
 Lic# 745030 - Exp. 01/31/26

Project Name:
 Chick-fil-A
 #5934
 Powers & Palmer Park

Address:
 SEC Power Blvd. &
 Palmer Park Blvd.
 Colorado Springs, CO.

Account Mgr.

Steve Rosenbloom

Approved by:

Date:

Drawing Number
31130R1

Revision

02/21/25 TB: Update A to canopy mounted, add C. Pylon goes to addendum.

Designer: T.Behrman
Date: 01/10/2025


SECTION
DETAIL

Page 6

Scale: NTS

THIS IS AN ORIGINAL UNPUBLISHED DRAWING CREATED FOR YOUR PERSONAL USE IN CONNECTION WITH A PROJECT PLANNED FOR YOU BY NSMC. IT IS NOT TO BE SHOWN OUTSIDE YOUR ORGANIZATION NOR USED, REPRODUCED, COPIED OR EXHIBITED IN ANY FASHION UNLESS AUTHORIZED IN WRITING BY AN OFFICER OF NSMC

This sign intended to be in accordance with the requirements of Article 600 of the National Electrical Code and/or other applicable local codes. This includes proper grounding and bonding of this sign.

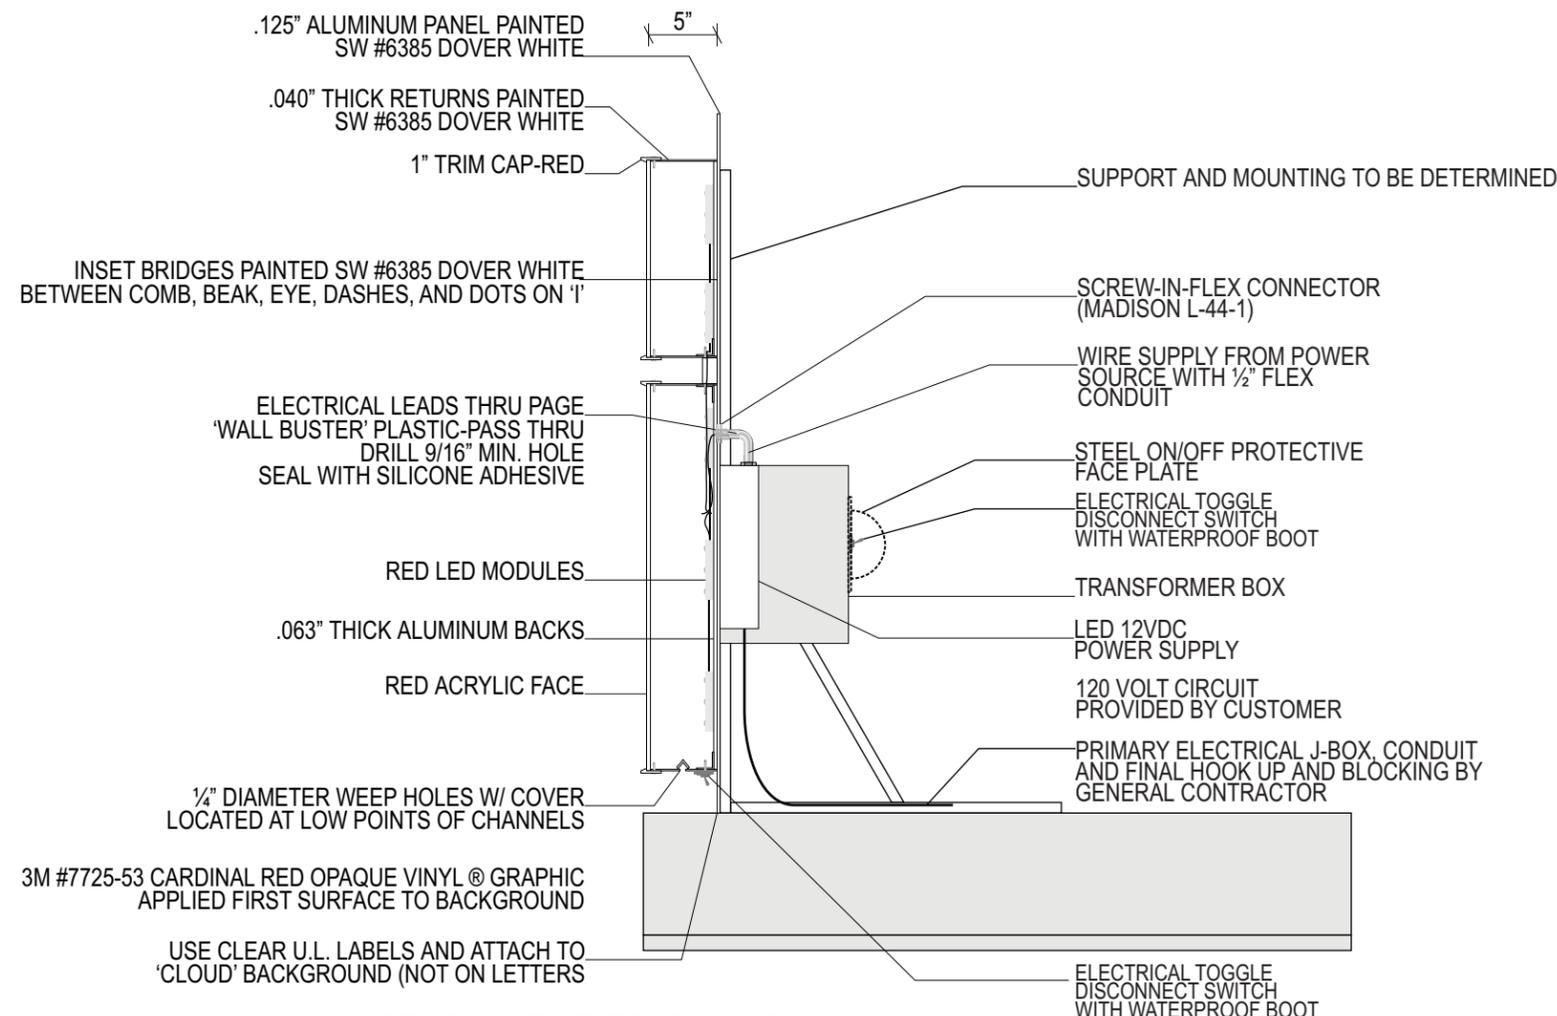

**ATTACHMENT TO CANOPY
 TO BE DETERMINED**

FASTENER SCHEDULE		
	#14 SELF TAPPING TEK FASTENER	FOR USE WITH PLYWOOD BACKED WOOD, STUCCO, OR EIFS WALL SYSTEM 1" MIN PENETRATION (EXCL. TIP)
	1/2" LAG SCREW	FOR USE WITH WOOD OR EIFS WALL SYSTEMS. 1 1/2" MIN PENETRATION (EXCL. TIP)
	1/4" DIA. THREADED ROD	FOR USE WITH WOOD, CONCRETE BLOCK OR EIFS WALL SYSTEMS.
	1/4" RED HEAD L.D.T (LARGE DIAMETER TOP CON)	FOR USE WITH CONCRETE BLOCK BRICK OR CONCRETE. EMBED A MIN OF 2 1/2"
	1/4" DIA HILTI HIT ROD WITH HY150 MAX ADHESIVE	FOR USE WITH CONCRETE EMBED A MIN OF 2"
	1/4" DIA HILTI HIT ROD WITH HY20 ADHESIVE	FOR USE WITH MASONRY AND BRICK EMBED A MIN OF 3 1/4"
	1/2" DIA HILTI HIT ROD WITH HY20 ADHESIVE	FOR USE WITH CONCRETE BLOCK EMBED A MIN OF 2"
	1/2" DIA HILTI HLC SLEEVE ANCHOR	FOR USE WITH CONCRETE, MASONRY AND BRICK EMBED A MIN OF 3 3/4"
INSTALLER SHALL VERIFY THAT THE FASTENERS CHOSEN ARE SUITABLE WITH WALL CONDITIONS		

A NEW 5'-0" ILLUM. "CHICK-FIL-A" CHANNEL LETTERS SIGN



AREA: 58.85 SQ. FT.
 AREA: 35.15 SQ. FT.
 8 STRAIGHT LINES
 ACTUAL AREA: 12.59 SQ. FT.



PERSPECTIVE VIEW

NEW 5'-0" ILLUM. "CHICK-FIL-A" CHANNEL LETTERS SIGN

Sign Specs:

BODY: S/F CUSTOM FABRICATED ALUMINUM CHANNEL LETTERS CONSTRUCTED OF .040 WITH .063 ALUMINUM BACKS. ALUMINUM RETURNS MECHANICALLY FASTENED TO BACKS. INTERIOR OF SIGN TO BE PAINTED MATTE WHITE.

FACES: 3/16" #2793 RED ACRYLIC.

TRIM CAP: 1" RED JEWELITE TRIM CAP

RETURNS: 5" DEEP RETURNS PAINTED TO MATCH MOUNTING SURFACE COLOR

STANDOFF: 1/4" SLEEVE ANCHORS WITH 1/2" ALUMINUM SPACERS.

REGISTERED: 3/16" CLEAR POLYCARBONATE DISK. 3M 3632-53 CARDINAL RED VINYL ® APPLIED FIRST SURFACE.

DISCONNECT: ELECTRICAL TOGGLE DISCONNECT SWITCH WITH LOCKING COVER WATERPROOF BOOT

ILLUMINATION: RED LED.

ALL WIRING & COMPONENTS TO MEET U.L. STANDARDS

CFA - 00002 - CFA LS 60 CHICK-FIL-A ILLUMINATED

Colors:

 R & H 2793 / 3M RED 3632-53

 RETURN COLOR



National Sign & Marketing Corporation
 13580 5th St., Chino, CA 91710
 Tel 909.591.4742 Fax 909.747.6446
 e-mail: sales@nsmc.com
 Lic# 745030 - Exp. 01/31/26

Project Name:
 Chick-fil-A
 #5934
 Powers & Palmer Park

Address:
 SEC Power Blvd. &
 Palmer Park Blvd.
 Colorado Springs, CO.

Account Mgr.
 Steve Rosenbloom

Approved by:

Date:

Drawing Number
31130R1

Revision
 02/21/25 TB: Update A to canopy mounted.
 add C. Fylon goes to addendum.

Designer: T.Behrman
Date: 01/10/2025

S/F LED ILLUMINATED
 CHANNEL LETTERS

Page 7

Scale: 1/2" = 1'-0"

THIS IS AN ORIGINAL UNPUBLISHED DRAWING CREATED FOR YOUR PERSONAL USE IN CONNECTION WITH A PROJECT PLANNED FOR YOU BY NSMC. IT IS NOT TO BE SHOWN OUTSIDE YOUR ORGANIZATION NOR USED, REPRODUCED, COPIED OR EXHIBITED IN ANY FASHION UNLESS AUTHORIZED IN WRITING BY AN OFFICER OF NSMC.

This sign intended to be in accordance with the requirements of Article 600 of the National Electrical Code and/or other applicable local codes. This includes proper grounding and bonding of this sign.




NOTE:

*GC TO SUPPLY PRIMARY POWER SOURCE ALL

*COMPONENTS TO BE U.L. LISTED AND APPROVED.

*THE LOCATION OF THE DISCONNECT SWITCH AFTER INSTALLATION SHALL COMPLY WITH ARTICLE 600.6(A) (1) OF THE NATIONAL ELECTRICAL CODE.

FASTENER SCHEDULE		
	#14 SELF TAPPING TEK FASTENER	FOR USE WITH PLYWOOD BACKED WOOD, STUCCO, OR EIFS WALL SYSTEM 1" MIN PENETRATION (EXCL. TIP)
	1/2" LAG SCREW	FOR USE WITH WOOD OR EIFS WALL SYSTEMS. 1 1/2" MIN PENETRATION (EXCL. TIP)
	1/4" DIA. THREADED ROD	FOR USE WITH WOOD, CONCRETE BLOCK OR EIFS WALL SYSTEMS.
	1/4" RED HEAD L.D.T (LARGE DIAMETER TOP CON)	FOR USE WITH CONCRETE BLOCK BRICK OR CONCRETE. EMBED A MIN OF 2 1/2"
	1/4" DIA HILTI HIT ROD WITH HY150 MAX ADHESIVE	FOR USE WITH CONCRETE EMBED A MIN OF 2"
	1/4" DIA HILTI HIT ROD WITH HY20 ADHESIVE	FOR USE WITH MASONRY AND BRICK EMBED A MIN OF 3 1/4"
	1/4" DIA HILTI HIT ROD WITH HY20 ADHESIVE	FOR USE WITH CONCRETE BLOCK EMBED A MIN OF 2"
	1/4" DIA HILTI HLC SLEEVE ANCHOR	FOR USE WITH CONCRETE, MASONRY AND BRICK EMBED A MIN OF 3 1/4"
INSTALLER SHALL VERIFY THAT THE FASTENERS CHOSEN ARE SUITABLE WITH WALL CONDITIONS		

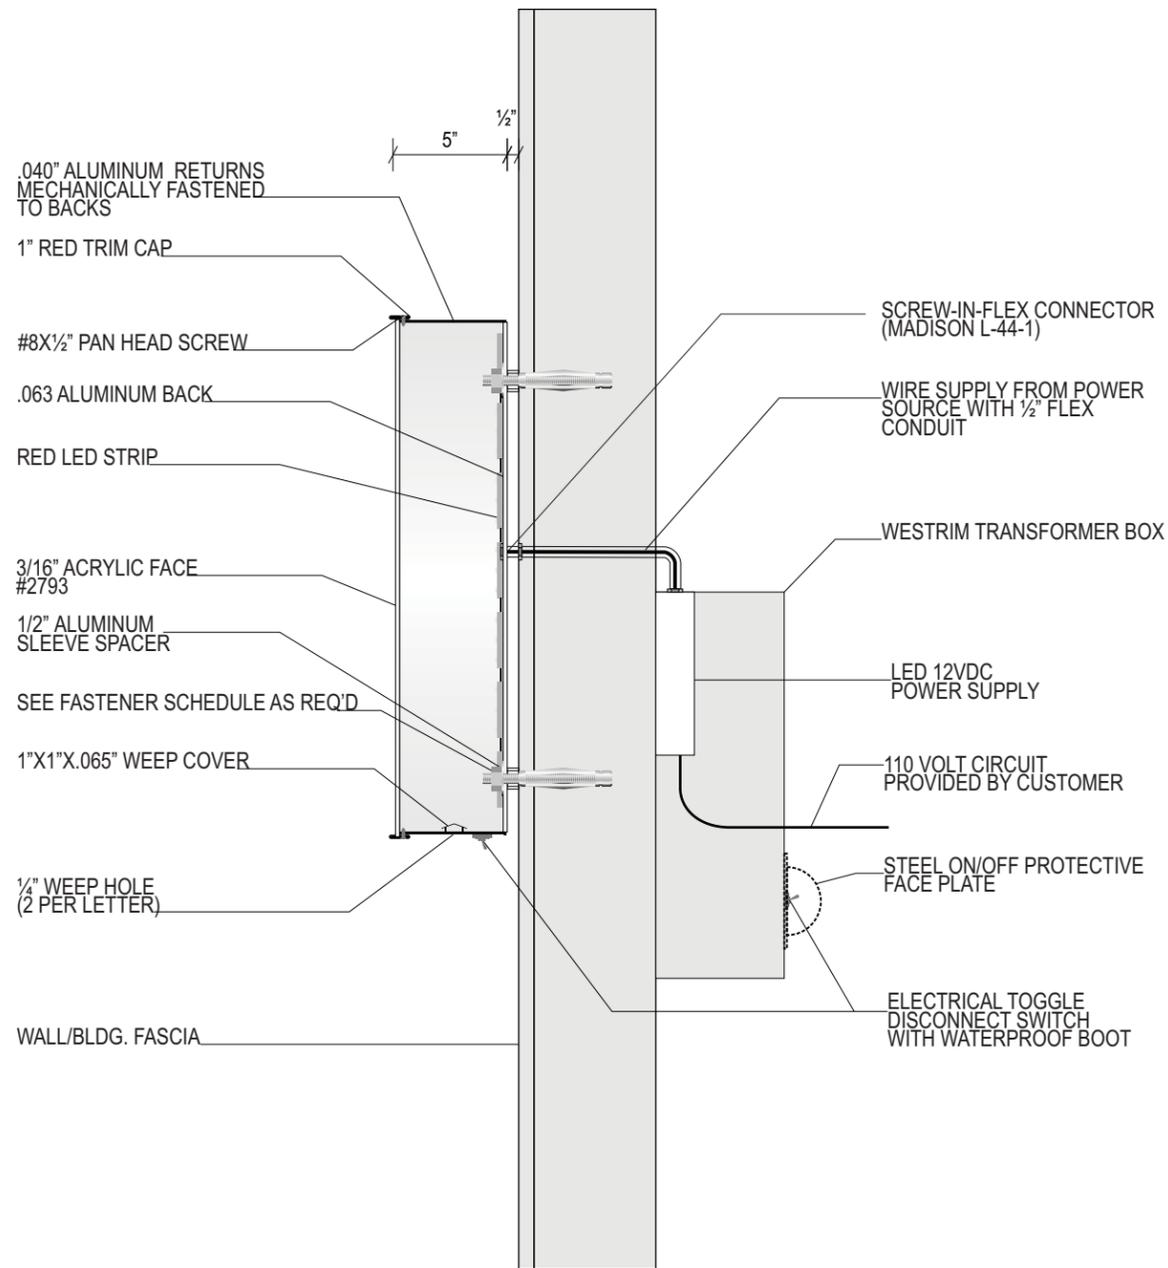

 NEW 5'-0" ILLUM. "CHICK-FIL-A" CHANNEL LETTERS SIGN



National Sign & Marketing Corporation
 13580 5th St., Chino, CA 91710
 Tel 909.591.4742 Fax 909.747.6446
 e-mail: sales@nsmc.com
 Lic# 745030 - Exp. 01/31/26

Project Name:
 Chick-fil-A
 #5934
 Powers & Palmer Park

Address:
 SEC Power Blvd. &
 Palmer Park Blvd.
 Colorado Springs, CO.

Account Mgr.
 Steve Rosenbloom

Approved by:

Date:

Drawing Number
 31130R1

Revision

02/21/25 TB: Update A to canopy mounted, add C. Pylon goes to addendum.

Designer: T.Behrman
Date: 01/10/2025

**SECTION
 DETAIL**


Page 9

Scale: NTS


THIS IS AN ORIGINAL UNPUBLISHED DRAWING CREATED FOR YOUR PERSONAL USE IN CONNECTION WITH A PROJECT PLANNED FOR YOU BY NSMC. IT IS NOT TO BE SHOWN OUTSIDE YOUR ORGANIZATION NOR USED, REPRODUCED, COPIED OR EXHIBITED IN ANY FASHION UNLESS AUTHORIZED IN WRITING BY AN OFFICER OF NSMC

This sign intended to be in accordance with the requirements of Article 600 of the National Electrical Code and/or other applicable local codes. This includes proper grounding and bonding of this sign.




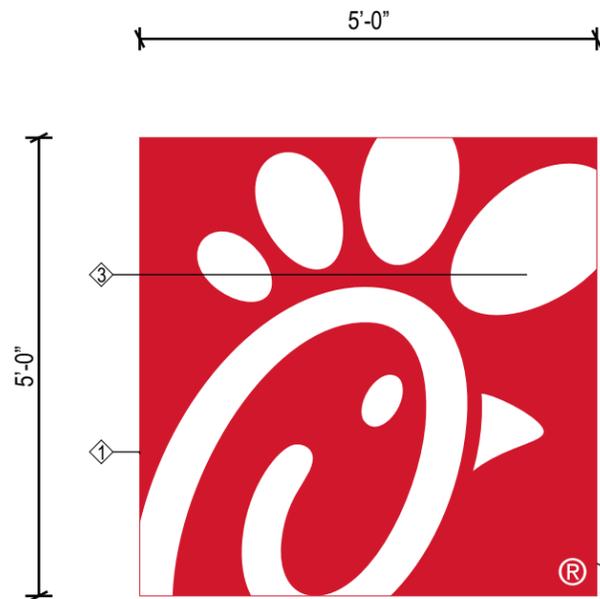


FACE VIEW
AREA: 25.00 SQ. FT.

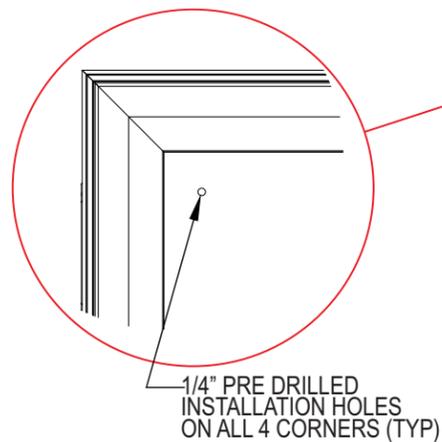


1/4" PRE DRILLED
INSTALLATION HOLES
ON ALL 4 CORNERS (TYP)

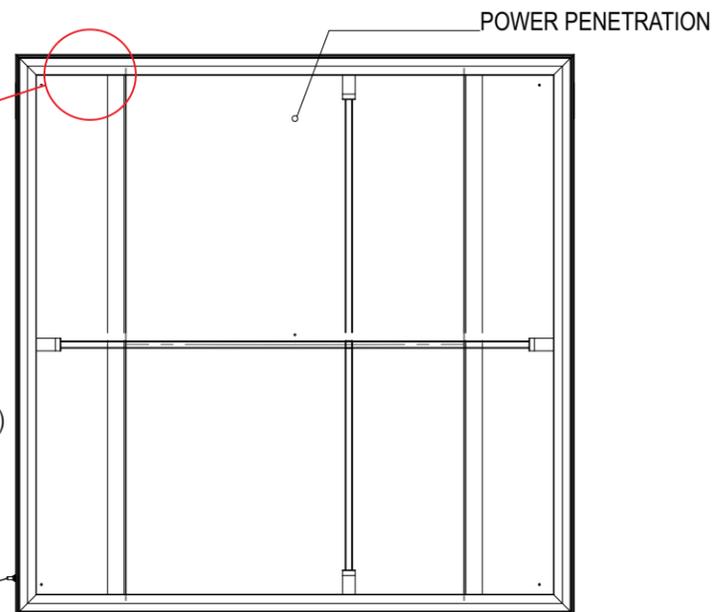


FRAME VIEW

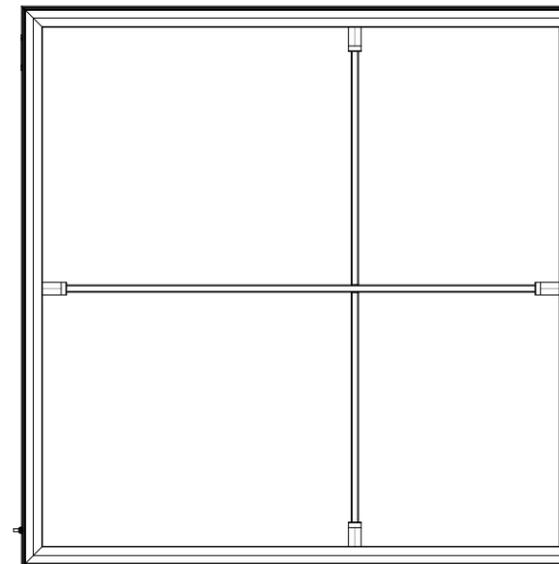


BRACE SUPPORT VIEW

 


SECTION VIEW

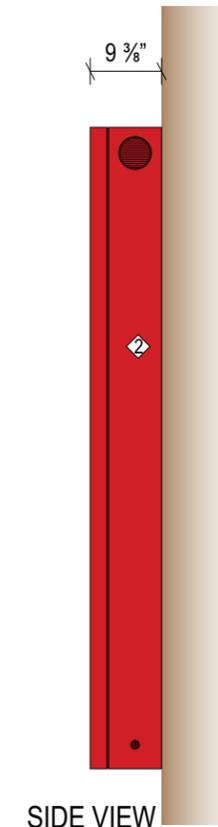

SIDE VIEW

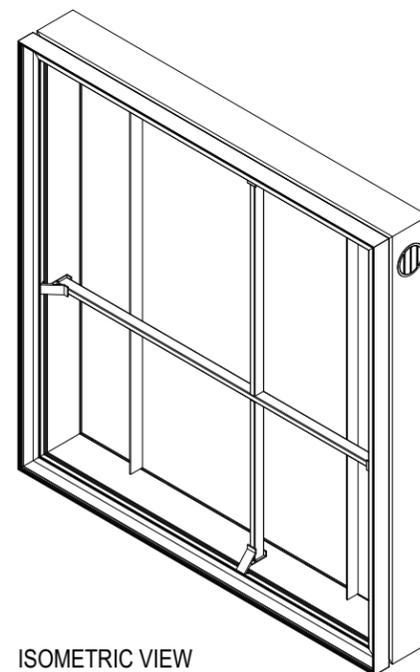

ISOMETRIC VIEW

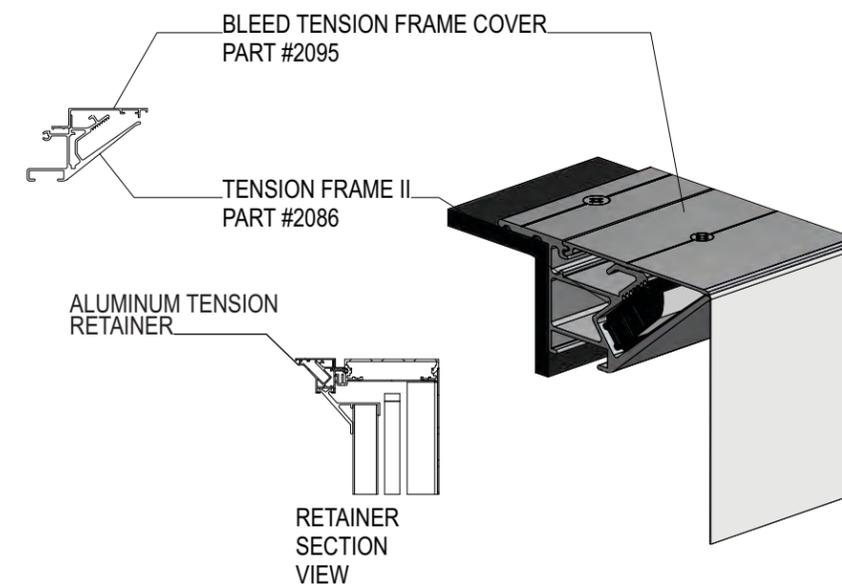

BLEED TENSION FRAME COVER
PART #2095

TENSION FRAME II
PART #2086

ALUMINUM TENSION
RETAINER

RETAINER
SECTION
VIEW

B C NEW 5'-0" ILLUM. "CHICK-FIL-A" ICON LOGO CABINET

Sign Specs:

CABINET: SIGNCOMP #2025 SINGLE FACE BODY PAINTED MATTHEWS RED MP10252.
 FACES: WHITE BLEED FLEX SUBSTRATE WITH CARDINAL RED #3632-53 TRANSLUCENT VINYL FIRST SURFACE OVERLAY WITH WHITE SHOW THRU.
 RETAINER: SIGNCOMP #2095 BLEED TENSION FRAME COVER PAINTED MATHEWS RED MP 10252.
 RETURNS: 9 3/8" DEEP ALUMINUM RETURN PAINTED MATHEWS RED MP 10252.
 ILLUMINATION: WHITE 6500K LED.

DISCONNECT: ELECTRICAL TOGGLE DISCONNECT SWITCH WITH BOOT

ALL WIRING & COMPONENTS TO MEET U.L. STANDARDS

CFA - 00011 - CFA WS 60X60 ICON LOGO ILLUMINATED

Colors:

- 1 3M VINYL #3632-53
- 2 MATHEWS RED MP 10252 SEMI-GLOSS
- 3 WHITE FLEXIBLE SUBSTRATE



National Sign & Marketing Corporation
 13580 5th St., Chino, CA 91710
 Tel 909.591.4742 Fax 909.747.6446
 e-mail: sales@nsmc.com
 Lic# 745030 - Exp. 01/31/26

Project Name:

Chick-fil-A
 #5934
 Powers & Palmer Park

Address:

SEC Power Blvd. &
 Palmer Park Blvd.
 Colorado Springs, CO.

Account Mgr.

Steve Rosenbloom

Approved by:

Date:

Drawing Number

31130R1

Revision

02/21/25 TB: Update A to canopy mounted.
 add C - Fylon goes to addendum.

Designer: T Behrman
Date: 01/10/2025

**NEW
 S/F ILLUMINATED
 ICON LOGO CABINET**

Page 10

Scale: 1/2" = 1'-0"

THIS IS AN ORIGINAL UNPUBLISHED DRAWING CREATED FOR YOUR PERSONAL USE IN CONNECTION WITH A PROJECT PLANNED FOR YOU BY NSMC. IT IS NOT TO BE SHOWN OUTSIDE YOUR ORGANIZATION NOR USED, REPRODUCED, COPIED OR EXHIBITED IN ANY FASHION UNLESS AUTHORIZED IN WRITING BY AN OFFICER OF NSMC.

This sign intended to be in accordance with the requirements of Article 600 of the National Electrical Code and/or other applicable local codes. This includes proper grounding and bonding of this sign.





National Sign & Marketing Corporation
 13580 5th St., Chino, CA 91710
 Tel 909.591.4742 Fax 909.747.6446
 e-mail: sales@nsmc.com
 Lic# 745030 - Exp. 01/31/26

Project Name:
 Chick-fil-A
 #5934
 Powers & Palmer Park

Address:
 SEC Power Blvd. &
 Palmer Park Blvd.
 Colorado Springs, CO.

Account Mgr.
 Steve Rosenbloom

Approved by:

Date:

Drawing Number
31130R1

Revision
 02/21/25 TB: Update A to canopy mounted.
 add C. Pylon goes to addendum.

Designer: T Behrman
Date: 01/10/2025


LED
 LAYOUT

Page 11

Scale: NTS

THIS IS AN ORIGINAL UNPUBLISHED DRAWING CREATED FOR YOUR PERSONAL USE IN CONNECTION WITH A PROJECT PLANNED FOR YOU BY NSMC. IT IS NOT TO BE SHOWN OUTSIDE YOUR ORGANIZATION NOR USED, REPRODUCED, COPIED OR EXHIBITED IN ANY FASHION UNLESS AUTHORIZED IN WRITING BY AN OFFICER OF NSMC.

This sign intended to be in accordance with the requirements of Article 600 of the National Electrical Code and/or other applicable local codes. This includes proper grounding and bonding of this sign.

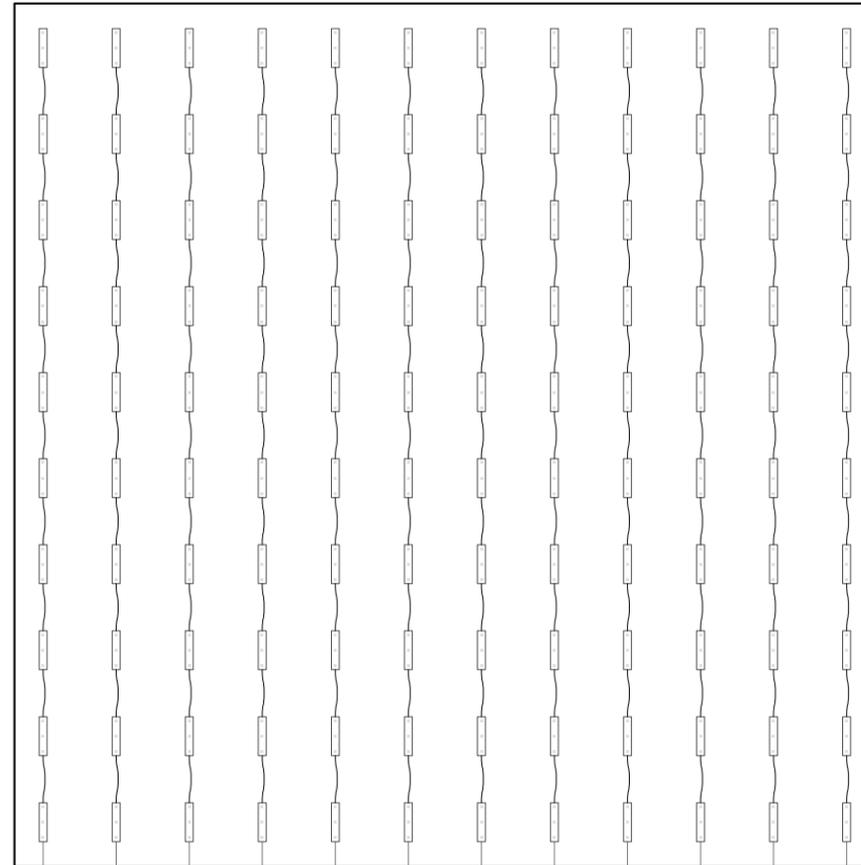

Load: 67.5%
 Modules: 120
 Watts: 129.6 of 192.0

120

120 MODULES - 3 GOQ 3WS108-6500 *SHALLOW* WHITE 6500KELVIN 1.08
 129.6 WATTS
 1 POWER SUPPLY: HLG-240H-12 POWER SUPPLY MEAN WELL
 4.0 AMPS
 1 - 20 amp circuit 120v

B C NEW 5'-0" ILLUM. "CHICK-FIL-A" ICON LOGO CABINET


Component / Manufacture	Model:	Rating:	Comments,
Led Wire / Paige	98P183M	18 Awg, 600v	U.L. Listed
Led Wire / Paige	984182M	18 Awg, 600v	U.L. Listed
Wire Nuts / Ideal	71B,72B	300V	U.L. Listed
Wire Nuts / Ideal	73B,74B,75B	600V	U.L. Listed
Scotchlok/3M	Tap Connector 560	600V	U.L. Listed
Wire / Southwire	THHN12	12 Awg, 600v	U.L. Listed
Polycarbonate/Palram Americas	Palsun CS	Rigid Sign Face Material	U.L. R/C
Toggle Switch w-Boot/ Ventex	84675	20amp, 120-277v	U.L. R/C

NOTE:


*GC TO SUPPLY PRIMARY POWER SOURCE ALL

*COMPONENTS TO BE U.L. LISTED AND APPROVED.

*THE LOCATION OF THE DISCONNECT SWITCH AFTER INSTALLATION SHALL COMPLY WITH ARTICLE 600.6(A) (1) OF THE NATIONAL ELECTRICAL CODE.

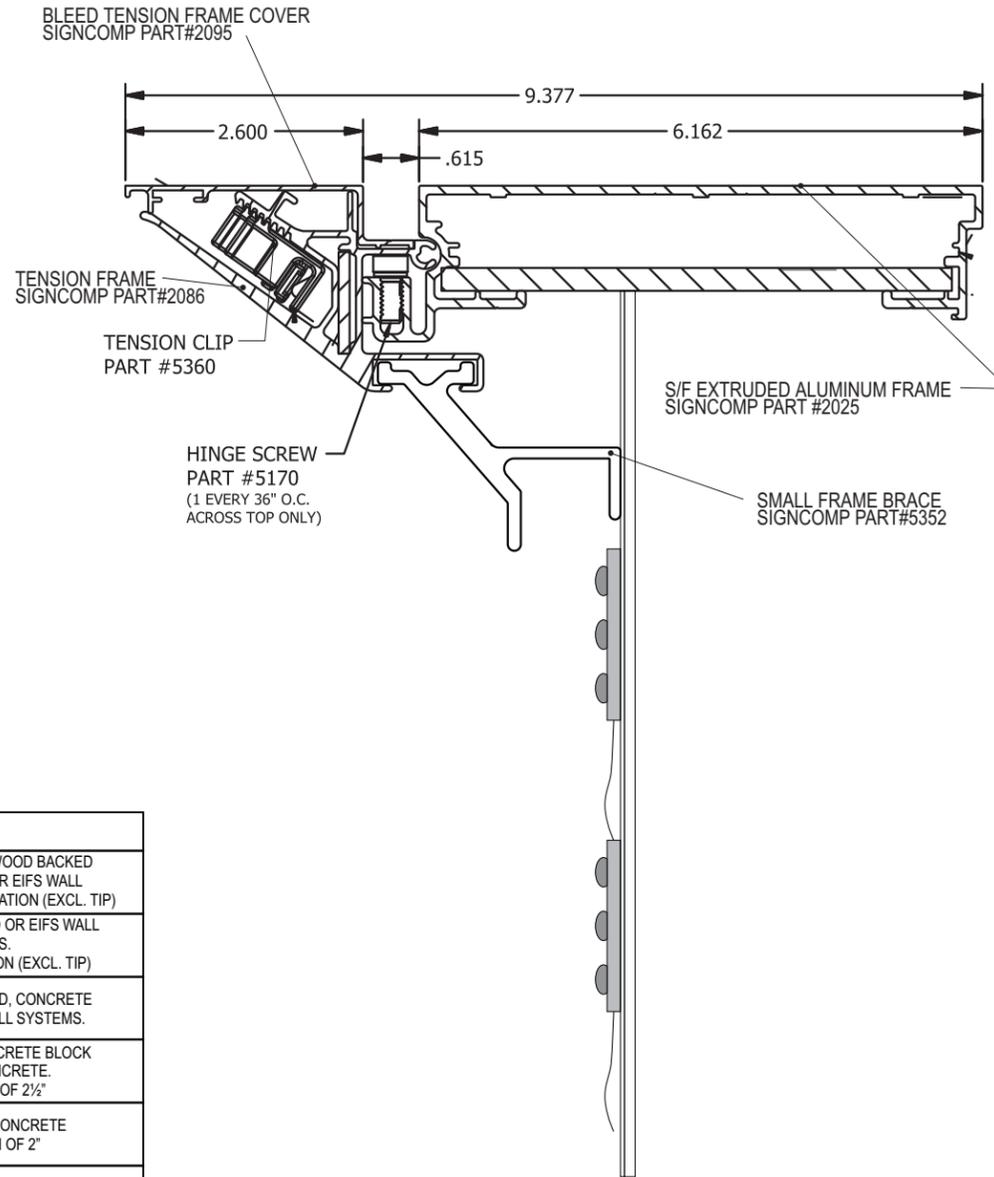

SECTION DETAIL

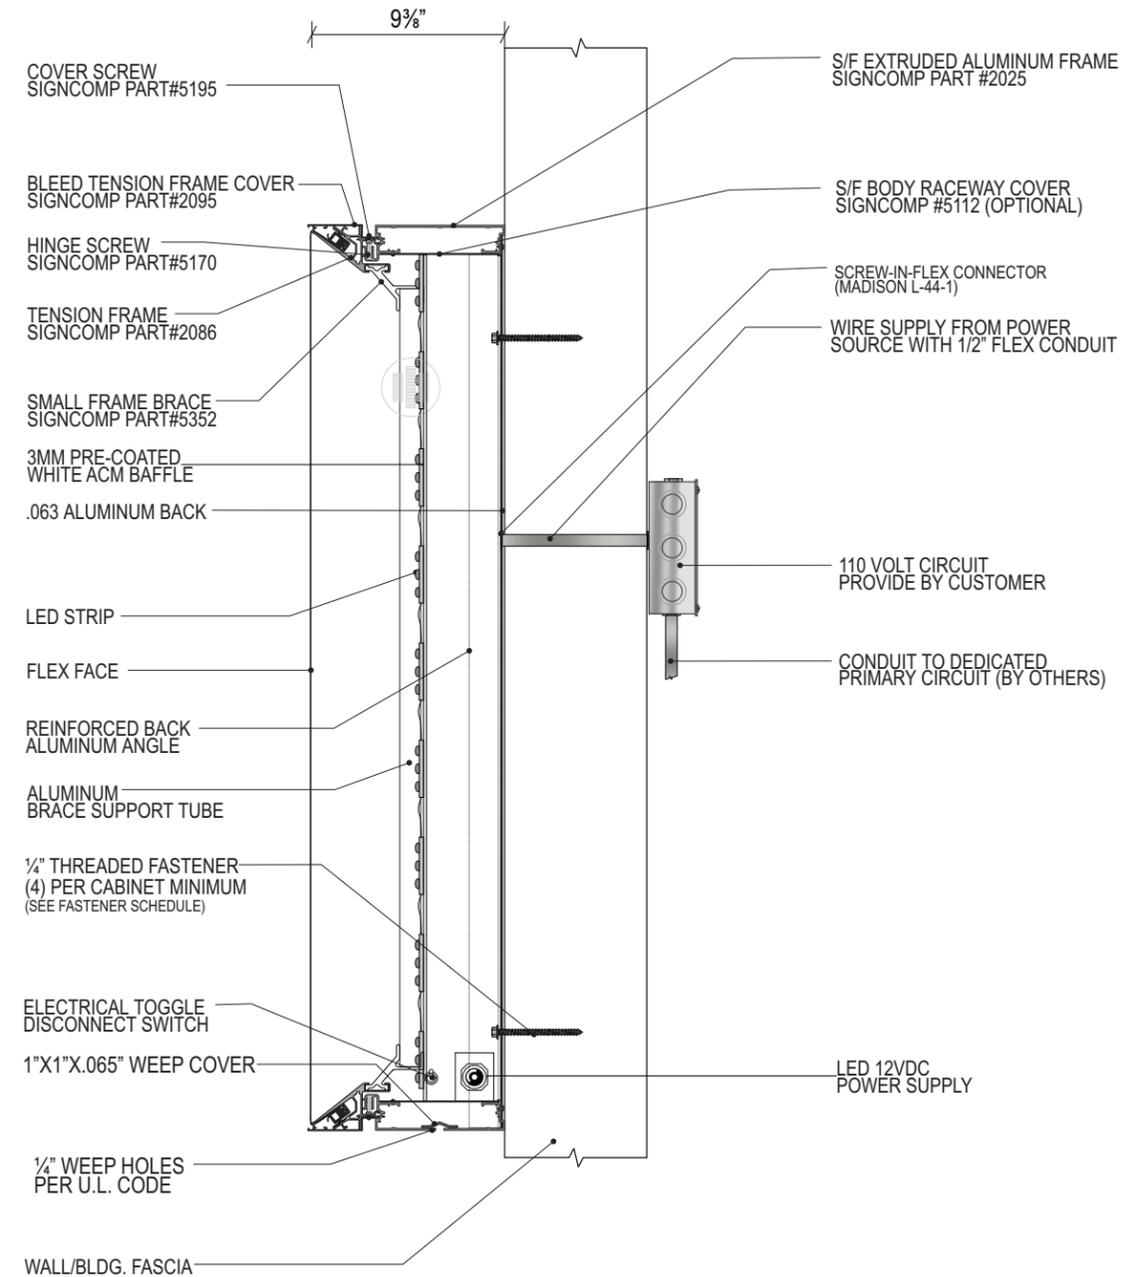

FASTENER SCHEDULE

FASTENER	DESCRIPTION	APPLICATION
	#14 SELF TAPPING TEK FASTENER	FOR USE WITH PLYWOOD BACKED WOOD, STUCCO, OR EIFS WALL SYSTEM 1" MIN PENETRATION (EXCL. TIP)
	1/2" LAG SCREW	FOR USE WITH WOOD OR EIFS WALL SYSTEMS. 1 1/2" MIN PENETRATION (EXCL. TIP)
	1/4" DIA. THREADED ROD	FOR USE WITH WOOD, CONCRETE BLOCK OR EIFS WALL SYSTEMS.
	1/4" RED HEAD L.D.T (LARGE DIAMETER TOP CON)	FOR USE WITH CONCRETE BLOCK BRICK OR CONCRETE. EMBED A MIN OF 2 1/2"
	1/4" DIA HILTI HIT ROD WITH HY150 MAX ADHESIVE	FOR USE WITH CONCRETE EMBED A MIN OF 2"
	1/4" DIA HILTI HIT ROD WITH HY20 ADHESIVE	FOR USE WITH MASONRY AND BRICK EMBED A MIN OF 3 3/4"
	1/4" DIA HILTI HIT ROD WITH HY20 ADHESIVE	FOR USE WITH CONCRETE BLOCK EMBED A MIN OF 2"
	1/4" DIA HILTI HLC SLEEVE ANCHOR	FOR USE WITH CONCRETE, MASONRY AND BRICK EMBED A MIN OF 3 3/4"

INSTALLER SHALL VERIFY THAT THE FASTENERS CHOSEN
ARE SUITABLE WITH WALL CONDITIONS

B C NEW 5'-0" ILLUM. "CHICK-FIL-A" ICON LOGO CABINET



National Sign & Marketing Corporation
13580 5th St., Chino, CA 91710
Tel 909.591.4742 Fax 909.747.6446
e-mail: sales@nsmc.com
Lic# 745030 - Exp. 01/31/26

Project Name:
Chick-fil-A
#5934
Powers & Palmer Park

Address:
SEC Power Blvd. &
Palmer Park Blvd.
Colorado Springs, CO.

Account Mgr.
Steve Rosenbloom

Approved by:

Date:

Drawing Number
31130R1

Revision

02/21/25 TB: Update A to canopy mounted.
add C. Fylon goes to addendum.

Designer: T Behrman
Date: 01/10/2025

**SECTION
DETAIL**

Page 12

Scale: NTS

THIS IS AN ORIGINAL UNPUBLISHED
DRAWING CREATED FOR YOUR PERSONAL
USE IN CONNECTION WITH A PROJECT
PLANNED FOR YOU BY NSMC. IT IS NOT TO BE
SHOWN OUTSIDE YOUR ORGANIZATION NOR
USED, REPRODUCED, COPIED OR EXHIBITED
IN ANY FASHION UNLESS AUTHORIZED IN
WRITING BY AN OFFICER OF NSMC

This sign intended to be in accordance with
the requirements of Article 600 of the
National Electrical Code and/or other
applicable local codes. This includes proper
grounding and bonding of this sign.



NOTE:

*GC TO SUPPLY PRIMARY POWER SOURCE ALL

*COMPONENTS TO BE U.L. LISTED AND APPROVED.

*THE LOCATION OF THE DISCONNECT SWITCH AFTER INSTALLATION SHALL COMPLY WITH ARTICLE 600.6(A) (1) OF THE NATIONAL ELECTRICAL CODE.



National Sign & Marketing Corporation
 13580 5th St., Chino, CA 91710
 Tel 909.591.4742 Fax 909.747.6446
 e-mail: sales@nsmc.com
 Lic# 745030 - Exp. 01/31/26

Project Name:
 Chick-fil-A
 #5934
 Powers & Palmer Park

Address:
 SEC Power Blvd. &
 Palmer Park Blvd.
 Colorado Springs, CO.

Account Mgr.
 Steve Rosenbloom

Approved by:

Date:

Drawing Number
 31130R1

Revision

02/21/25 TB: Update A to canopy mounted, add C. Pylon goes to addendum.

Designer: T Behrman
Date: 01/10/2025

NEW & REINVESTMENT DIRECTIONAL ENTRY SIGN

Page 13

Scale: 3/4" = 1'-0"

THIS IS AN ORIGINAL UNPUBLISHED DRAWING CREATED FOR YOUR PERSONAL USE IN CONNECTION WITH A PROJECT PLANNED FOR YOU BY NSMC. IT IS NOT TO BE SHOWN OUTSIDE YOUR ORGANIZATION NOR USED, REPRODUCED, COPIED OR EXHIBITED IN ANY FASHION UNLESS AUTHORIZED IN WRITING BY AN OFFICER OF NSMC.

This sign intended to be in accordance with the requirements of Article 600 of the National Electrical Code and/or other applicable local codes. This includes proper grounding and bonding of this sign.



D NEW D/F ILLUM. DIRECTIONAL SIGN



E NEW D/F ILLUM. DIRECTIONAL SIGN

3" 8 3/4" 2" 1'-2 3/4" 3"



TEXT IS CENTERED VERTICALLY & HORIZONTALLY WITHIN ALLOTTED AREA

2'-7 1/2"

2'-5 1/2"



EXTRUDED ALUMINUM SIGN CABINET INTERNALLY W/ WHITE LED

3/16" #7328 WHITE ACRYLIC WITH FIRST SURFACE APPLIED 3M 3630-3015-069 DURONODIC TRANSLUCENT VINYL

4" X 4" STEEL TUBE

SIGN AREA = 3.06 ft²
 LOGO 1.44 ft² = 47.05% of face

9"

2" DIA. VENT ON BOTH SIDES
 CLEAR POLYCARBONATE BAFFLE IN CENTER FOR LEDS
 ELECTRICAL TOGGLE DISCONNECT SWITCH WITH BOOT

Apercu Bold 380 pt size/340 point leading
 -20 Tracking and Optical Kerning
 CFA - 00764 - CFA DRIVE THRU DIRECTIONAL 18X24 BRONZE&WHITE

Sign Specs:

CABINETS: EXTRUDED ALUMINUM 9" DEEP. PAINTED DARK BRONZE.
FACES: WHITE #7328 ACRYLIC WITH APPLIED FIRST SURFACE 3M 3630-3015-069 DURONODIC TRANSLUCENT VINYL. RETAINERS TO BE 1".
POST: 4"X4" SQUARE STEEL TUBE WITH MATCH PLATE POLE PAINTED BRONZE METALLIC.
ILLUMINATION: WHITE 6500K LED.
SWITCH: ELECTRICAL TOGGLE DISCONNECT SWITCH WITH BOOT

NOTE: TRY TO KEEP DIRECTIONALS 5'-0" FROM CURBS WHEREVER POSSIBLE TO INSURE VEHICLES WILL NOT HIT THEM.
 ALL COMPONENTS TO BE U.L. APPROVED

Colors:

1 3M-3630-3015-069 DURONODIC
 2 MP 20181 EQUUS BRONZE METALLIC
 3 WHITE / #7328 ACRYLIC



National Sign & Marketing Corporation
 13580 5th St., Chino, CA 91710
 Tel 909.591.4742 Fax 909.747.6446
 e-mail: sales@nsmc.com
 Lic# 745030 - Exp. 01/31/26

Project Name:
 Chick-fil-A
 #5934
 Powers & Palmer Park

Address:
 SEC Power Blvd. &
 Palmer Park Blvd.
 Colorado Springs, CO.

Account Mgr.
 Steve Rosenbloom

Approved by:

Date:

Drawing Number
31130R1

Revision

02/21/25 TB: Update A to canopy mounted, add C. Pylon goes to addendum.

Designer: T.Behrman
Date: 01/10/2025


LED LAYOUT

Page 14

Scale: NTS

THIS IS AN ORIGINAL UNPUBLISHED DRAWING CREATED FOR YOUR PERSONAL USE IN CONNECTION WITH A PROJECT PLANNED FOR YOU BY NSMC. IT IS NOT TO BE SHOWN OUTSIDE YOUR ORGANIZATION NOR USED, REPRODUCED, COPIED OR EXHIBITED IN ANY FASHION UNLESS AUTHORIZED IN WRITING BY AN OFFICER OF NSMC.

This sign intended to be in accordance with the requirements of Article 600 of the National Electrical Code and/or other applicable local codes. This includes proper grounding and bonding of this sign.

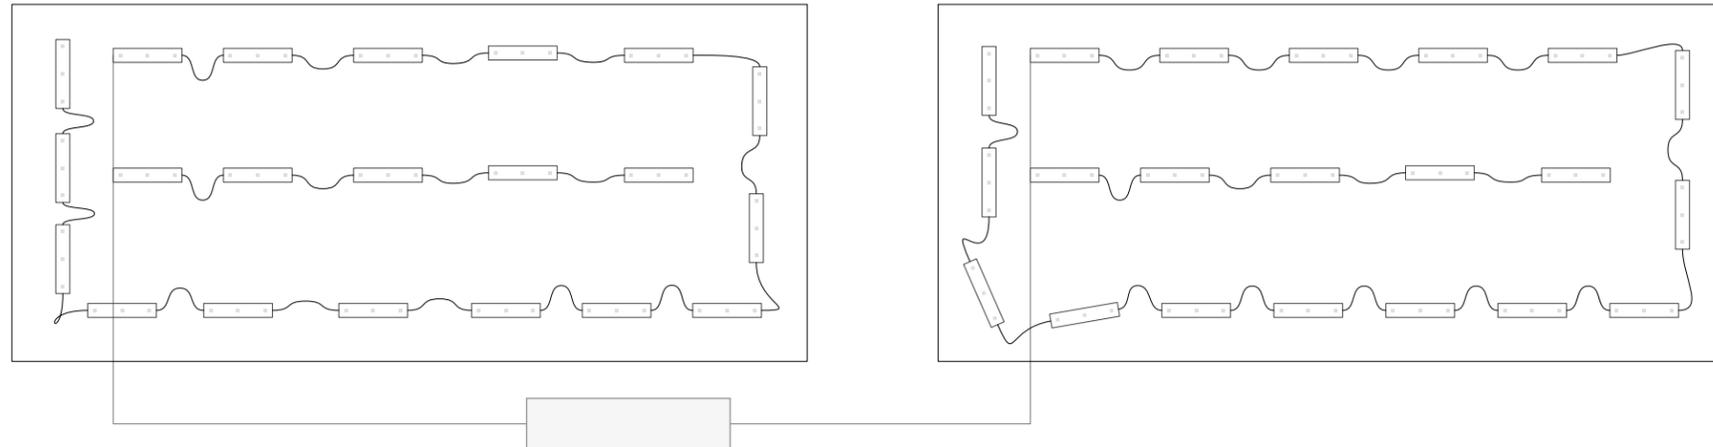

Load: 50.3
 Modules: 42
 Watts: 30.2 of 60.0
 PS: Meanwell60w

42 MODULES - 3 GOQ 3WCO72-6500 WHITE 6500KELVIN .72
 30.2 WATTS
 1 POWER SUPPLY: LPV-60-12 POWER SUPPLY MEAN WELL
 1.2 AMPS
 1- 20 AMP 120V CIRCUIT





D E NEW D/F ILLUM. DIRECTIONAL SIGN

Component / Manufacture	Model:	Rating:	Comments,
Led Wire / Paige	98P183M	18 Awg, 600v	U.L. Listed
Led Wire / Paige	984182M	18 Awg, 600v	U.L. Listed
Wire Nuts / Ideal	71B,72B	300V	U.L. Listed
Wire Nuts / Ideal	73B,74B,75B	600V	U.L. Listed
Scotchlok/3M	Tap Connector 560	600V	U.L. Listed
Wire / Southwire	THHN12	12 Awg, 600v	U.L. Listed
Polycarbonate/Palram Americas	Palsun CS	Rigid Sign Face Material	U.L. R/C
Toggle Switch w-Boot/ Ventex	84675	20amp, 120-277v	U.L. R/C




COLOR AND COPY DETAIL:
 ALL EXTERIOR PAINTS TO HAVE SEMI-GLOSS FINISH,
 WITH THE EXCEPTION OF MATTE BLACK.

RENDERING AND GRAPHICS COLORS ARE FOR
 REFERENCE ONLY. ALL MATERIALS AND COPY
 SHOULD BE MANUFACTURED TO
 SPECIFICATIONS ON PREVIOUS PAGE

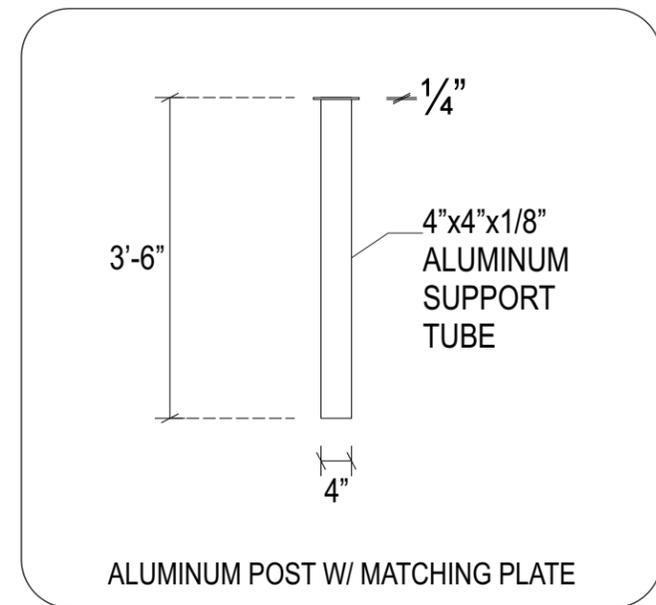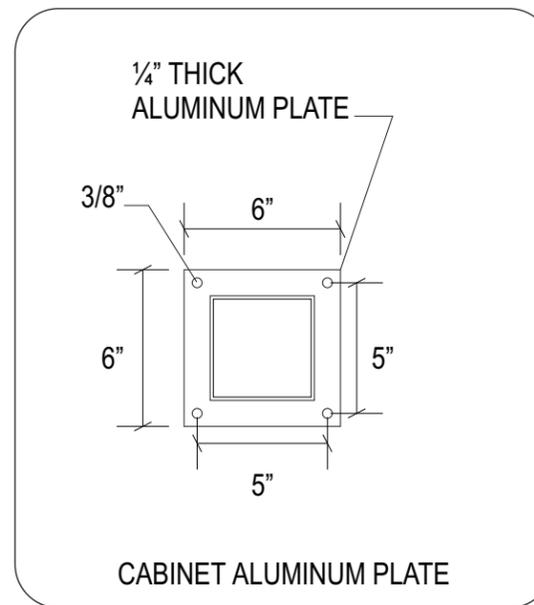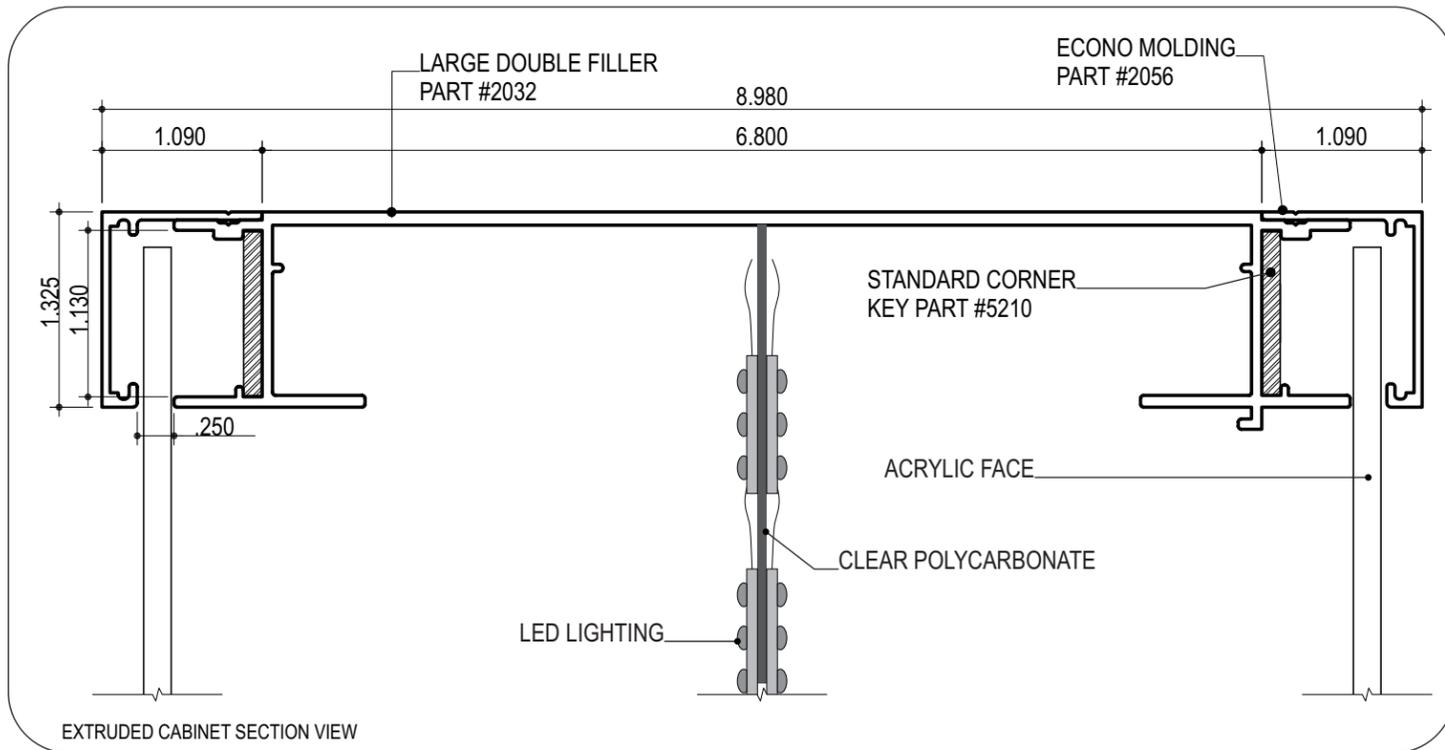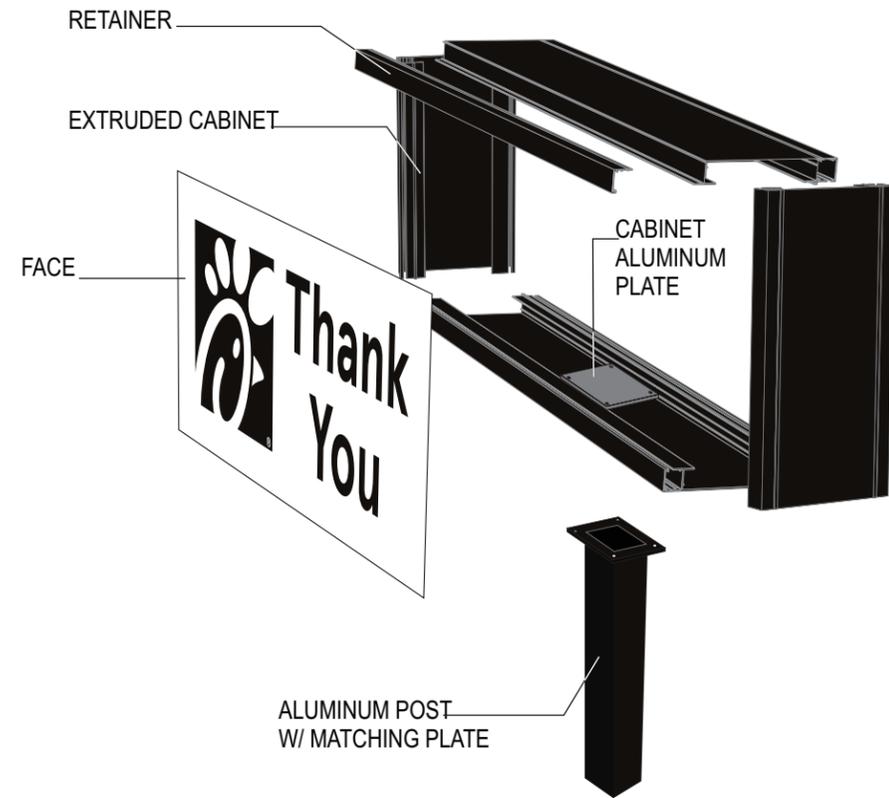

SURVEY REQUIRED PRIOR TO MANUFACTURE

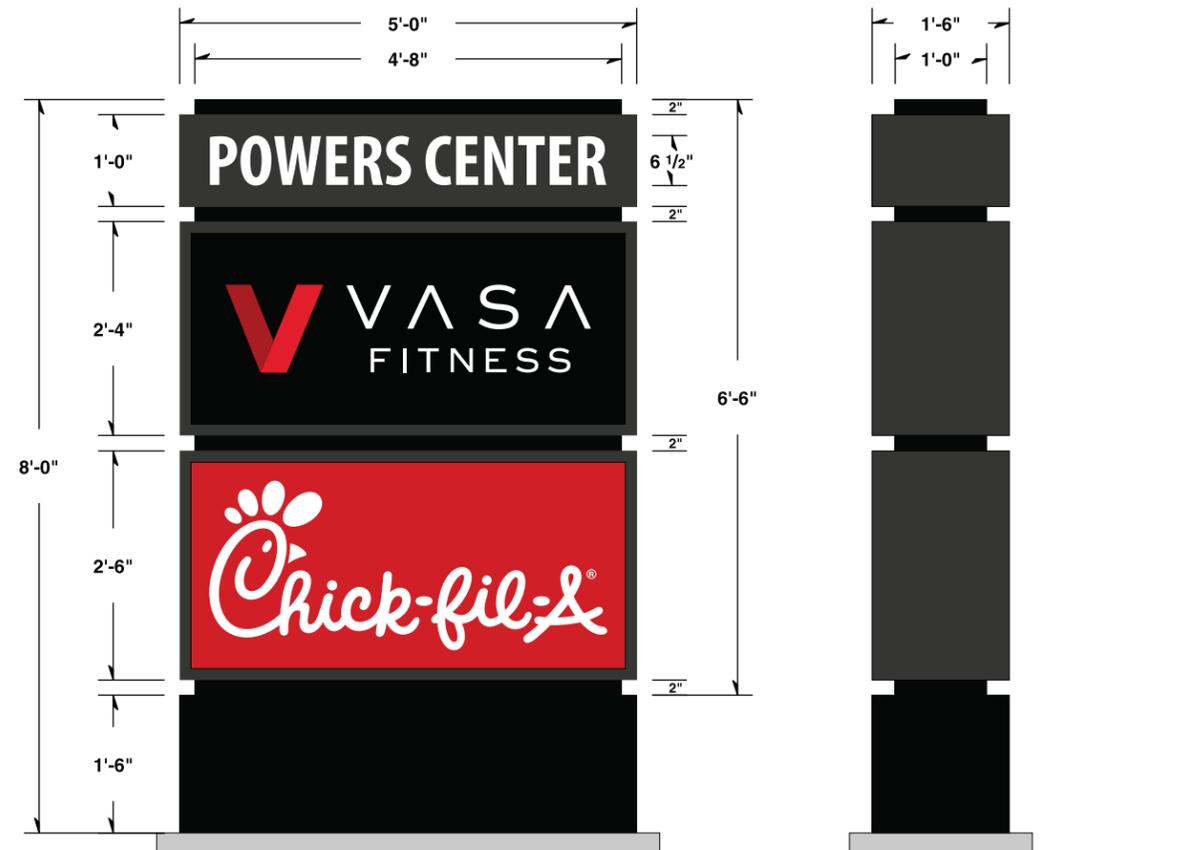

SCALE: 1/2" = 1'-0"

G EXIST. D/F ILLUM. MONUMENT SIGN, TENANT PANEL ONLY

Sign Specs:

MAIN CABINET:	EXISTING
FACES:	WHITE ACRYLIC WITH APPLIED FIRST SURFACE 3M RED #3632-53 TRANSLUCENT VINYL.
ILLUMINATION:	EXISTING
SWITCH:	EXISTING

ALL COMPONENTS TO BE U.L. APPROVED

Colors:

	3M RED 3632-53
	MATTHEWS MP 74155 SV SATIN DARK BRONZE
	7328 WHITE ACRYLIC
	FINISHING MATERIAL



National Sign & Marketing Corporation
 13580 5th St., Chino, CA 91710
 Tel 909.591.4742 Fax 909.747.6446
 e-mail: sales@nsmc.com
 Lic# 745030 - Exp. 01/31/26

Project Name:

Chick-fil-A
 #5934
 Powers & Palmer Park

Address:

SEC Power Blvd. &
 Palmer Park Blvd.
 Colorado Springs, CO.

Account Mgr.

Steve Rosenbloom

Approved by:

Date:

Drawing Number
31130R1

Revision

02/21/25 TB: Update A to canopy mounted, add C. Pylon goes to addendum.

Designer: T Behrman
 Date: 01/10/2025

REFACE
 D/F ILLUMINATED
 PYLON/MONUMENT SIGN

Page 16

Scale: 3/4" = 1'-0"

THIS IS AN ORIGINAL UNPUBLISHED DRAWING CREATED FOR YOUR PERSONAL USE IN CONNECTION WITH A PROJECT PLANNED FOR YOU BY NSMC. IT IS NOT TO BE SHOWN OUTSIDE YOUR ORGANIZATION NOR USED, REPRODUCED, COPIED OR EXHIBITED IN ANY FASHION UNLESS AUTHORIZED IN WRITING BY AN OFFICER OF NSMC.

This sign intended to be in accordance with the requirements of Article 600 of the National Electrical Code and/or other applicable local codes. This includes proper grounding and bonding of this sign.





National Sign & Marketing Corporation
 13580 5th St., Chino, CA 91710
 Tel 909.591.4742 Fax 909.747.6446
 e-mail: sales@nsmc.com
 Lic# 745030 - Exp. 01/31/26

Project Name:

Chick-fil-A
 #5934
 Powers & Palmer Park

Address:

SEC Power Blvd. &
 Palmer Park Blvd.
 Colorado Springs, CO.

Account Mgr.

Steve Rosenbloom

Approved by:

Date:

Drawing Number

31130R1

Revision

02/21/25 TB: Update A to canopy mounted.
 add C. Pylon goes to addendum.

Designer:

T Behrman

Date:

01/10/2025



**NEW
 NON-ILLUMINATED
 SINTRA ADDRESS
 NUMERALS**

Page 17

Scale: 3" = 1'-0"

THIS IS AN ORIGINAL UNPUBLISHED DRAWING CREATED FOR YOUR PERSONAL USE IN CONNECTION WITH A PROJECT PLANNED FOR YOU BY NSMC. IT IS NOT TO BE SHOWN OUTSIDE YOUR ORGANIZATION NOR USED, REPRODUCED, COPIED OR EXHIBITED IN ANY FASHION UNLESS AUTHORIZED IN WRITING BY AN OFFICER OF NSMC.

This sign intended to be in accordance with the requirements of Article 600 of the National Electrical Code and/or other applicable local codes. This includes proper grounding and bonding of this sign.

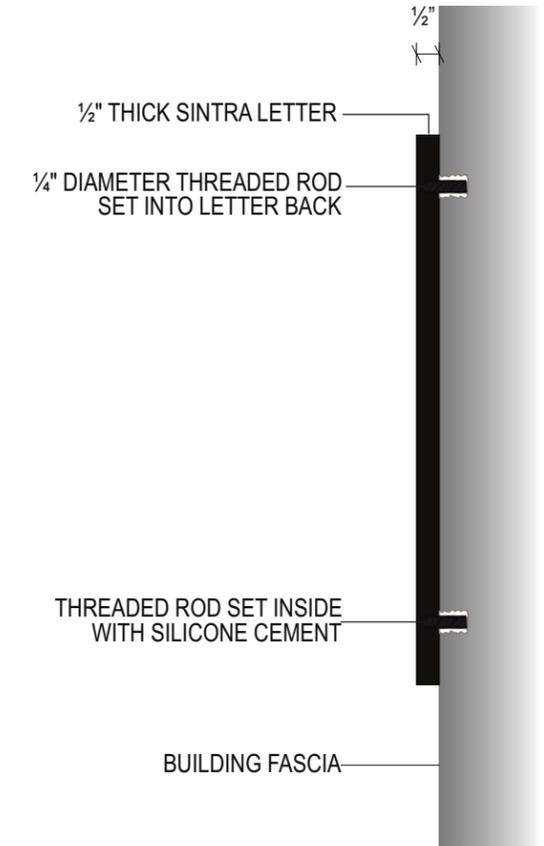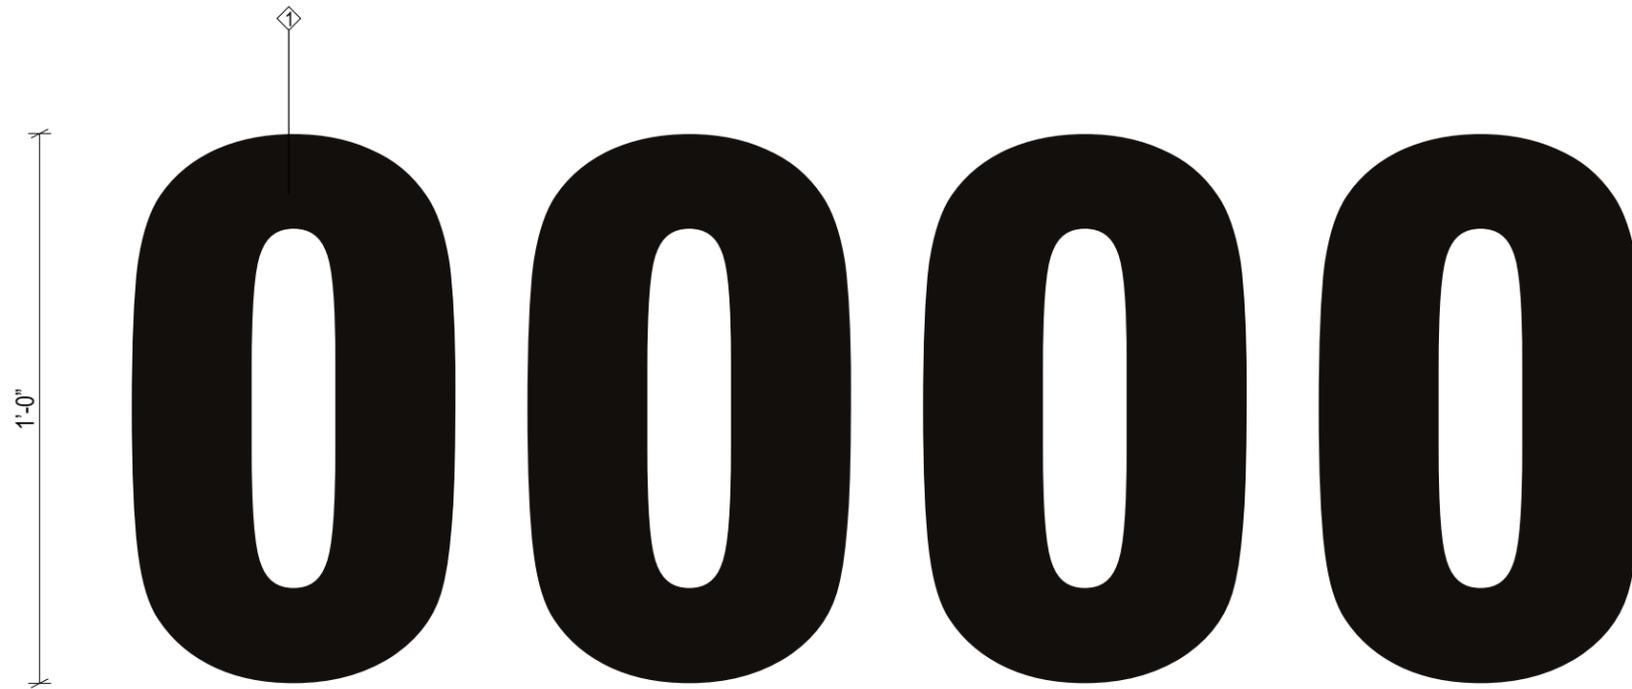

Sign Specs:



NUMERALS: TO BE 1/2" THICK FLAT CUT NON-ILLUMINATED SINTRA NUMERALS WITH FACES AND RETURNS TO BE PAINTED DARK BRONZE.

MOUNTING: NUMERALS TO BE MOUNTED FLUSH TO FASCIA WITH THREADED RODS INTO NUMERAL BACK AND SET INTO PRE-DRILLED HOLES WITH SILICONE.

Colors:

MATTHEWS MP 74155 SV SATIN DARK BRONZE

**BOLLARD TO BE SET BY OTHERS
FINISHED WITH POST AND PANEL SIGN BY NSMC**

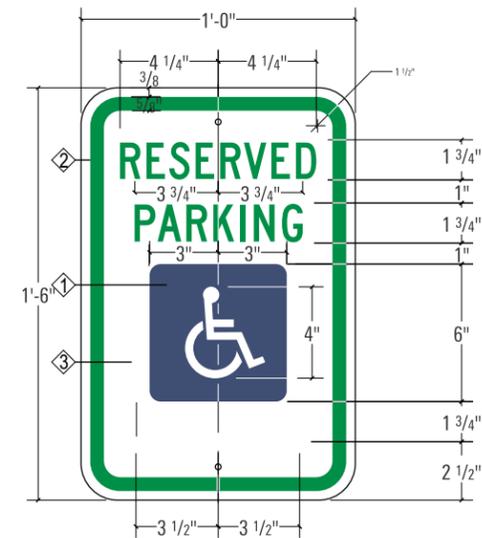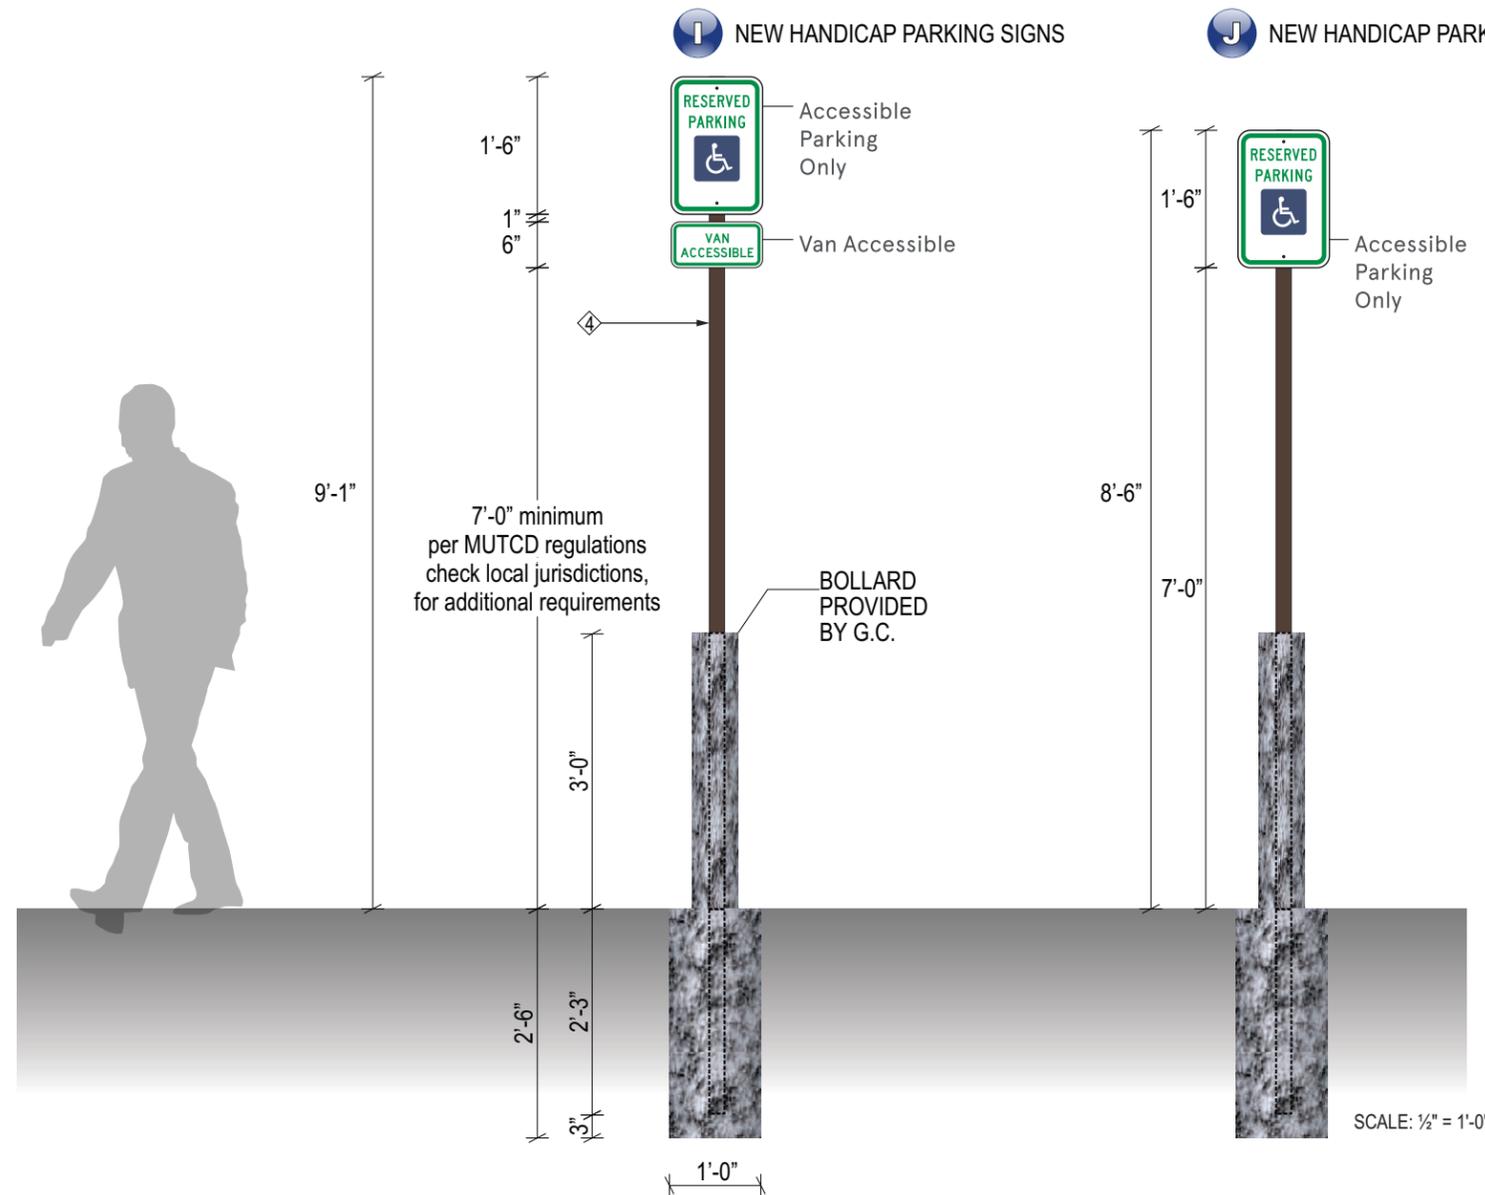

* Guidelines shown above taken from Standard Highway Signs 2004 Edition, 2012 Supplement.



* Guidelines shown above taken from Standard Highway Signs 2004 Edition, 2012 Supplement.

CFA - 00775 - CFA ADA PARKING 12X18 (STATE SPECIFIC)
CFA - 00776 - CFA ADA PARKING WITH VAN ACCESSIBLE PANEL 12X9 (STATE SPECIFIC)

Sign Specs:

PANEL:	.080 ALUMINUM PANELS WITH 1 1/2" RADIUS CORNERS, ATTACHED TO POLE WITH CARRIAGE BOLTS. BACKS PAINTED BRONZE METALLIC.
FACE:	CUT OUT / WEEDED REFLECTIVE VINYL APPLIED FIRST SURFACE
POST:	2" X 2" ALUMINUM POLE CAPPED ON TOP, POST TO BE PAINTED BRONZE METALLIC.
FOOTING:	CONCRETE FOOTING PER CITY REGULATIONS.

Colors:

①	3M 680-75 REFLECTIVE BLUE
②	3M 680-77 REFLECTIVE GREEN
③	3M 680-10 REFLECTIVE WHITE
④	MP 20181 EQUUS BRONZE METALLIC



National Sign & Marketing Corporation
13580 5th St., Chino, CA 91710
Tel 909.591.4742 Fax 909.747.6446
e-mail: sales@nsmc.com
Lic# 745030 - Exp. 01/31/26

Project Name:

Chick-fil-A
#5934
Powers & Palmer Park

Address:

SEC Power Blvd. &
Palmer Park Blvd.
Colorado Springs, CO.

Account Mgr.

Steve Rosenbloom

Approved by:

Date:

Drawing Number

31130R1

Revision

02/21/25 TB: Update A to canopy mounted, add C. Pylon goes to addendum.

Designer:

T Behrman

Date:

01/10/2025

DIRECTIONAL

HANDICAP SIGNS

Page 18

Scale: NOTED

THIS IS AN ORIGINAL UNPUBLISHED DRAWING CREATED FOR YOUR PERSONAL USE IN CONNECTION WITH A PROJECT PLANNED FOR YOU BY NSMC. IT IS NOT TO BE SHOWN OUTSIDE YOUR ORGANIZATION NOR USED, REPRODUCED, COPIED OR EXHIBITED IN ANY FASHION UNLESS AUTHORIZED IN WRITING BY AN OFFICER OF NSMC.

This sign intended to be in accordance with the requirements of Article 600 of the National Electrical Code and/or other applicable local codes. This includes proper grounding and bonding of this sign.





National Sign & Marketing Corporation
 13580 5th St., Chino, CA 91710
 Tel 909.591.4742 Fax 909.747.6446
 e-mail: sales@nsmc.com
 Lic# 745030 - Exp. 01/31/26

Project Name:
 Chick-fil-A
 #5934
 Powers & Palmer Park

Address:
 SEC Power Blvd. &
 Palmer Park Blvd.
 Colorado Springs, CO.

Account Mgr.
 Steve Rosenbloom

Approved by:

Date:

Drawing Number
31130R1

Revision
 02/21/25 TB: Update A to canopy mounted, add C. Pylon goes to addendum.

Designer: T Behrman
Date: 01/10/2025


TEAM MEMBERS ONLY VINYL

Page 20


Scale: 3" = 1'-0"

THIS IS AN ORIGINAL UNPUBLISHED DRAWING CREATED FOR YOUR PERSONAL USE IN CONNECTION WITH A PROJECT PLANNED FOR YOU BY NSMC. IT IS NOT TO BE SHOWN OUTSIDE YOUR ORGANIZATION NOR USED, REPRODUCED, COPIED OR EXHIBITED IN ANY FASHION UNLESS AUTHORIZED IN WRITING BY AN OFFICER OF NSMC.

This sign intended to be in accordance with the requirements of Article 600 of the National Electrical Code and/or other applicable local codes. This includes proper grounding and bonding of this sign.

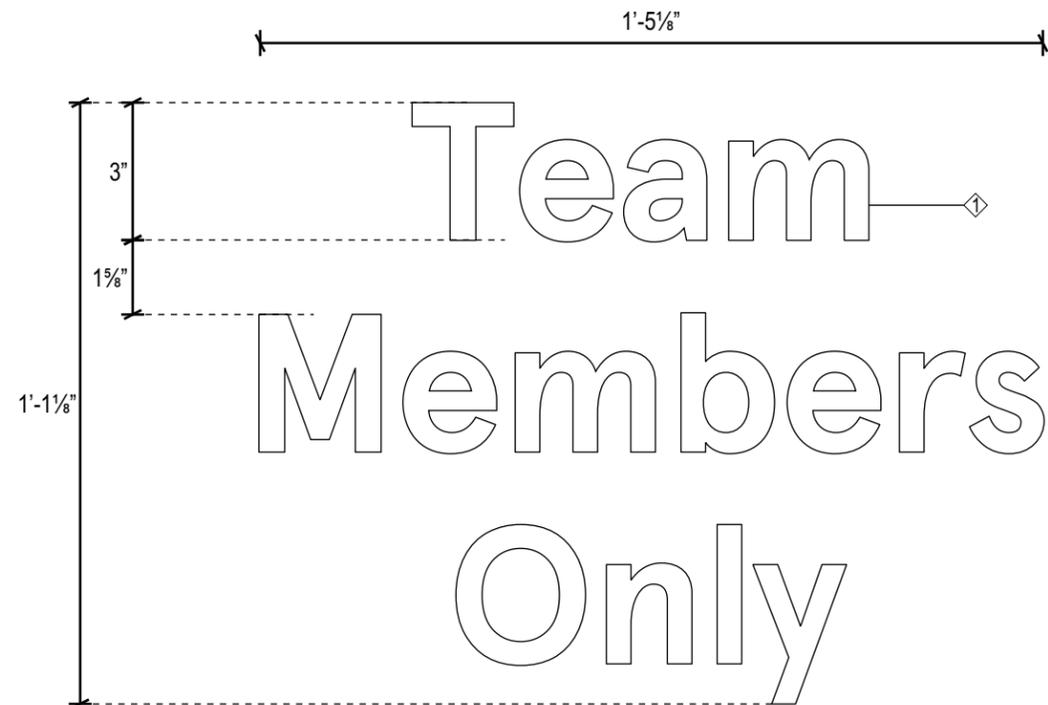

ALL LETTERING APPLIED FIRST SURFACE

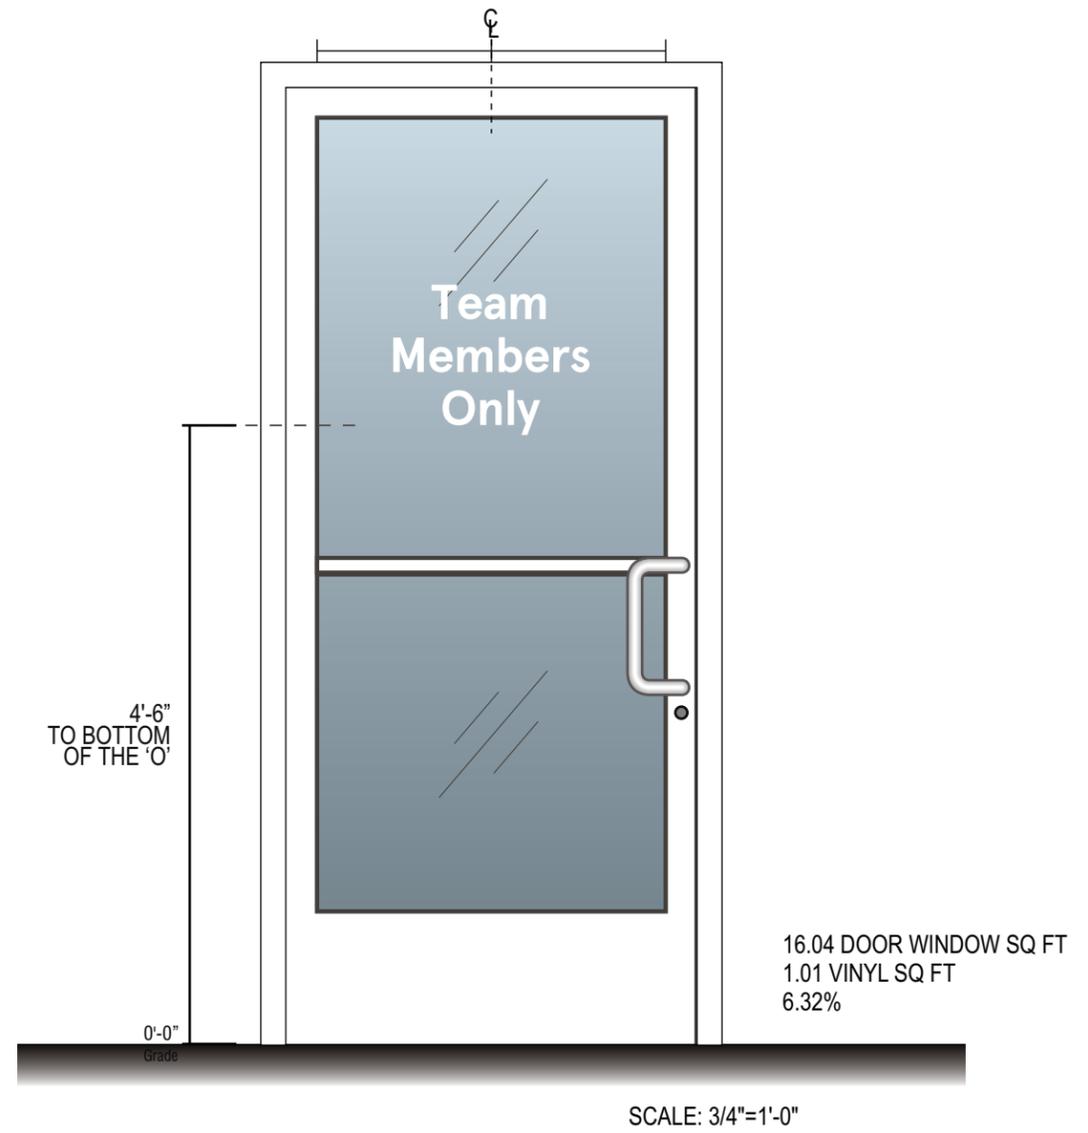

SCALE: 3/4"=1'-0"

L NEW TEAM MEMBER ONLY VINYL

Sign Specs:
 DOOR VINYL: WHITE VINYL APPLIED TO FIRST SURFACE.

Colors:
 3M 7725-10 OPAQUE WHITE

CFA-00852



National Sign & Marketing Corporation
 13580 5th St., Chino, CA 91710
 Tel 909.591.4742 Fax 909.747.6446
 e-mail: sales@nsmc.com
 Lic# 745030 - Exp. 01/31/26

Project Name:
 Chick-fil-A
 #5934
 Powers & Palmer Park

Address:
 SEC Power Blvd. &
 Palmer Park Blvd.
 Colorado Springs, CO.

Account Mgr.
 Steve Rosenbloom

Approved by:

Date:

Drawing Number
31130R1

Revision
 02/21/25 TB: Update A to canopy mounted.
 add C. Fylon goes to addendum.

Designer: T Behrman
Date: 01/10/2025


TEAM MEMBERS
 ONLY
 VINYL

Page 21


Scale: 3" = 1'-0"

THIS IS AN ORIGINAL UNPUBLISHED DRAWING CREATED FOR YOUR PERSONAL USE IN CONNECTION WITH A PROJECT PLANNED FOR YOU BY NSMC. IT IS NOT TO BE SHOWN OUTSIDE YOUR ORGANIZATION NOR USED, REPRODUCED, COPIED OR EXHIBITED IN ANY FASHION UNLESS AUTHORIZED IN WRITING BY AN OFFICER OF NSMC.

This sign intended to be in accordance with the requirements of Article 600 of the National Electrical Code and/or other applicable local codes. This includes proper grounding and bonding of this sign.

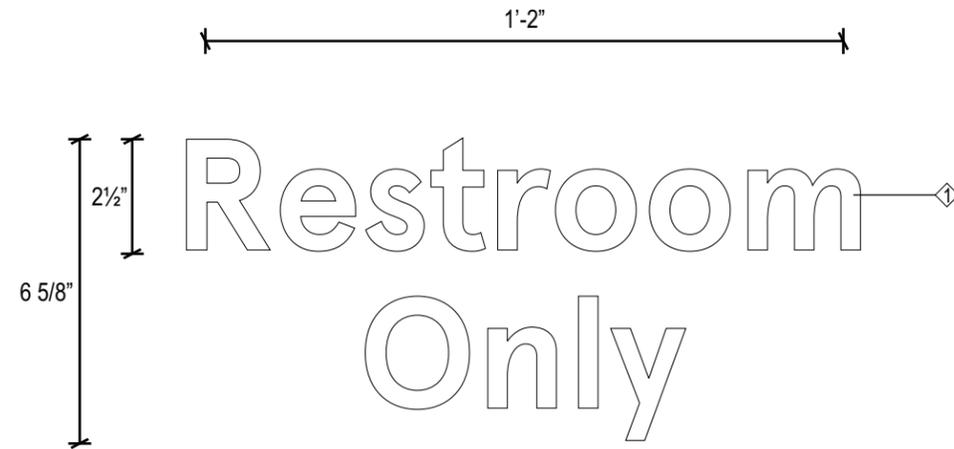

ALL LETTERING APPLIED
 FIRST SURFACE

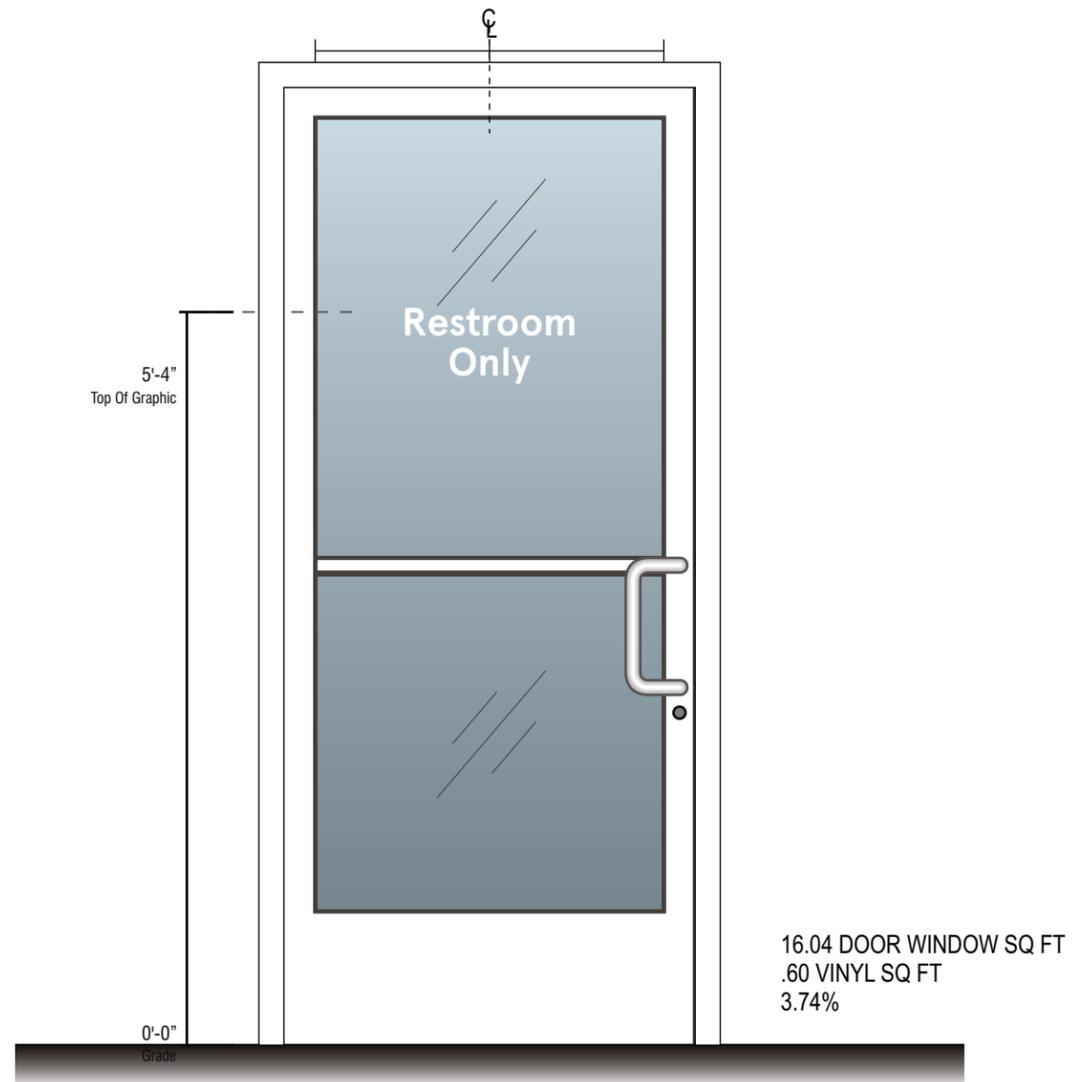

SCALE: 3/4"=1'-0"

M NEW RESTROOM ONLY VINYL

Sign Specs:
 DOOR VINYL: WHITE VINYL APPLIED TO FIRST SURFACE.

Colors:
 3M 7725-10 OPAQUE WHITE

CFA-00862



National Sign & Marketing Corporation
 13580 5th St., Chino, CA 91710
 Tel 909.591.4742 Fax 909.747.6446
 e-mail: sales@nsmc.com
 Lic# 745030 - Exp. 01/31/26

Project Name:
 Chick-fil-A
 #5934
 Powers & Palmer Park

Address:
 SEC Power Blvd. &
 Palmer Park Blvd.
 Colorado Springs, CO.

Account Mgr.
 Steve Rosenbloom

Approved by:

Date:

Drawing Number
31130R1

Revision
 02/21/25 TB: Update A to canopy mounted, add C. Fylon goes to addendum.

Designer: T Behrman
Date: 01/10/2025



PICK UP WALK UP WINDOW SIGN

Page 22


Scale: 3" = 1'-0"

THIS IS AN ORIGINAL UNPUBLISHED DRAWING CREATED FOR YOUR PERSONAL USE IN CONNECTION WITH A PROJECT PLANNED FOR YOU BY NSMC. IT IS NOT TO BE SHOWN OUTSIDE YOUR ORGANIZATION NOR USED, REPRODUCED, COPIED OR EXHIBITED IN ANY FASHION UNLESS AUTHORIZED IN WRITING BY AN OFFICER OF NSMC.

This sign intended to be in accordance with the requirements of Article 600 of the National Electrical Code and/or other applicable local codes. This includes proper grounding and bonding of this sign.

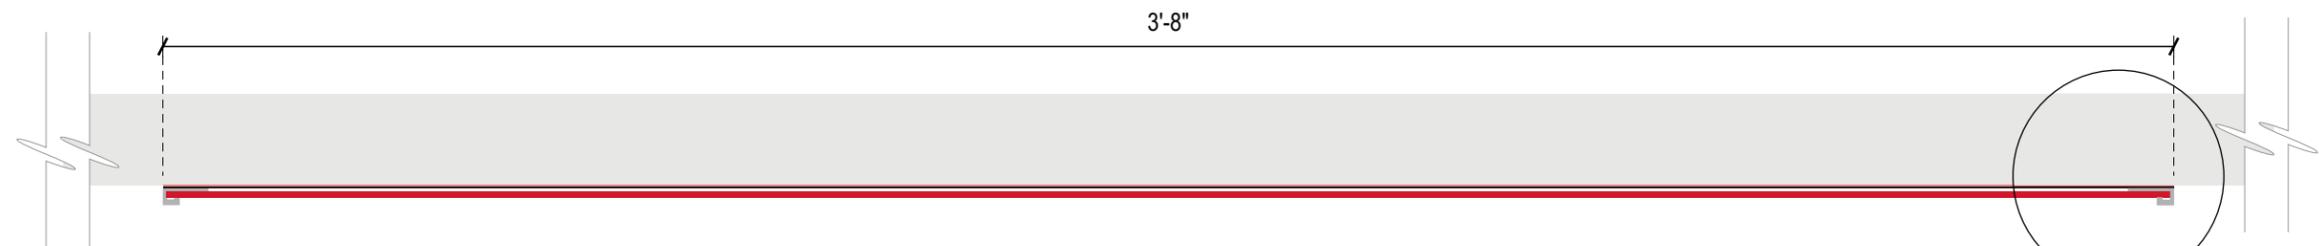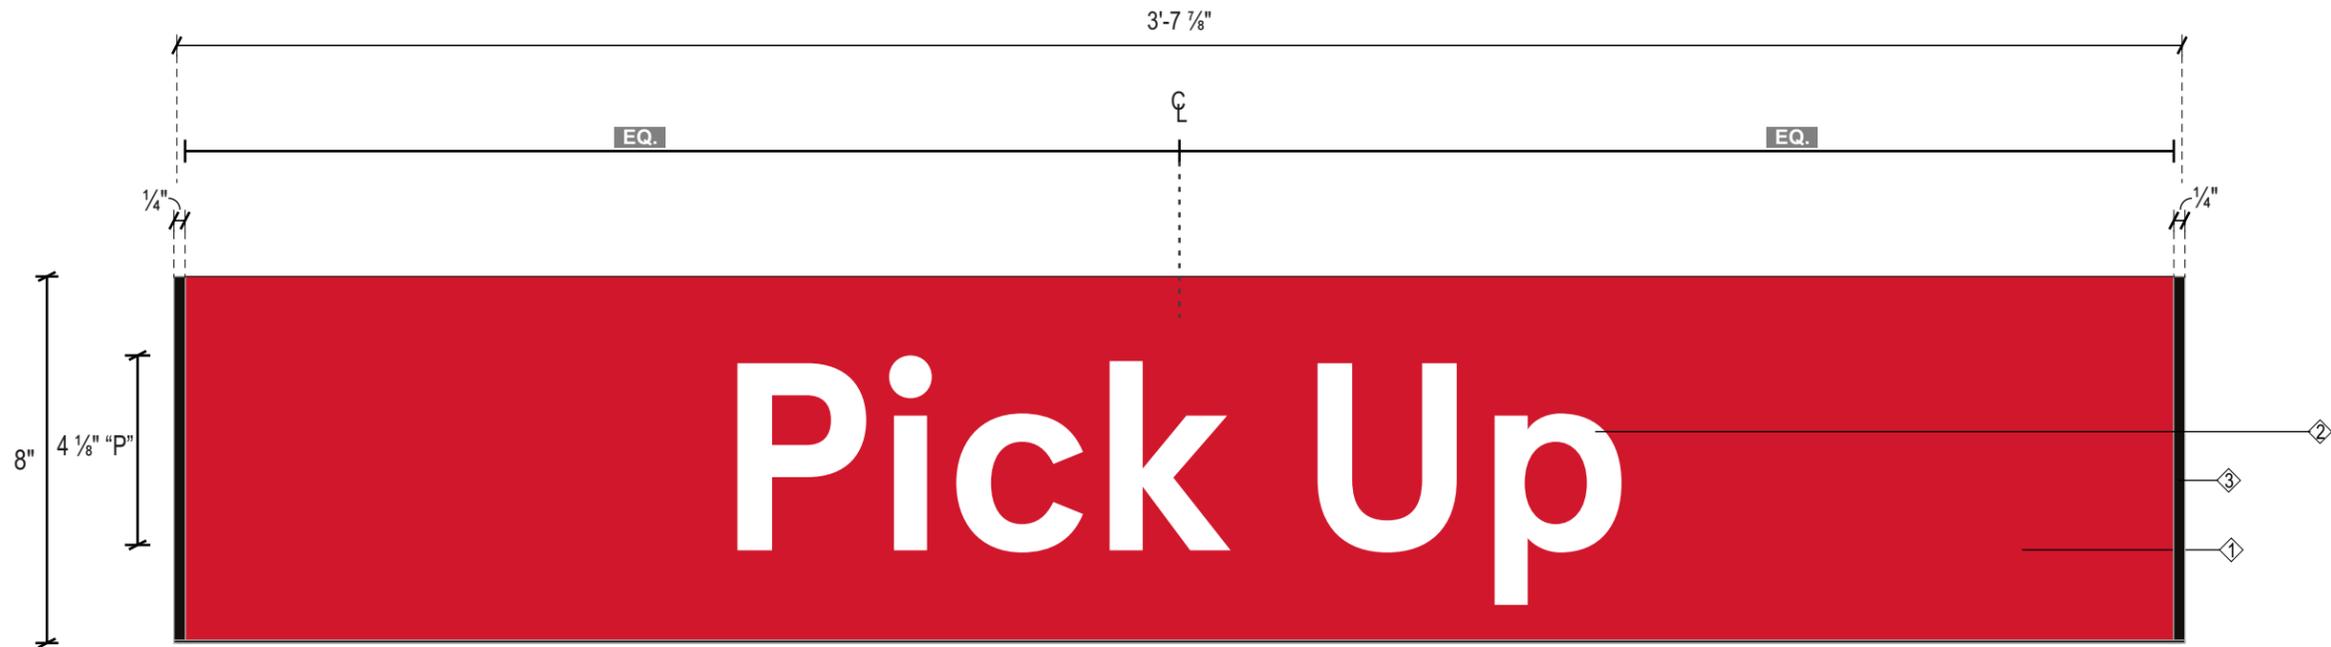

TOP VIEW

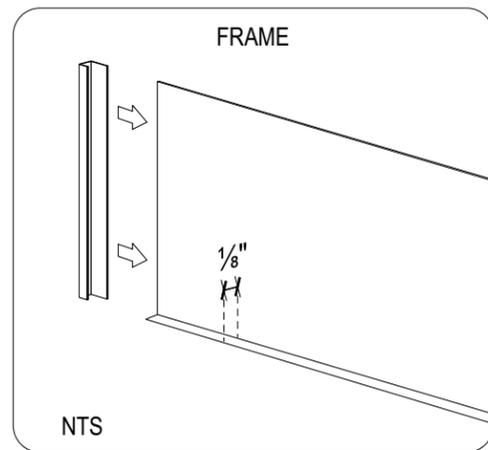

..040" PRECOAT ALUMINUM WITH VHB TAPE ONTO EXISTING WINDOW MULLION

EXISTING WINDOW MULLION

ALUMINUM "J" TRACK MOUNTED TO PRECOAT ALUMINUM, FOR ACM PANEL TO SLIDE INTO.

N NEW PICKUP SIGN

Sign Specs:

PANEL: 3MM ACM PAINTED RED WITH WHITE VINYL COPY APPLIED FIRST SURFACE.

FRAME: ..040" PRECOAT ALUMINUM BACKER WITH 8" "J" TRACK ATTACHED TO FACE WITH VHB TAPE, PAINTED DARK BRONZE.

Colors:

MP 10252 RED SEMI-GLOSS
 3M 7725-10 OPAQUE WHITE



National Sign & Marketing Corporation
 13580 5th St., Chino, CA 91710
 Tel 909.591.4742 Fax 909.747.6446
 e-mail: sales@nsmc.com
 Lic# 745030 - Exp. 01/31/26

Project Name:
 Chick-fil-A
 #5934
 Powers & Palmer Park

Address:
 SEC Power Blvd. &
 Palmer Park Blvd.
 Colorado Springs, CO.

Account Mgr.
 Steve Rosenbloom

Approved by:

Date:

Drawing Number
31130R1

Revision
 02/21/25 TB: Update A to canopy mounted, add C. Pylon goes to addendum.

Designer: T Behrman
Date: 01/10/2025



ORDER
 WALK UP WINDOW
 SIGN

Page 23


Scale: 3" = 1'-0"

THIS IS AN ORIGINAL UNPUBLISHED DRAWING CREATED FOR YOUR PERSONAL USE IN CONNECTION WITH A PROJECT PLANNED FOR YOU BY NSMC. IT IS NOT TO BE SHOWN OUTSIDE YOUR ORGANIZATION NOR USED, REPRODUCED, COPIED OR EXHIBITED IN ANY FASHION UNLESS AUTHORIZED IN WRITING BY AN OFFICER OF NSMC.


This sign intended to be in accordance with the requirements of Article 600 of the National Electrical Code and/or other applicable local codes. This includes proper grounding and bonding of this sign.

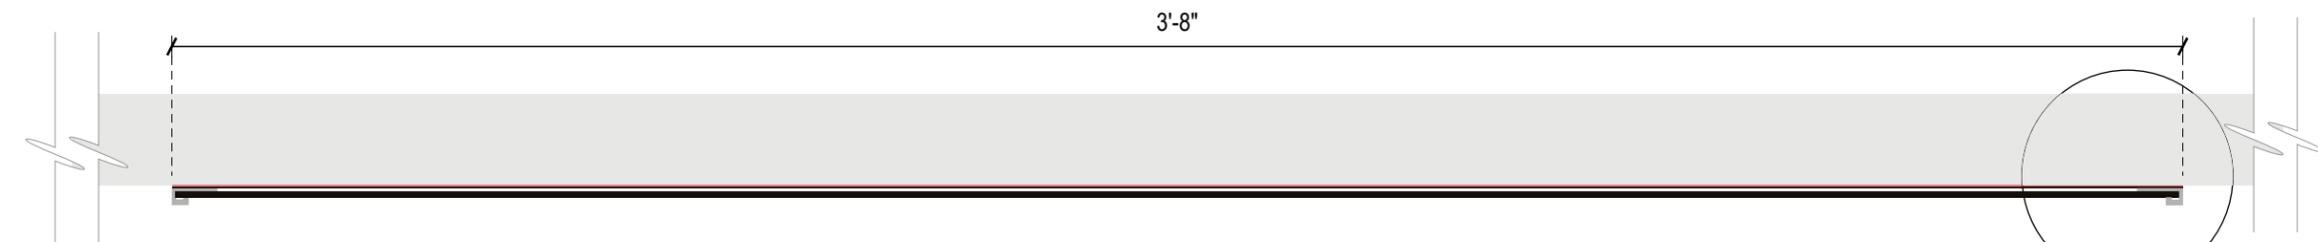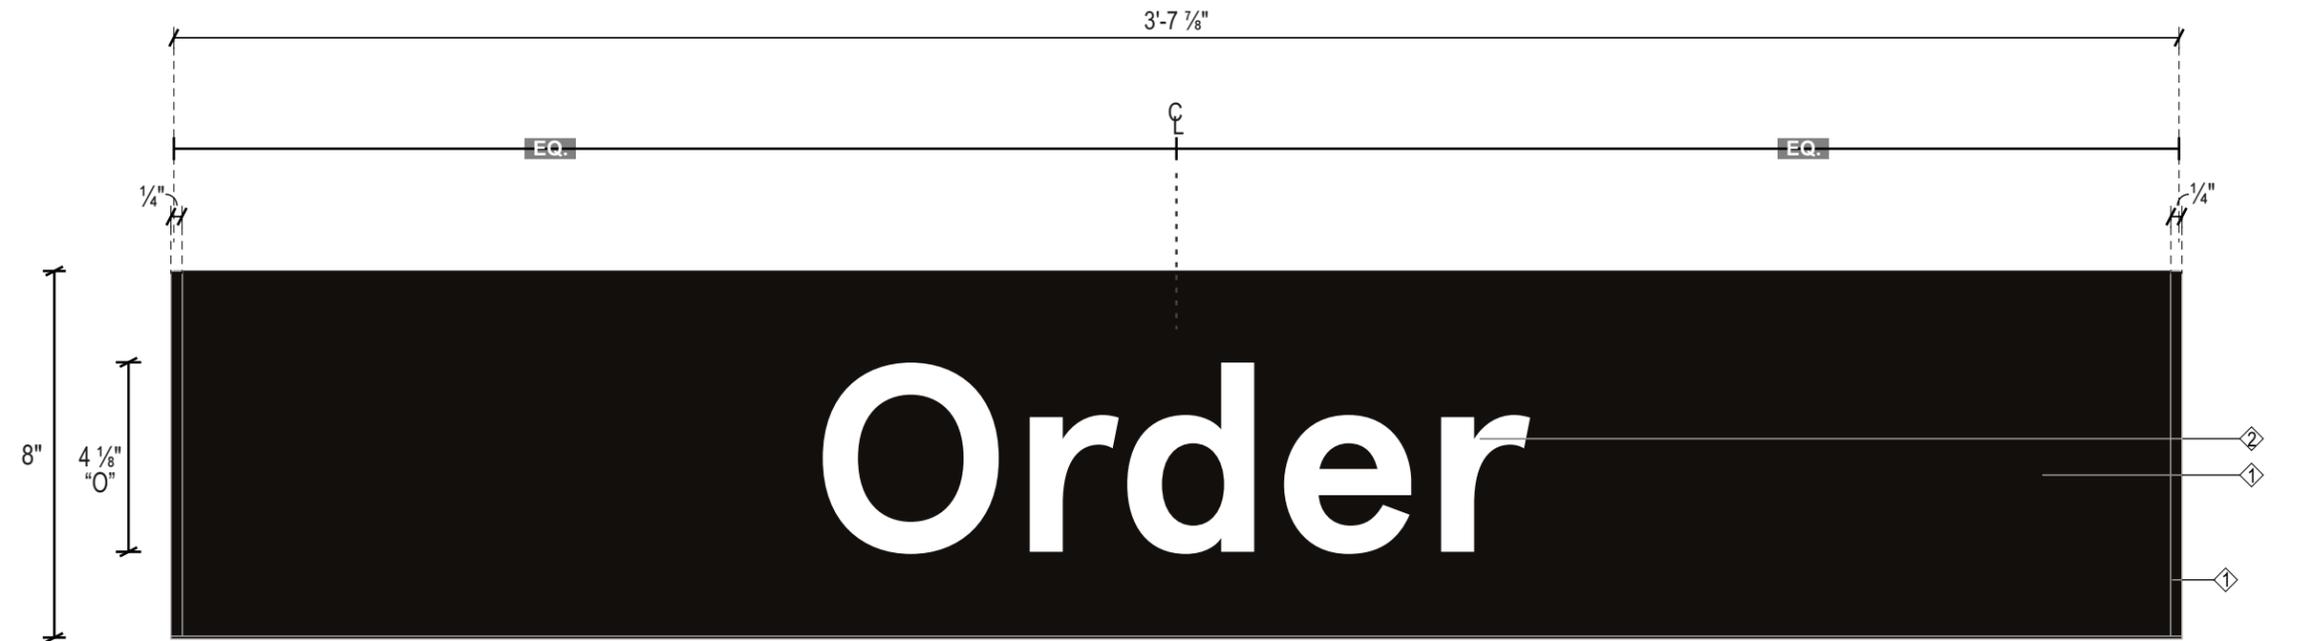

TOP VIEW

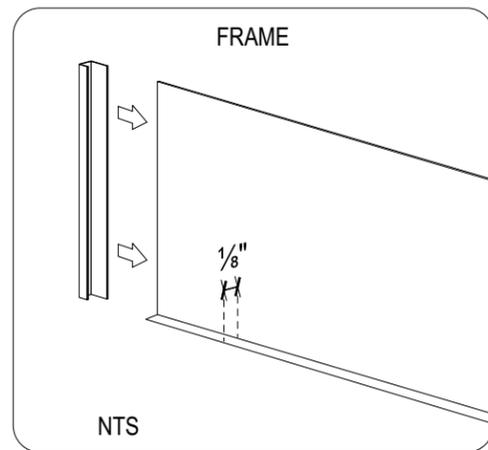

..040" PRECOAT ALUMINUM WITH VHB TAPE ONTO EXISTING WINDOW MULLION

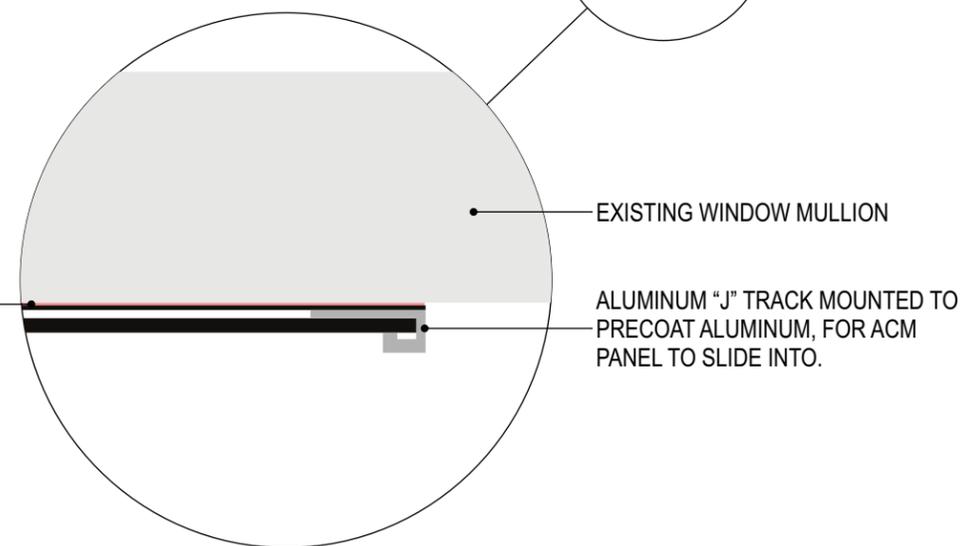

Sign Specs:


PANEL: 3MM ACM PAINTED DARK BRONZE WITH WHITE VINYL COPY APPLIED FIRST SURFACE.

FRAME: ..040" PRECOAT ALUMINUM BACKER WITH 8" "J" TRACK ATTACHED TO FACE WITH VHB TAPE, PAINTED DARK BRONZE.

Colors:

MATTHEWS MP 74155 SEMI-GLOSS DARK BRONZE
 3M 7725-10 OPAQUE WHITE

FOOTINGS BY OTHERS, FINAL SETTING BY NSMC TO BE FABRICATED BY OTHERS

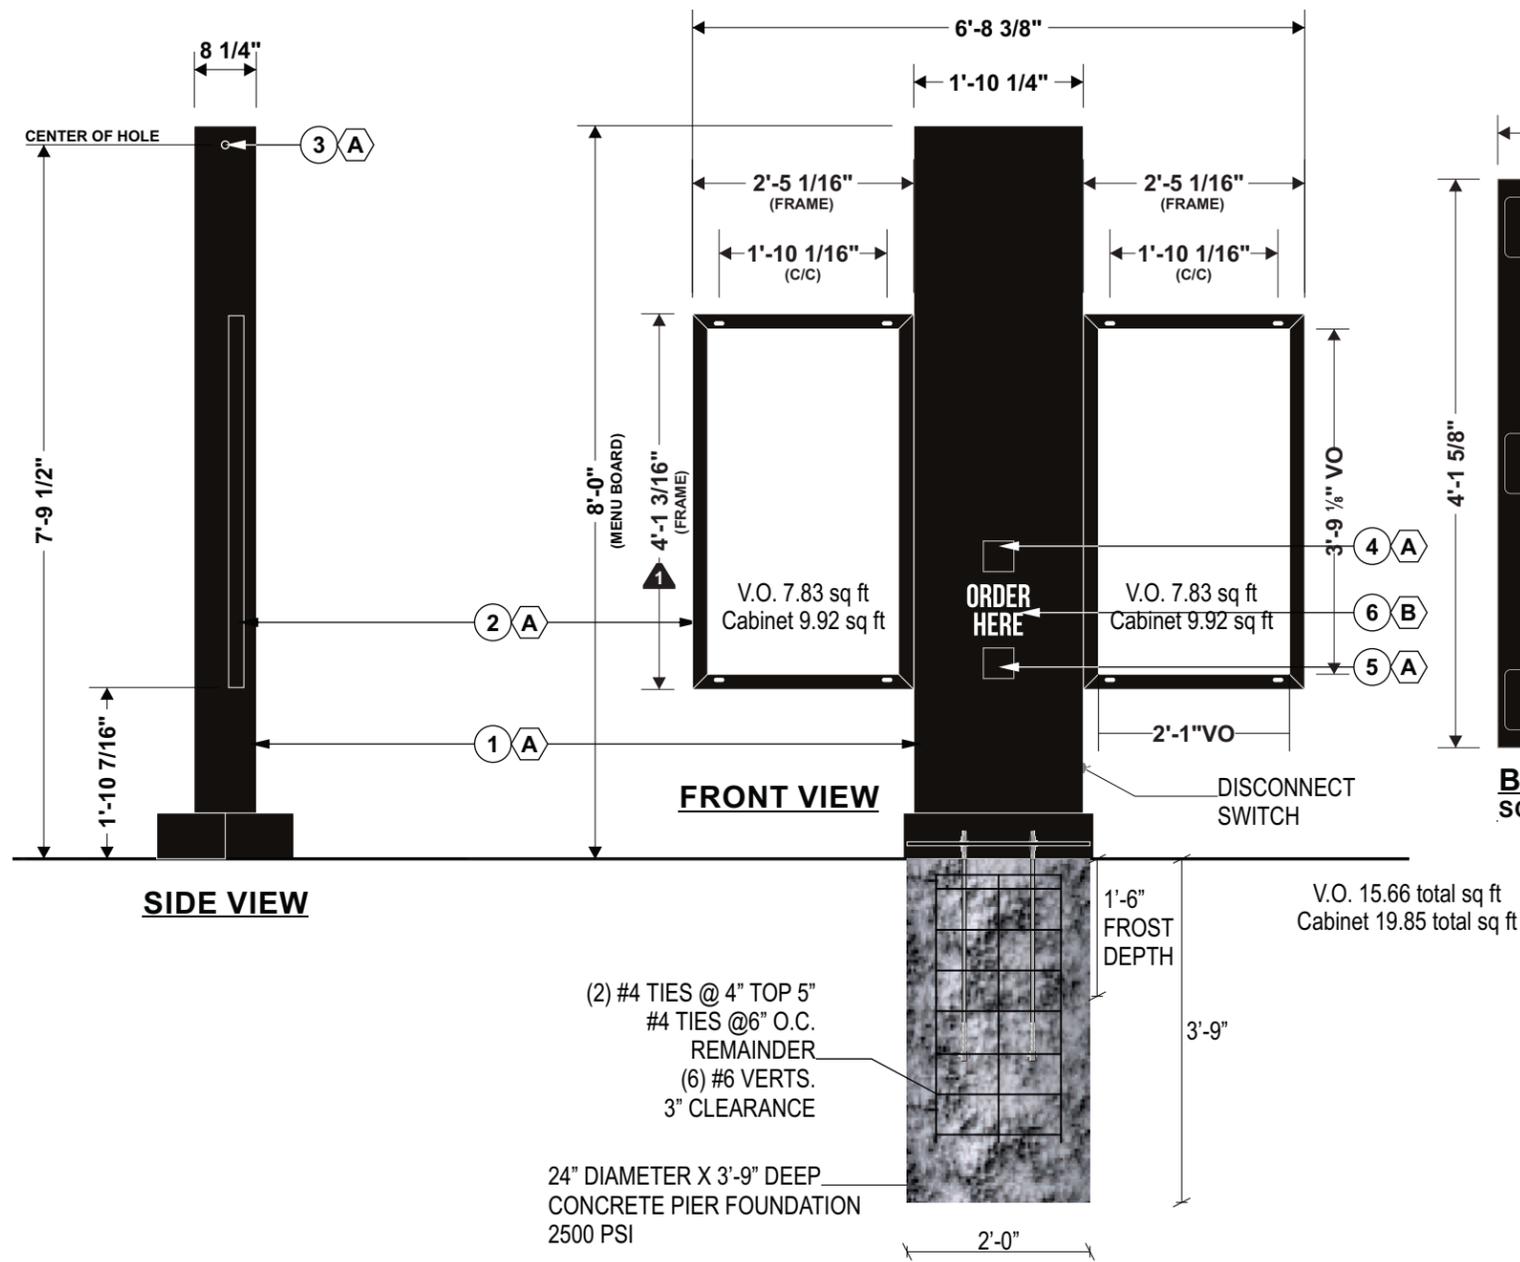

DRIVE-THRU MENU BOARD

Electrical specifications:


Volts:	120	Amp:	1.4	Circ.:	2
---------------	-----	-------------	-----	---------------	---

#	Descriptions:
1	FABRICATED C-CHANNEL STRUCTURE COVERED WITH ALUMINUM
2	2"X 2" STEEL ANGLES FRAME BOLTED TO STRUCTURE (TO HOLD DISPLAYS)
3	PLASTIC BUSHINGS (ONE EACH SIDE)
4	SPEAKER
5	MICROPHONE
6	VINYL DECAL APPLIED TO FIRST SURFACE
7	ALUMINUM ENCLOSURE FOR DISPLAY (2X)

Notes:

1 SEE TECHNICAL DRAWING FOR DETAILS

#	Colors:
2 A	PAINTED CFA BRONZE
B	WHITE REFLECTIVE VINYL #680-10

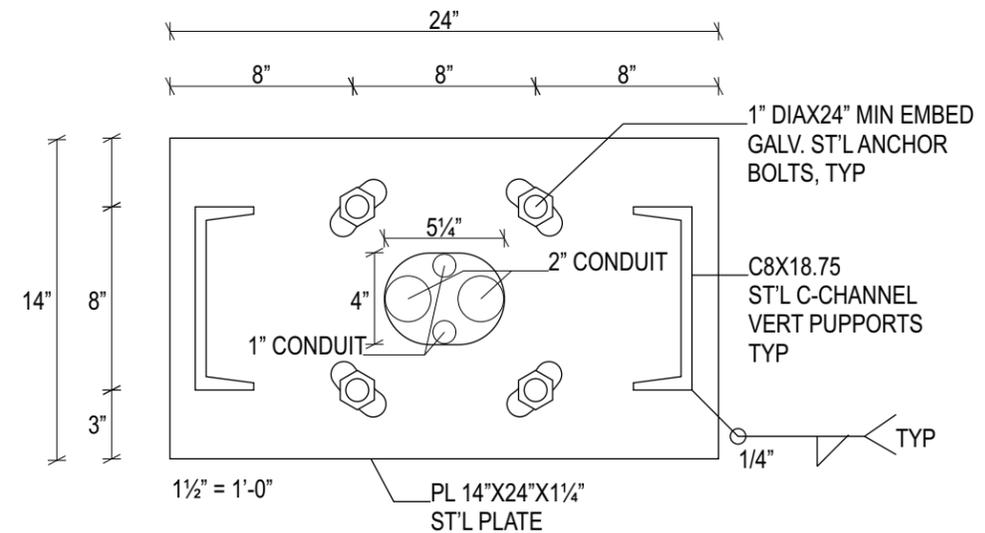

NOTE: ALL WORK TO COMPLY WITH 2022 CALIFORNIA ELECTRICAL CODE (CEC)

1 2 DRIVE-THRU MENU

Sign Specs:

MAIN CABINET:	FABRICATED .080 ALUMINUM RETAINERS AND RETURNS PAINTED DARK BRONZE.
FACES:	DIGITAL DISPLAY
BASE:	ALUMINUM FRAME CLAD IN ALUMINUM.
SWITCH:	ELECTRICAL TOGGLE DISCONNECT SWITCH WITH BOOT
	ALL COMPONENTS TO BE U.L. APPROVED

Colors:

◆	MATTHEWS MP 74155 SV SATIN DARK BRONZE
◇	WHITE REFLECTIVE VINYL #680-10



National Sign & Marketing Corporation
13580 5th St., Chino, CA 91710
Tel 909.591.4742 Fax 909.747.6446
e-mail: sales@nsmc.com
Lic# 745030 - Exp. 01/31/26

Project Name:

Chick-fil-A
#5934
Powers & Palmer Park

Address:

SEC Power Blvd. &
Palmer Park Blvd.
Colorado Springs, CO.

Account Mgr.

Steve Rosenbloom

Approved by:

Date:

Drawing Number

31130R1

Revision

02/21/25 TB: Update A to canopy mounted, add C. Pylon goes to addendum.

Designer: T Behrman
Date: 01/10/2025

DRIVE THRU
DIGITAL MENU BOARD

Page 24

Scale: 1/2" = 1'-0"

THIS IS AN ORIGINAL UNPUBLISHED DRAWING CREATED FOR YOUR PERSONAL USE IN CONNECTION WITH A PROJECT PLANNED FOR YOU BY NSMC. IT IS NOT TO BE SHOWN OUTSIDE YOUR ORGANIZATION NOR USED, REPRODUCED, COPIED OR EXHIBITED IN ANY FASHION UNLESS AUTHORIZED IN WRITING BY AN OFFICER OF NSMC.



This sign intended to be in accordance with the requirements of Article 600 of the National Electrical Code and/or other applicable local codes. This includes proper grounding and bonding of this sign.



FOOTINGS BY OTHERS, FINAL SETTING BY NSMC TO BE FABRICATED BY OTHERS

NOTE:
CLEARANCE BAR ARM TO ROTATE WHEN
STRUCK AND RETURN TO ORIGINAL POSITION.

NOTE:
1. ENTIRE CLEARANCE BAR AND HARDWARE TO BE POWDER-COATED DARK BRONZE FINISH
2. CHANDLER TO PROVIDE ALL-THREAD ANCHORS WITH FENDER WASHERS AND HEX BOLTS
3. GENERAL CONTRACTOR TO POUR NEW CONCRETE FOOTER. FOUR ALL-THREAD ANCHORS TO BE EMBEDDED INTO FOOTER ON 9 INCH CENTERS

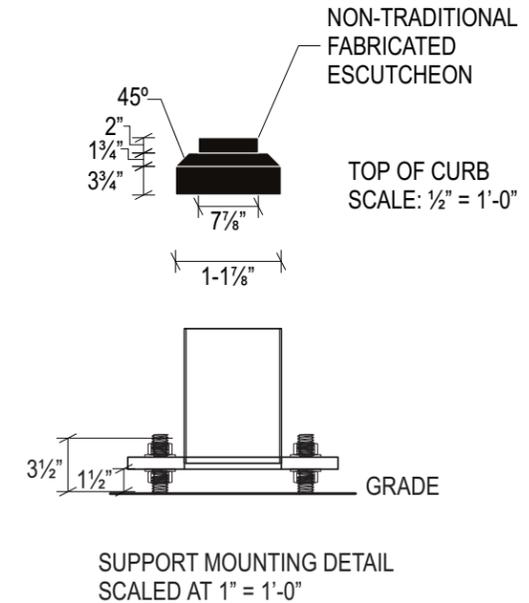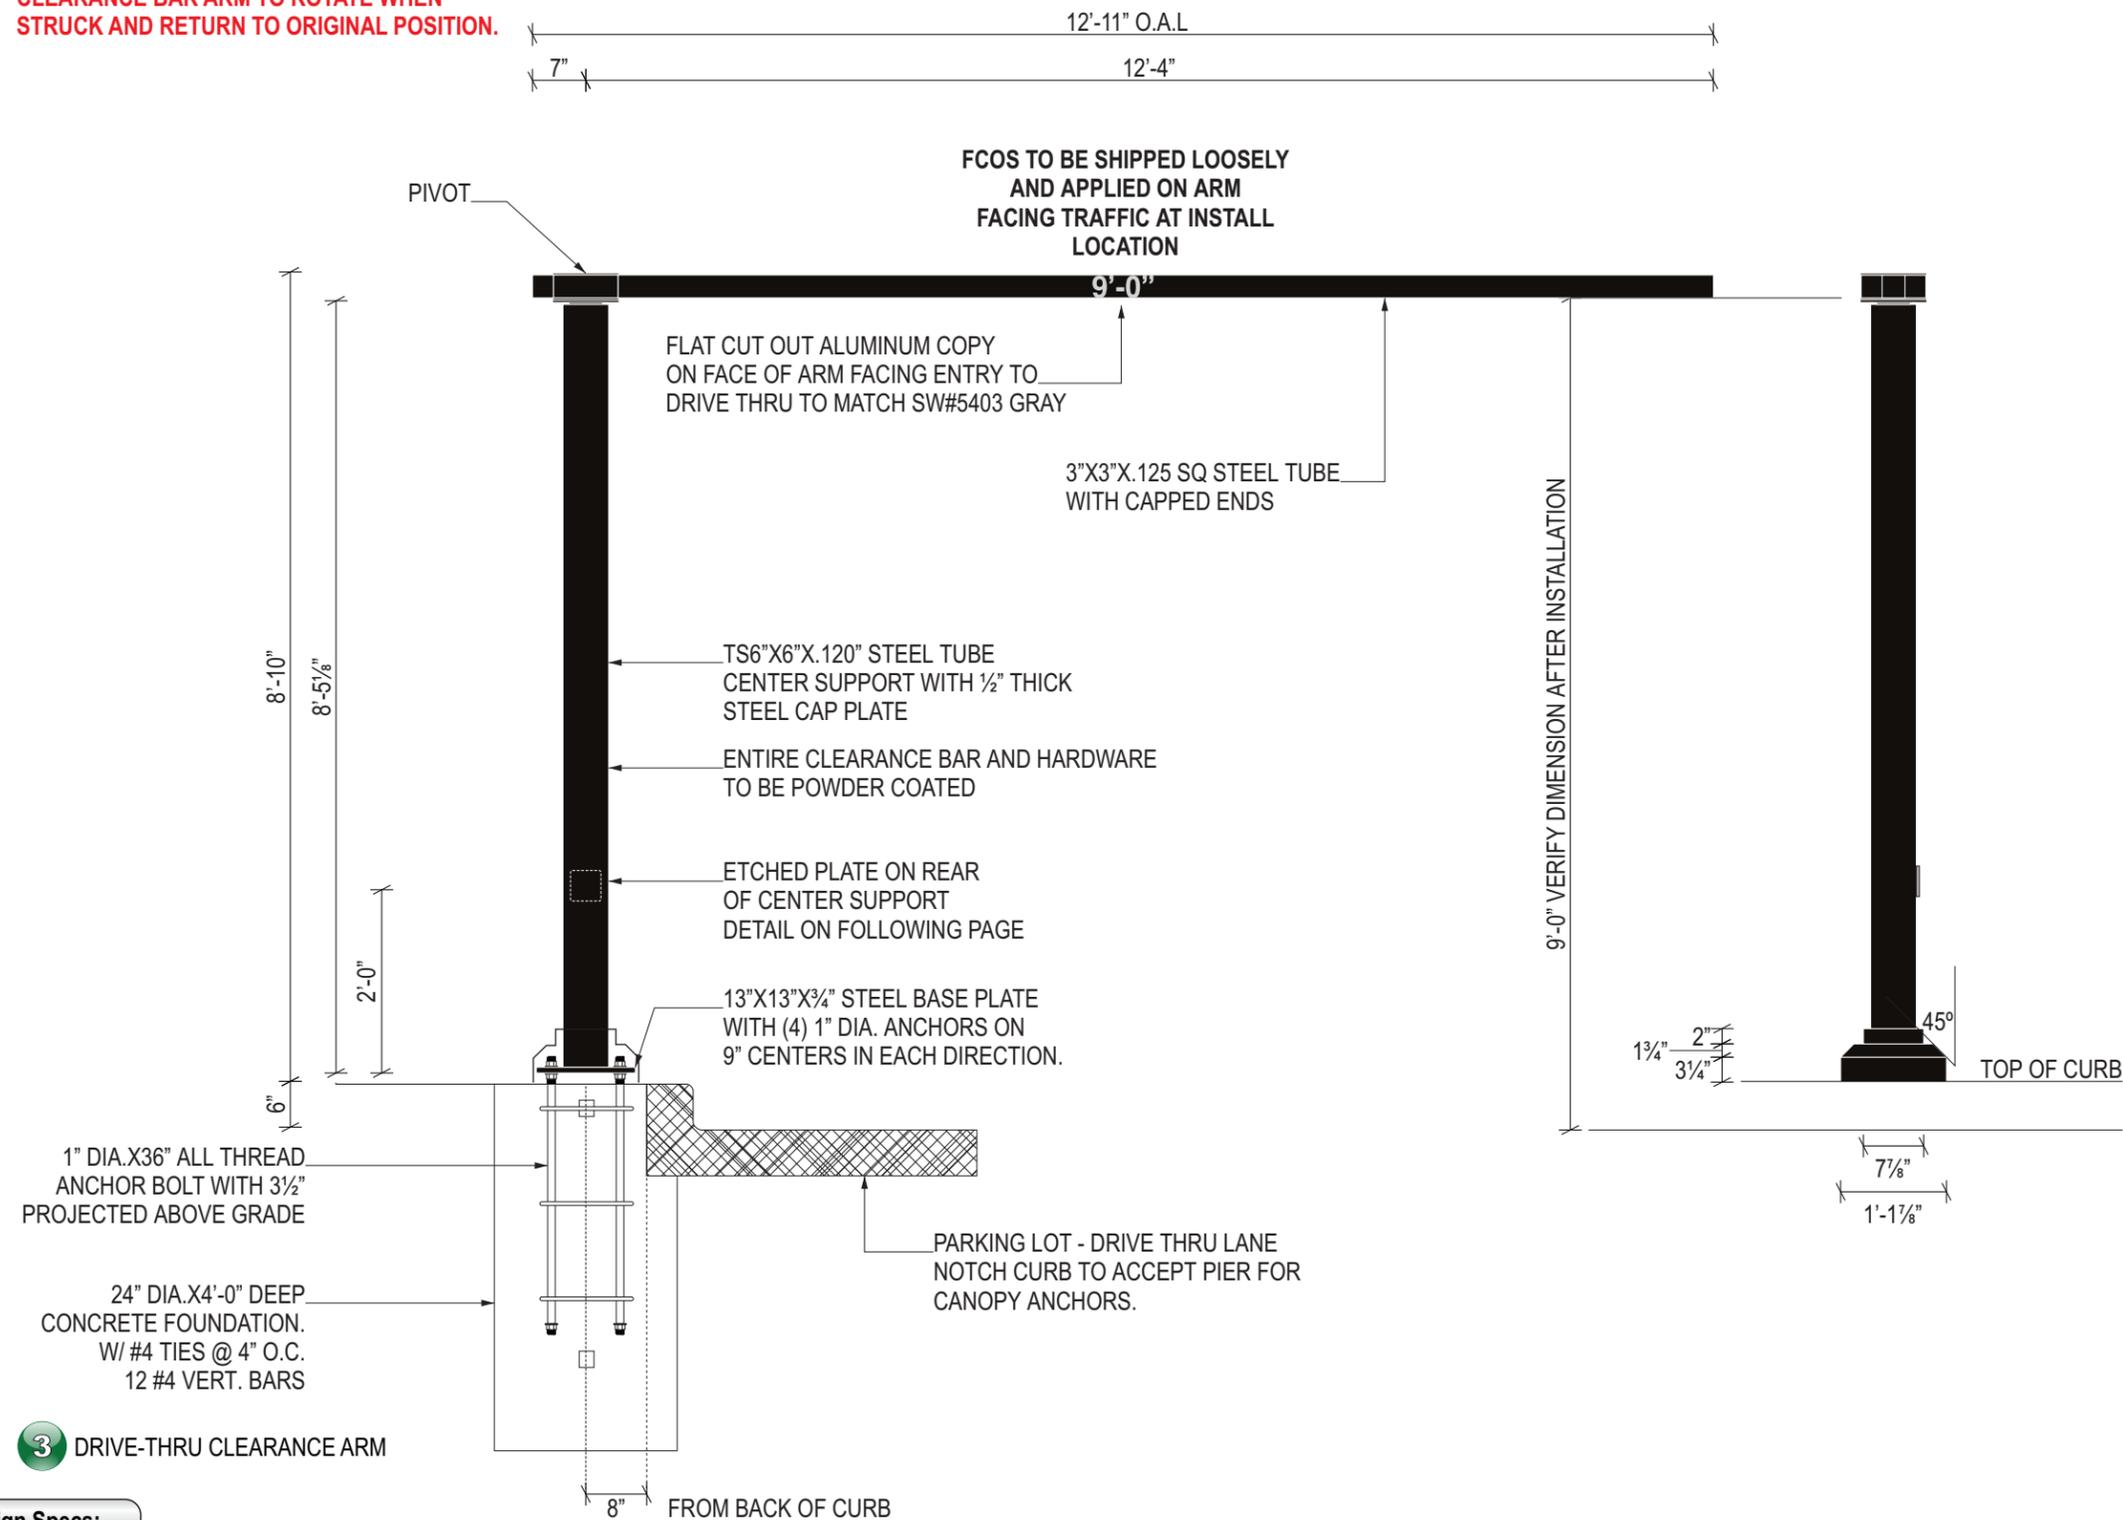

Sign Specs:

CLEARANCE ARM: TO BE FABRICATED BY OTHERS TO BE PAINTED DARK BRONZE.
COPY: 9'-0" TO BE FLAT CUT OUT ALUMINUM COPY ON FACE OF ARM FACING ENTRY TO DRIVE THRU PAINTED TO MATCH SW #5403 GRAY ATTACHED WITH VHB.
NOTES: STANDARD HEIGHT ACCORDING TO CLEARANCE, DRIVE THRU GRADE TO BOTTOM OF CLEARANCE ARM. HEIGHT OF CAGE WILL NEED TO BE ADJUSTED TO ACCOMMODATE THE DISTANCE BETWEEN THE ARM AND GRADE. THERE MUST BE AT LEAST 3 1/2" OF BOLT THREAD ABOVE GRADE.

Colors:

 SHERWIN WILLIAMS #5403 GRAY
 MATTHEWS MP 74155 SV SATIN DARK BRONZE



**National Sign
& MARKETING CORPORATION**
13580 5th St., Chino, CA 91710
Tel 909.591.4742 Fax 909.747.6446
e-mail: sales@nsmc.com
Lic# 745030 - Exp. 01/31/26

Project Name:
Chick-fil-A
#5934
Powers & Palmer Park

Address:
SEC Power Blvd. &
Palmer Park Blvd.
Colorado Springs, CO.

Account Mgr.
Steve Rosenbloom

Approved by:

Date:

Drawing Number
31130R1

Revision
02/21/25 TB: Update A to canopy mounted,
add C. Eylon goes to addendum.

Designer: Date:
T Behrman 01/10/2025

GEN. 3
CLEARANCE
ARM

Page 25

Scale: 1/2" = 1'-0"

THIS IS AN ORIGINAL UNPUBLISHED DRAWING CREATED FOR YOUR PERSONAL USE IN CONNECTION WITH A PROJECT PLANNED FOR YOU BY NSMC. IT IS NOT TO BE SHOWN OUTSIDE YOUR ORGANIZATION NOR USED, REPRODUCED, COPIED OR EXHIBITED IN ANY FASHION UNLESS AUTHORIZED IN WRITING BY AN OFFICER OF NSMC


This sign intended to be in accordance with the requirements of Article 600 of the National Electrical Code and/or other applicable local codes. This includes proper grounding and bonding of this sign.



FOOTINGS BY OTHERS, FINAL SETTING BY NSMC TO BE FABRICATED BY OTHERS

NOTE:
CLEARANCE BAR ARM TO ROTATE WHEN
STRUCK AND RETURN TO ORIGINAL POSITION.

- NOTE:**
1. ENTIRE CLEARANCE BAR AND HARDWARE TO BE POWDER-COATED DARK BRONZE FINISH
 2. HANDLER TO PROVIDE ALL-THREAD ANCHORS WITH FENDER WASHERS AND HEX BOLTS
 3. GENERAL CONTRACTOR TO POUR NEW CONCRETE FOOTER. FOUR ALL-THREAD ANCHORS TO BE EMBEDDED INTO FOOTER ON 9 INCH CENTERS

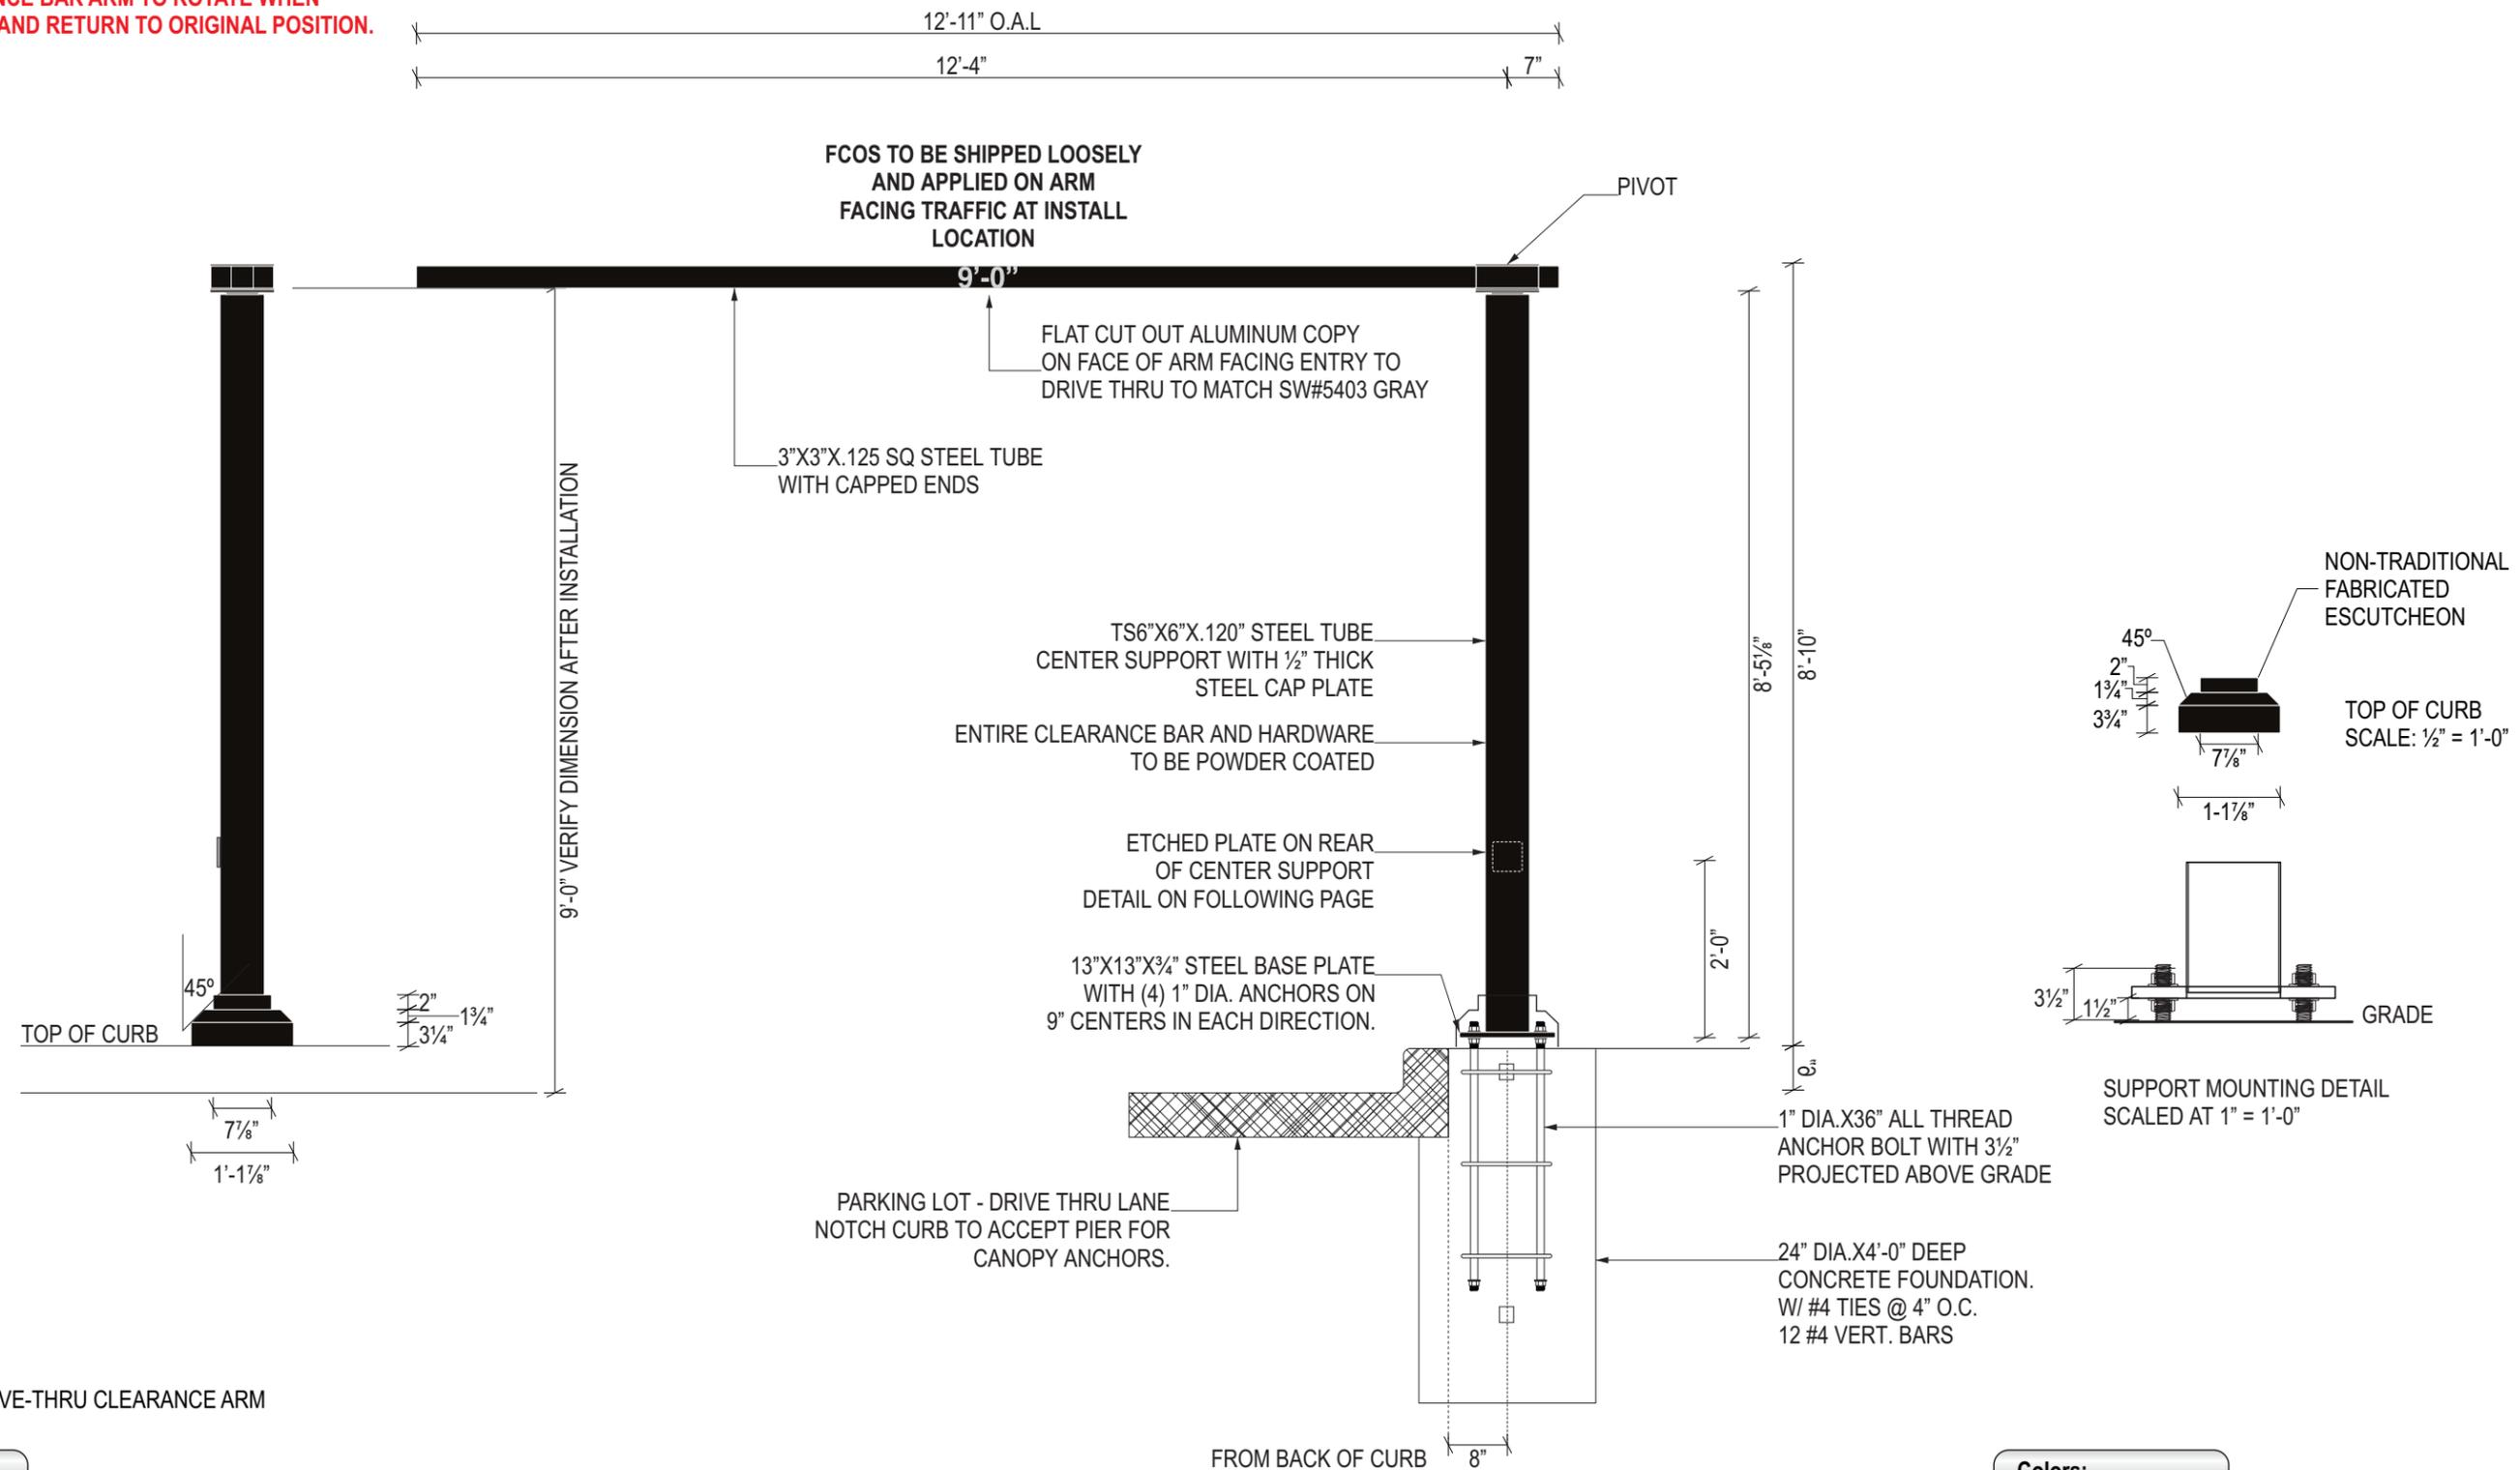

4 DRIVE-THRU CLEARANCE ARM

Sign Specs:

CLEARANCE ARM: TO BE FABRICATED BY OTHERS TO BE PAINTED DARK BRONZE.
COPY: 9'-0" TO BE FLAT CUT OUT ALUMINUM COPY ON FACE OF ARM FACING ENTRY TO DRIVE THRU PAINTED TO MATCH SW #5403 GRAY ATTACHED WITH VHB.
NOTES: STANDARD HEIGHT ACCORDING TO CLEARANCE, DRIVE THRU GRADE TO BOTTOM OF CLEARANCE ARM. HEIGHT OF CAGE WILL NEED TO BE ADJUSTED TO ACCOMMODATE THE DISTANCE BETWEEN THE ARM AND GRADE. THERE MUST BE AT LEAST 3 1/2" OF BOLT THREAD ABOVE GRADE.

Colors:

 SHERWIN WILLIAMS #5403 GRAY
 MATTHEWS MP 74155 SV SATIN DARK BRONZE



National Sign & Marketing Corporation
13580 5th St., Chino, CA 91710
Tel 909.591.4742 Fax 909.747.6446
e-mail: sales@nsmc.com
Lic# 745030 - Exp. 01/31/26

Project Name:
Chick-fil-A
#5934
Powers & Palmer Park

Address:
SEC Power Blvd. &
Palmer Park Blvd.
Colorado Springs, CO.

Account Mgr.
Steve Rosenbloom

Approved by:

Date:

Drawing Number
31130R1

Revision
02/21/25 TB: Update A to canopy mounted, add C. Pylon goes to addendum.

Designer: T Behrman
Date: 01/10/2025

GEN. 3
CLEARANCE
ARM

Page 26

Scale: 1/2" = 1'-0"

THIS IS AN ORIGINAL UNPUBLISHED DRAWING CREATED FOR YOUR PERSONAL USE IN CONNECTION WITH A PROJECT PLANNED FOR YOU BY NSMC. IT IS NOT TO BE SHOWN OUTSIDE YOUR ORGANIZATION NOR USED, REPRODUCED, COPIED OR EXHIBITED IN ANY FASHION UNLESS AUTHORIZED IN WRITING BY AN OFFICER OF NSMC.

This sign intended to be in accordance with the requirements of Article 600 of the National Electrical Code and/or other applicable local codes. This includes proper grounding and bonding of this sign.





National Sign & Marketing Corporation
 13580 5th St., Chino, CA 91710
 Tel 909.591.4742 Fax 909.747.6446
 e-mail: sales@nsmc.com
 Lic# 745030 - Exp. 01/31/26

Project Name:

Chick-fil-A
 #5934
 Powers & Palmer Park

Address:

SEC Power Blvd. &
 Palmer Park Blvd.
 Colorado Springs, CO.

Account Mgr.

Steve Rosenbloom

Approved by:

Date:

Drawing Number

31130R1

Revision

02/21/25 TB: Update A to canopy mounted, add C. Pylon goes to addendum.

Designer:

T Behrman

Date:

01/10/2025


GEN. 3
 CLEARANCE
 ARM

Page 27

Scale: NOTED


THIS IS AN ORIGINAL UNPUBLISHED DRAWING CREATED FOR YOUR PERSONAL USE IN CONNECTION WITH A PROJECT PLANNED FOR YOU BY NSMC. IT IS NOT TO BE SHOWN OUTSIDE YOUR ORGANIZATION NOR USED, REPRODUCED, COPIED OR EXHIBITED IN ANY FASHION UNLESS AUTHORIZED IN WRITING BY AN OFFICER OF NSMC

This sign intended to be in accordance with the requirements of Article 600 of the National Electrical Code and/or other applicable local codes. This includes proper grounding and bonding of this sign.

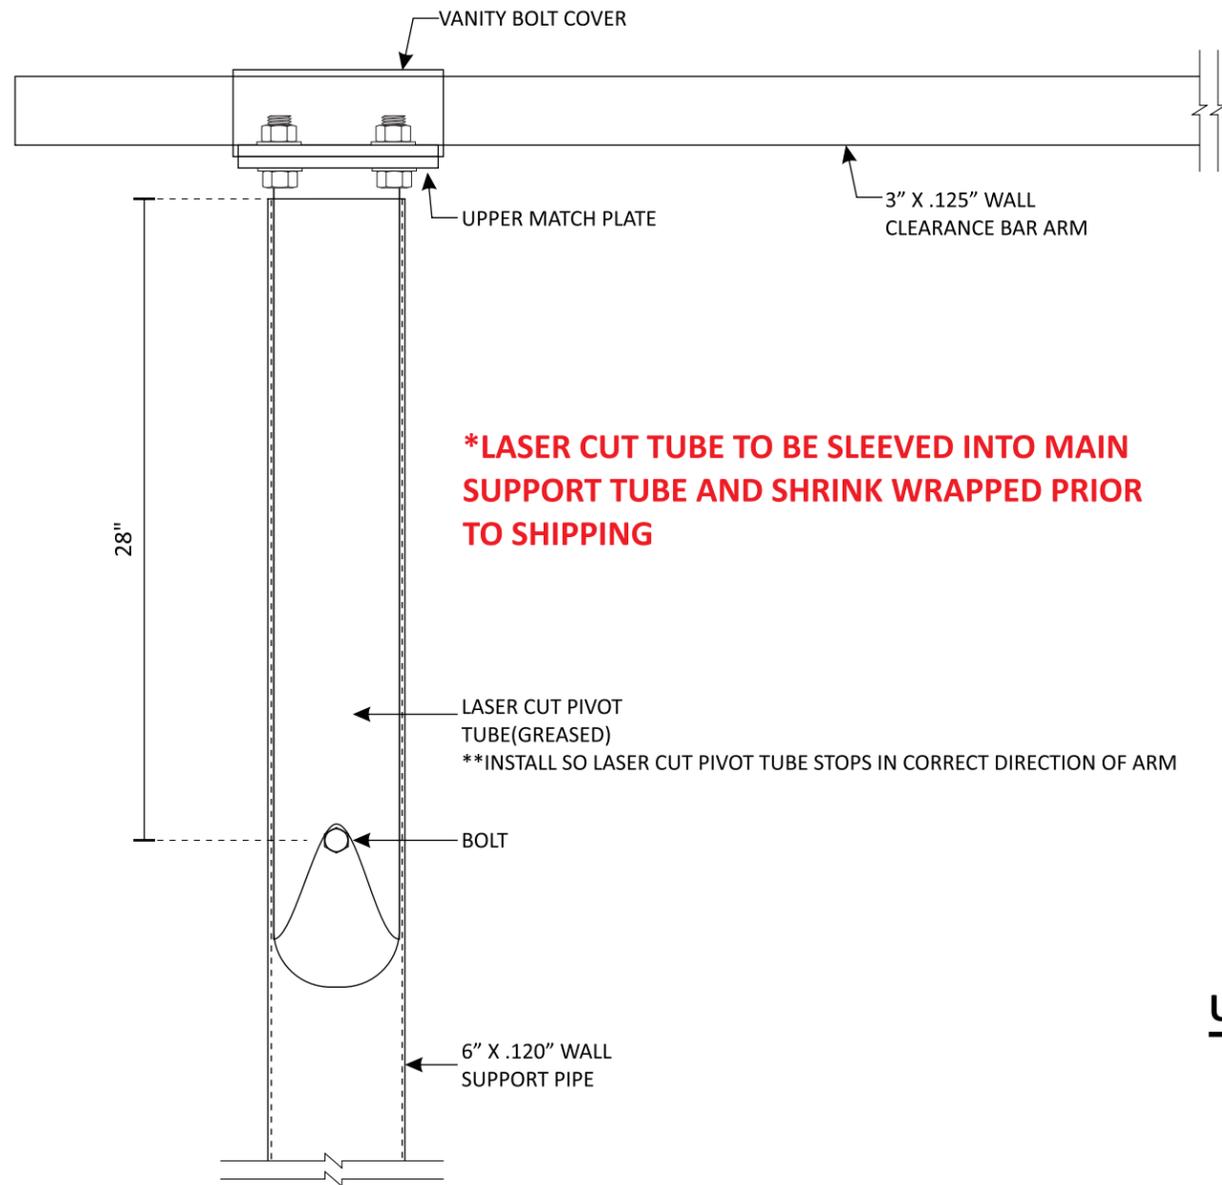

PIVOT ASSEMBLY DETAIL


SCALE: 1 1/2" = 1'-0"

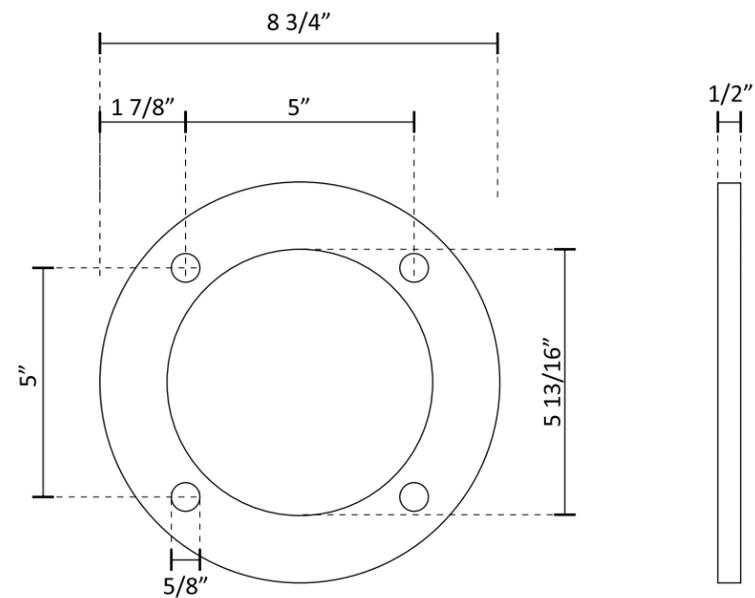

UPPER MATCH PLATE DETAIL

SCALE: 3" = 1'-0"

FOOTINGS BY OTHERS, FINAL SETTING BY NSMC

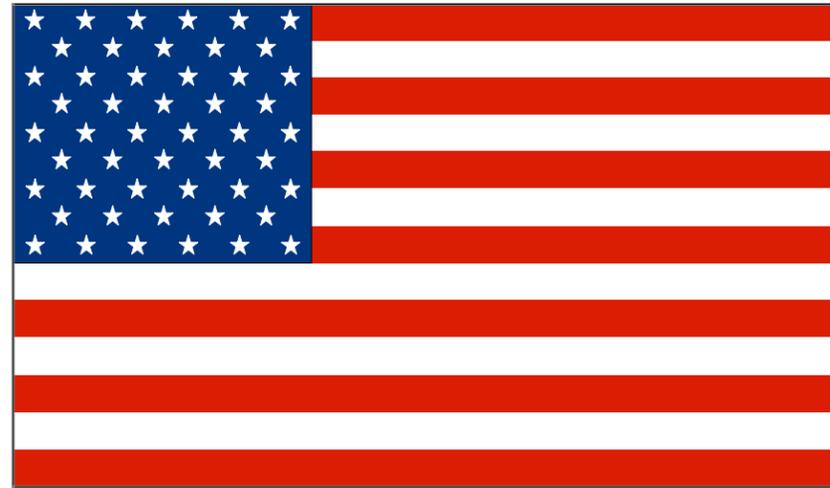

Flag


FOUNDATION SIZES

HEIGHT	A	B	C	FLAG SIZE
20'	3'-6"	30"	24"	6'-10'
25'	3'-6"	30"	24"	6'-10'
30'	3'-6"	30"	24"	6'-10'
35'	4'-0"	36"	30"	6'-10'
40'	4'-6"	42"	36"	12'-18'
45'	5'-0"	48"	42"	12'-18'
50'	5'-6"	48"	42"	12'-18'

Size Chart

Ground sleeve and concrete installed by the general contractor

Pole installed on pre-installed ground sleeve by sign contractor

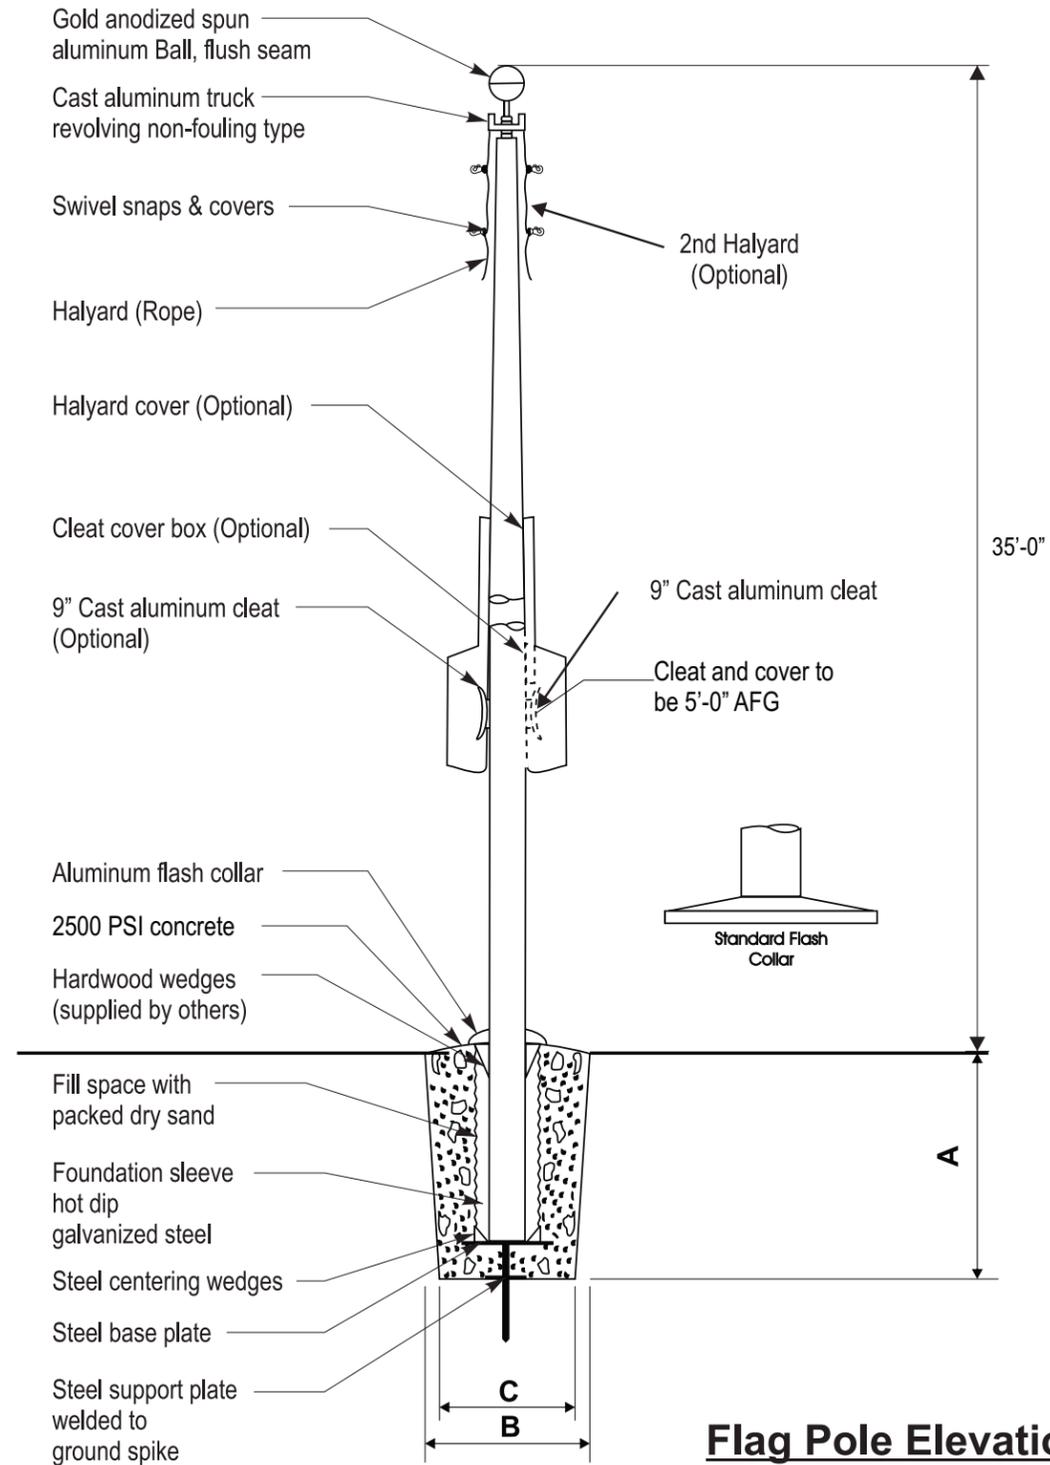

Flag Pole Elevation

CFA-00108 - CFA FPL EC35 FLAG POLE COMPLETE W/ FLAG POLE KIT & GROUND SLEEVE



National Sign & Marketing Corporation
 13580 5th St., Chino, CA 91710
 Tel 909.591.4742 Fax 909.747.6446
 e-mail: sales@nsmc.com
 Lic# 745030 - Exp. 01/31/26

Project Name:
 Chick-fil-A #5934
 Powers & Palmer Park

Address:
 SEC Power Blvd. & Palmer Park Blvd.
 Colorado Springs, CO.

Account Mgr.
 Steve Rosenbloom

Approved by:

Date:

Drawing Number
 31130R1

Revision

02/21/25 TB: Update A to canopy mounted, add C. Pylon goes to addendum.

Designer: T Behrman
Date: 01/10/2025

FLAG POLE

Page 28

Scale: NTS

THIS IS AN ORIGINAL UNPUBLISHED DRAWING CREATED FOR YOUR PERSONAL USE IN CONNECTION WITH A PROJECT PLANNED FOR YOU BY NSMC. IT IS NOT TO BE SHOWN OUTSIDE YOUR ORGANIZATION NOR USED, REPRODUCED, COPIED OR EXHIBITED IN ANY FASHION UNLESS AUTHORIZED IN WRITING BY AN OFFICER OF NSMC.

This sign intended to be in accordance with the requirements of Article 600 of the National Electrical Code and/or other applicable local codes. This includes proper grounding and bonding of this sign.



SURVEY REQUIRED PRIOR TO MANUFACTURE



SCALE: 1/4" = 1'-0"

F EXIST. D/F ILLUM. PYLON SIGN, TENANT PANEL ONLY

Sign Specs:

MAIN CABINET:	EXISTING
FACES:	WHITE ACRYLIC WITH APPLIED FIRST SURFACE 3M RED #3632-53 TRANSLUCENT VINYL.
ILLUMINATION:	EXISTING
SWITCH:	EXISTING

ALL COMPONENTS TO BE U.L. APPROVED

Colors:

	3M RED 3632-53
	MATTHEWS MP 74155 SV SATIN DARK BRONZE
	7328 WHITE ACRYLIC
	FINISHING MATERIAL



National Sign & Marketing Corporation
 13580 5th St., Chino, CA 91710
 Tel 909.591.4742 Fax 909.747.6446
 e-mail: sales@nsmc.com
 Lic# 745030 - Exp. 01/31/26

Project Name:

Chick-fil-A
 #5934
 Powers & Palmer Park

Address:

SEC Power Blvd. &
 Palmer Park Blvd.
 Colorado Springs, CO.

Account Mgr.

Steve Rosenbloom

Approved by:

Date:

Drawing Number

31130R1
 ADDENDUM 1

Revision

02/21/25 TB: Update A to canopy mounted.
 add C. Pylon goes to addendum.

Designer: T Behrman
Date: 01/10/2025

REFACE
 D/F ILLUMINATED
 PYLON/MONUMENT SIGN

Page 29

Scale: 3/4" = 1'-0"

THIS IS AN ORIGINAL UNPUBLISHED DRAWING CREATED FOR YOUR PERSONAL USE IN CONNECTION WITH A PROJECT PLANNED FOR YOU BY NSMC. IT IS NOT TO BE SHOWN OUTSIDE YOUR ORGANIZATION NOR USED, REPRODUCED, COPIED OR EXHIBITED IN ANY FASHION UNLESS AUTHORIZED IN WRITING BY AN OFFICER OF NSMC.

This sign intended to be in accordance with the requirements of Article 600 of the National Electrical Code and/or other applicable local codes. This includes proper grounding and bonding of this sign.

