

REV.	DATE	DESCRIPTION	BY	CHKD.
1	08/12/2021	ISSUE FOR PERMIT	DGD	...
2	08/12/2021	ISSUE FOR PERMIT	DGD	...
3	08/12/2021	ISSUE FOR PERMIT	DGD	...
4	08/12/2021	ISSUE FOR PERMIT	DGD	...
5	08/12/2021	ISSUE FOR PERMIT	DGD	...
6	08/12/2021	ISSUE FOR PERMIT	DGD	...
7	08/12/2021	ISSUE FOR PERMIT	DGD	...
8	08/12/2021	ISSUE FOR PERMIT	DGD	...
9	08/12/2021	ISSUE FOR PERMIT	DGD	...
10	08/12/2021	ISSUE FOR PERMIT	DGD	...
11	08/12/2021	ISSUE FOR PERMIT	DGD	...
12	08/12/2021	ISSUE FOR PERMIT	DGD	...
13	08/12/2021	ISSUE FOR PERMIT	DGD	...
14	08/12/2021	ISSUE FOR PERMIT	DGD	...
15	08/12/2021	ISSUE FOR PERMIT	DGD	...
16	08/12/2021	ISSUE FOR PERMIT	DGD	...
17	08/12/2021	ISSUE FOR PERMIT	DGD	...
18	08/12/2021	ISSUE FOR PERMIT	DGD	...
19	08/12/2021	ISSUE FOR PERMIT	DGD	...
20	08/12/2021	ISSUE FOR PERMIT	DGD	...
21	08/12/2021	ISSUE FOR PERMIT	DGD	...

DRAWN BY: DGD LATEST REV: A

WSEO SUBMITTAL




PROPRIETARY AND CONFIDENTIAL
 TO BE REPRODUCED IN COLOR
 PRINT SIZE: ARCH-D
 ISSUED BY: JWB
 SCALE: 1/8"=1'-0"
 SCALE: NTS
 DWG.#:

E104
 SITE LIGHTING PLAN - SECTIONS 3, 4, 5


- ### GENERAL NOTES
- 1 THE PROJECT DOES NOT INCLUDE ANY REGULARLY SCHEDULED DAYTIME LIGHTING.
 - 2 TEMPORARY LIGHTING IS LIMITED TO LOCATIONS IDENTIFIED HERE WITHIN AND WILL ONLY BE ALLOWED FOR MAINTENANCE OF THE FACILITY.
 - 3 DURING OPERATION, THE PROJECT WILL ABIDE BY EL PASO COUNTY LIGHTING ORDINANCE AT ALL TIMES INCLUDING LUMEN LIMITATIONS AT PROPERTY LINES.
 - 4 NO LIGHTING IS PROPOSED FOR CONSTRUCTION.
 - 5 LIGHTING SHALL NOT EXCEED 0.1 FOOT CANDLES AT PROPERTY BOUNDARY. AVERAGE LUMINESCENCE AT PROPERTY BOUNDARY = 0.00 FOOT CANDLES

- ### LEGEND
- PROJECT FENCE
 - PROPERTY BOUNDARY
 - SITE ACCESS ROAD
 - EXISTING CSU ROAD
 - STAGING/PARKING AREA
 - TRACKER ARRAY OUTLINE
 - POWER STATION
 - O&M SHED


- ### KEYNOTES
- 1 SUBSTATION CONTROL BUILDING
 - 2 POWER STATION (TYPICAL)
 - 3 TRACKER BLOCK (TYPICAL)
 - 4 O&M SHED
 - 5 40'x8' BATTERY ENERGY STORAGE CONTAINER (TYPICAL)

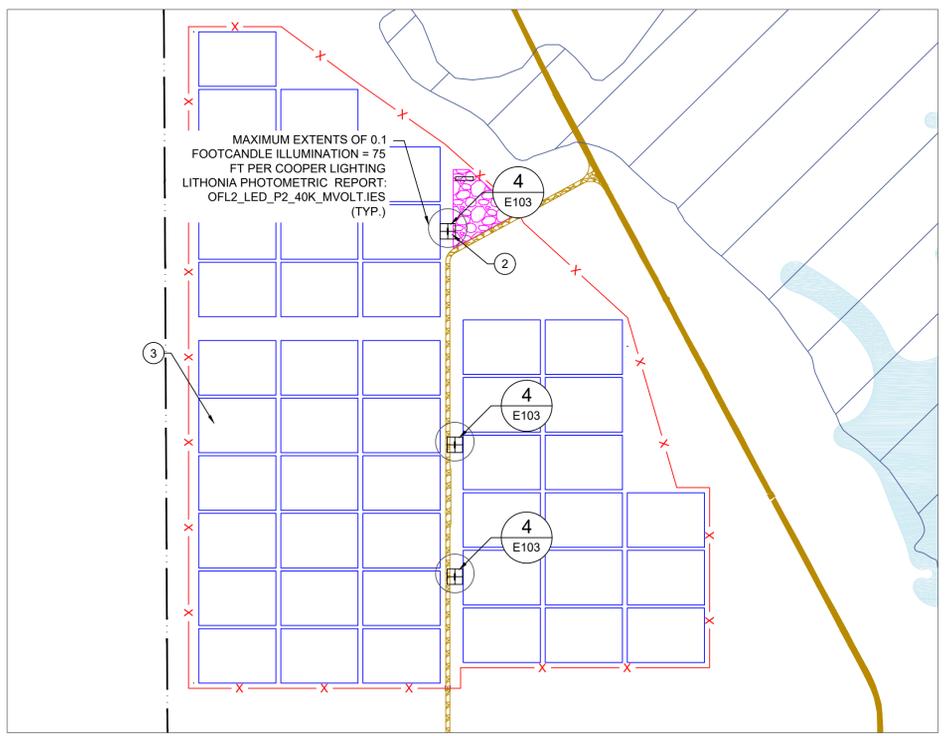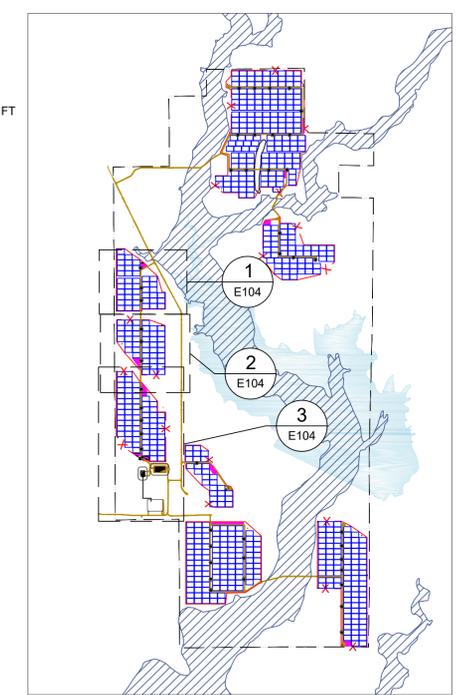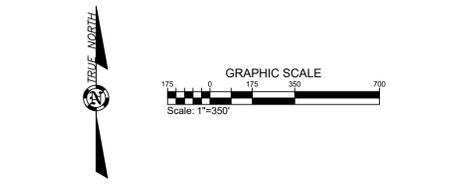

1 SECTION 3 - PLAN VIEW
 E104 SCALE: 1"=325'

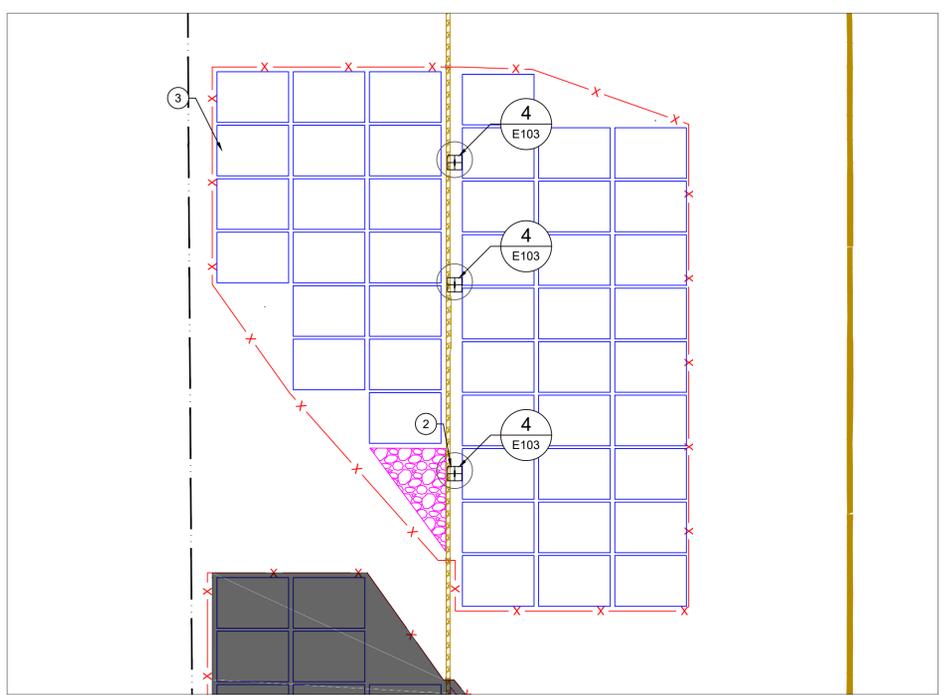

2 SECTION 4 - PLAN VIEW
 E104 SCALE: 1"=325'

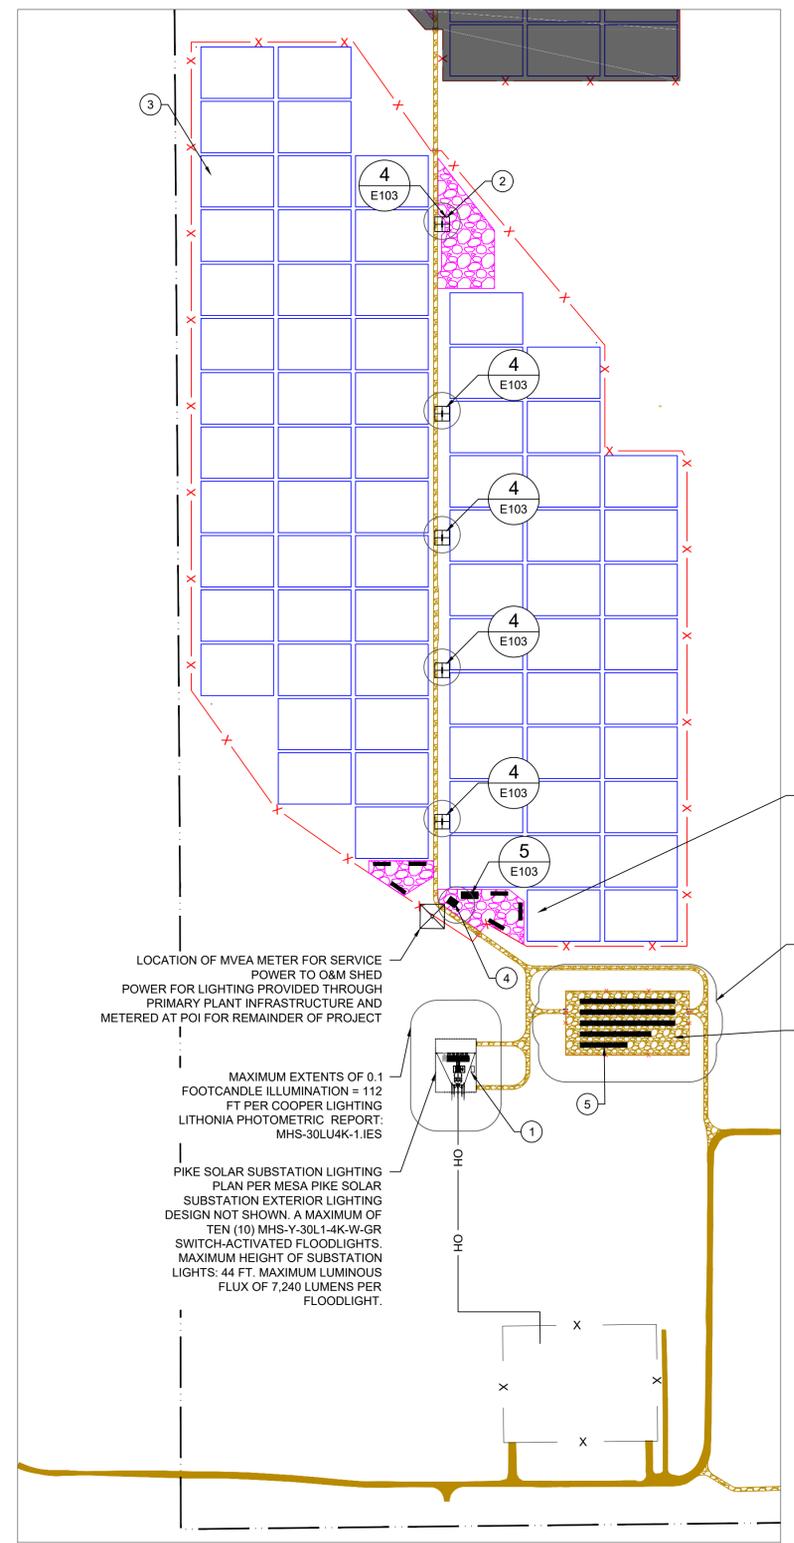

3 SECTION 5 - PLAN VIEW
 E104 SCALE: 1"=325'

4 REFERENCE MAP
 E104 SCALE: NTS