

LIGHTING FIXTURE SCHEDULE				
SYMBOL	LAMP	MTG HEIGHT	DESCRIPTION	MANUFACTURER
A	LED, 120V	MOUNT ON CEILING	4 FOOT FIXTURE-HEAVY DUTY AND MOUNTING HARDWARE SUITABLE FOR WET LOCATIONS	LSI EC3-4-LED-06L-DA-S-UNV-DIM-40-80
W1	LED, 120V	7 FT. ABOVE DOOR OR 10 FT ABOVE GRADE	DIECAST ALUMINUM FOR RUGGED MOUNTING AND HEAT DISSIPATION, SPECULAR REFLECTOR, VERTICAL LAMP AND REFRACTOR WITH PHOTOELECTRIC CONTROL	LSI WLS LED 3L UNV DIM 40 BLK PC120


Will these lights be mounted on the structure or free standing?

Please show foot candles measured to the north property line (ROW).

YELLOW PLASTIC CAP (LS 11624) FOUND ON LINE, 3.5' NORTH

3-1/4" ALUMINUM CAP (C00T PLS 10734) FOUND ON LINE, 34.4' WEST

SOUTH RoW IN NE 1/4, SEC. 14 BY BK. 978, PG. 99

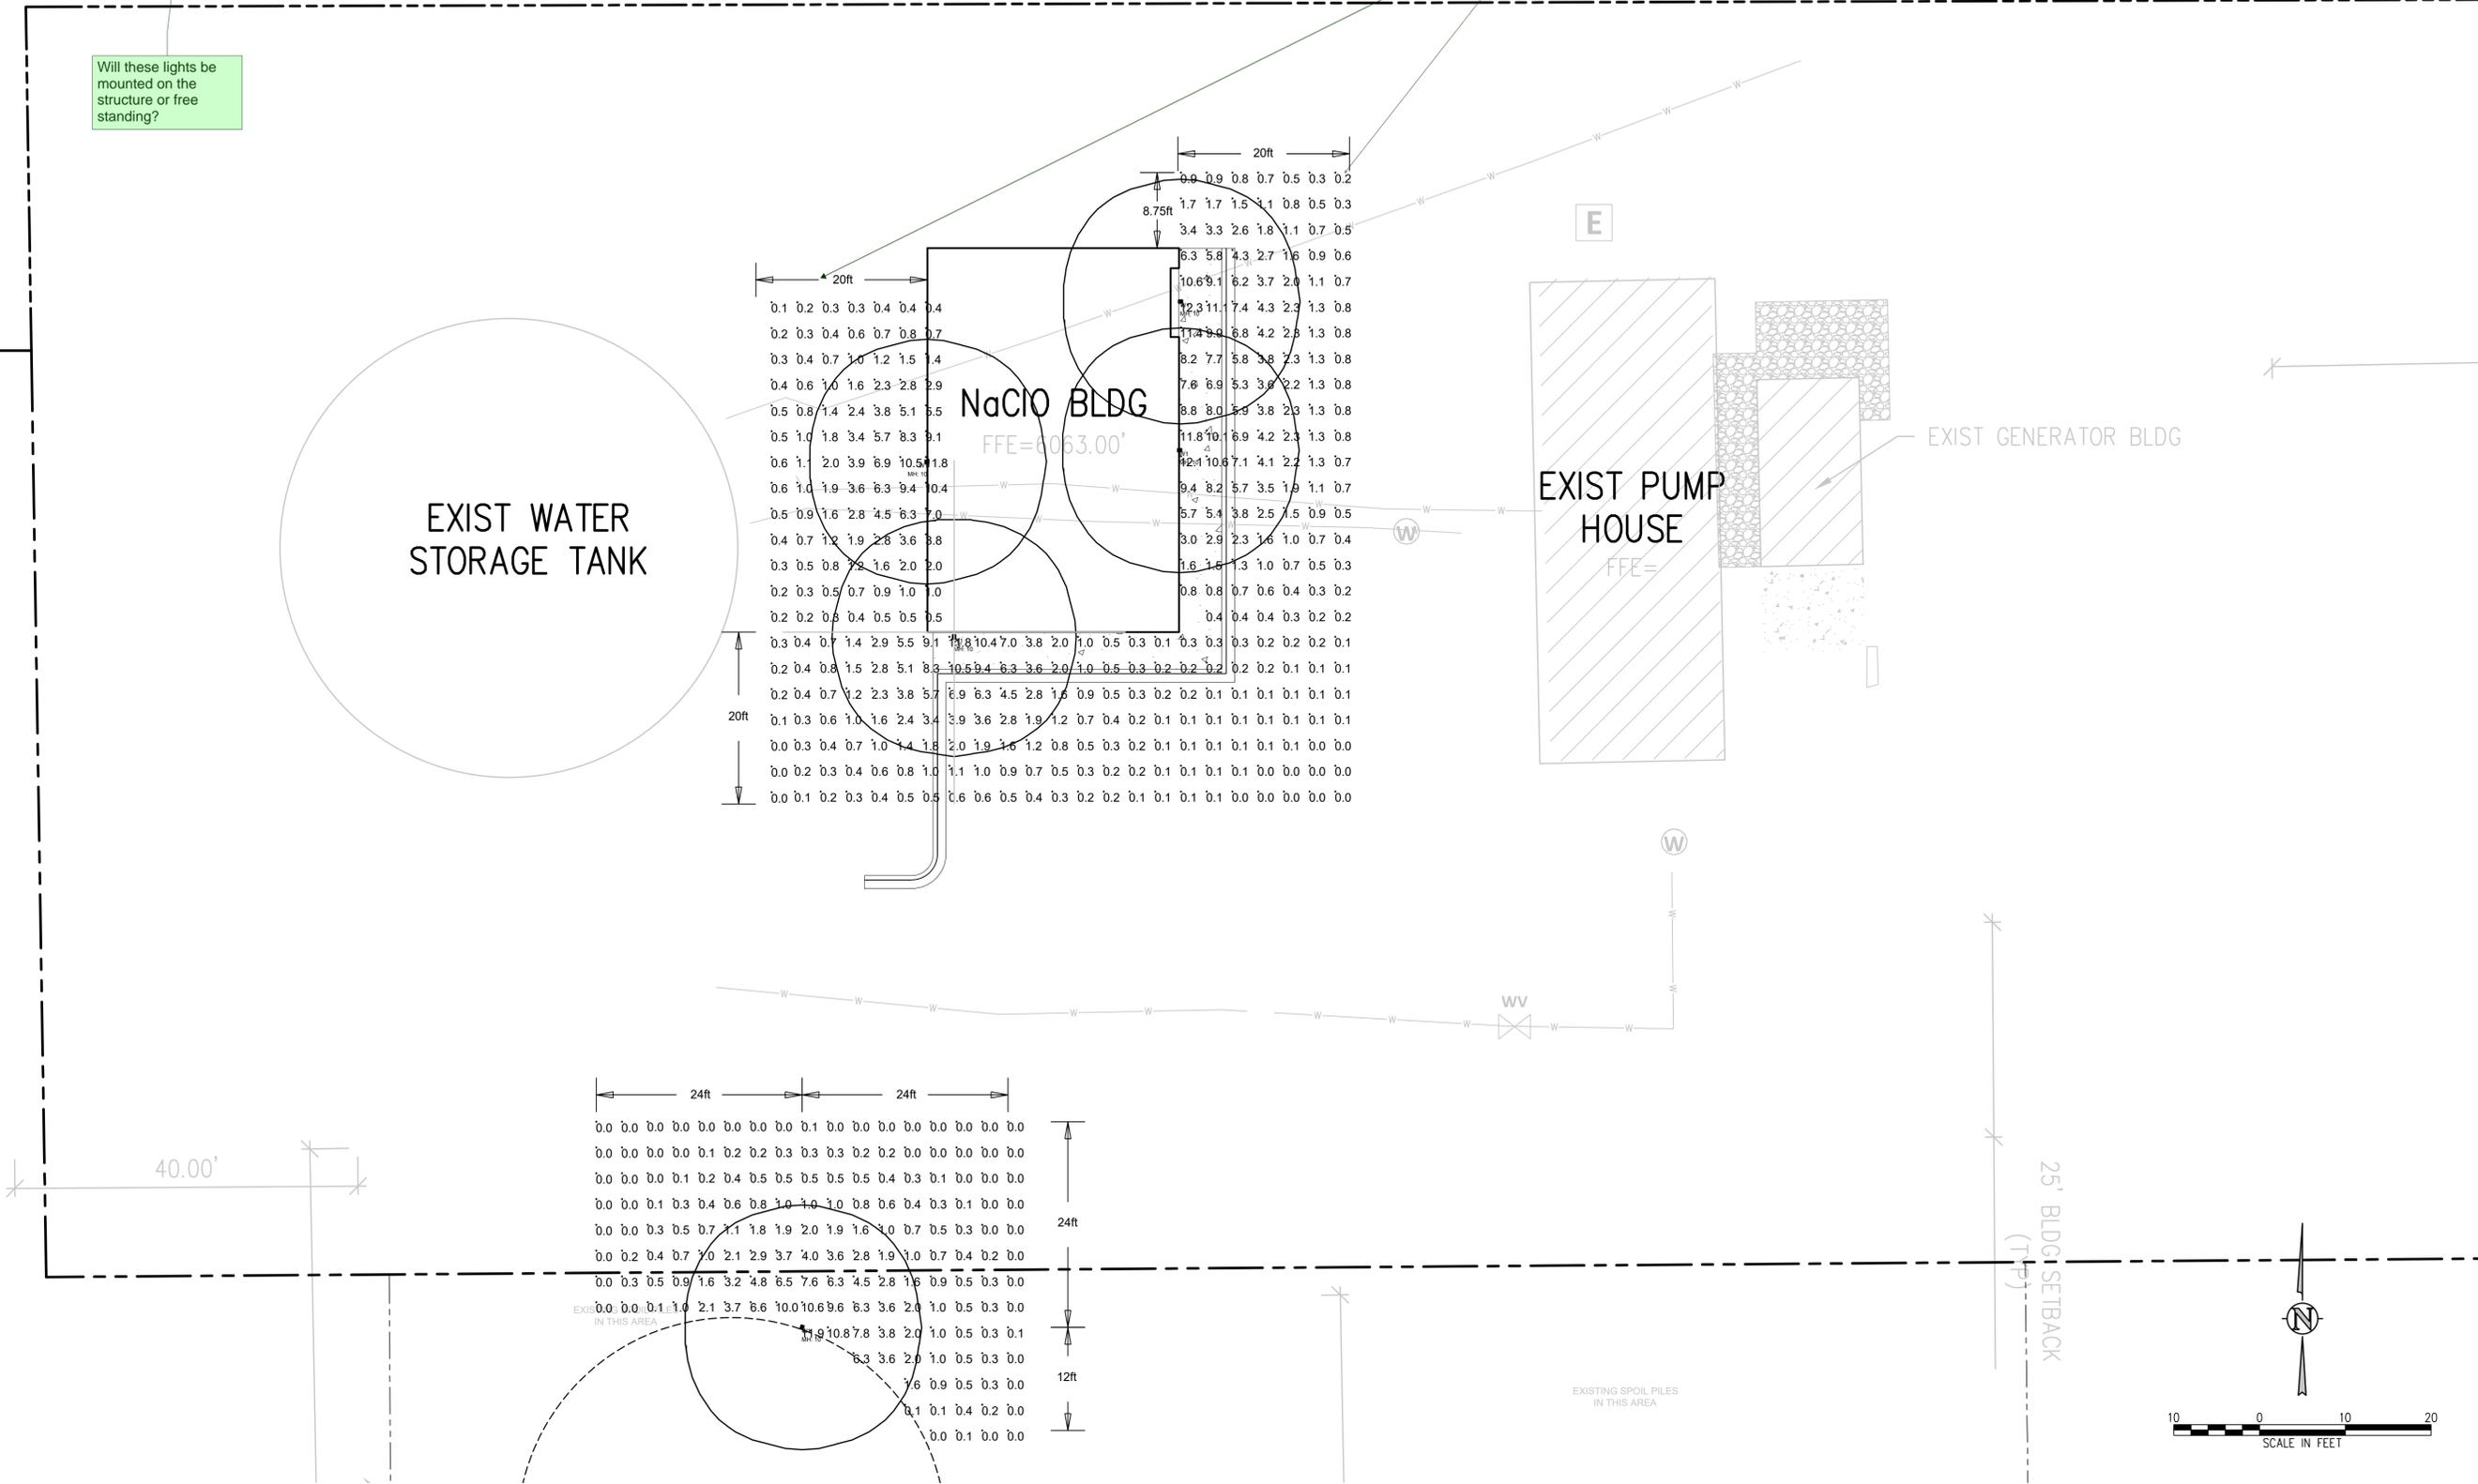

NO.	DATE	DES'D	DWN	REVISION DESCRIPTION

DESIGNED BY: TRW
 DRAWN BY: TRW
 CHECKED BY: TFW
 JOB #: 1164.1e
 DATE: AUGUST 2023
 © JVA, INC.

ELLCOTT CHLORINATOR UPGRADES
 CHEROKEE METROPOLITAN DISTRICT
 EL PASO COUNTY, COLORADO

PHOTOMETRIC STUDY

SHEET NO.
E1.5