



2022/02/23 10:20 AM By: Shelby Coffin NA\Project\151 Meridian Service Metropolitan District\151.52 Wtp Expansion - Sep Drawings\Working\15152_1_Photometric-Plan.dwg

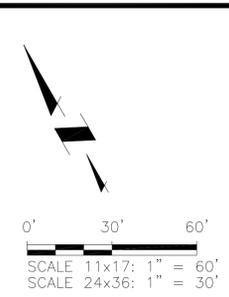

D-Series Size 1 LED Wall Luminaire

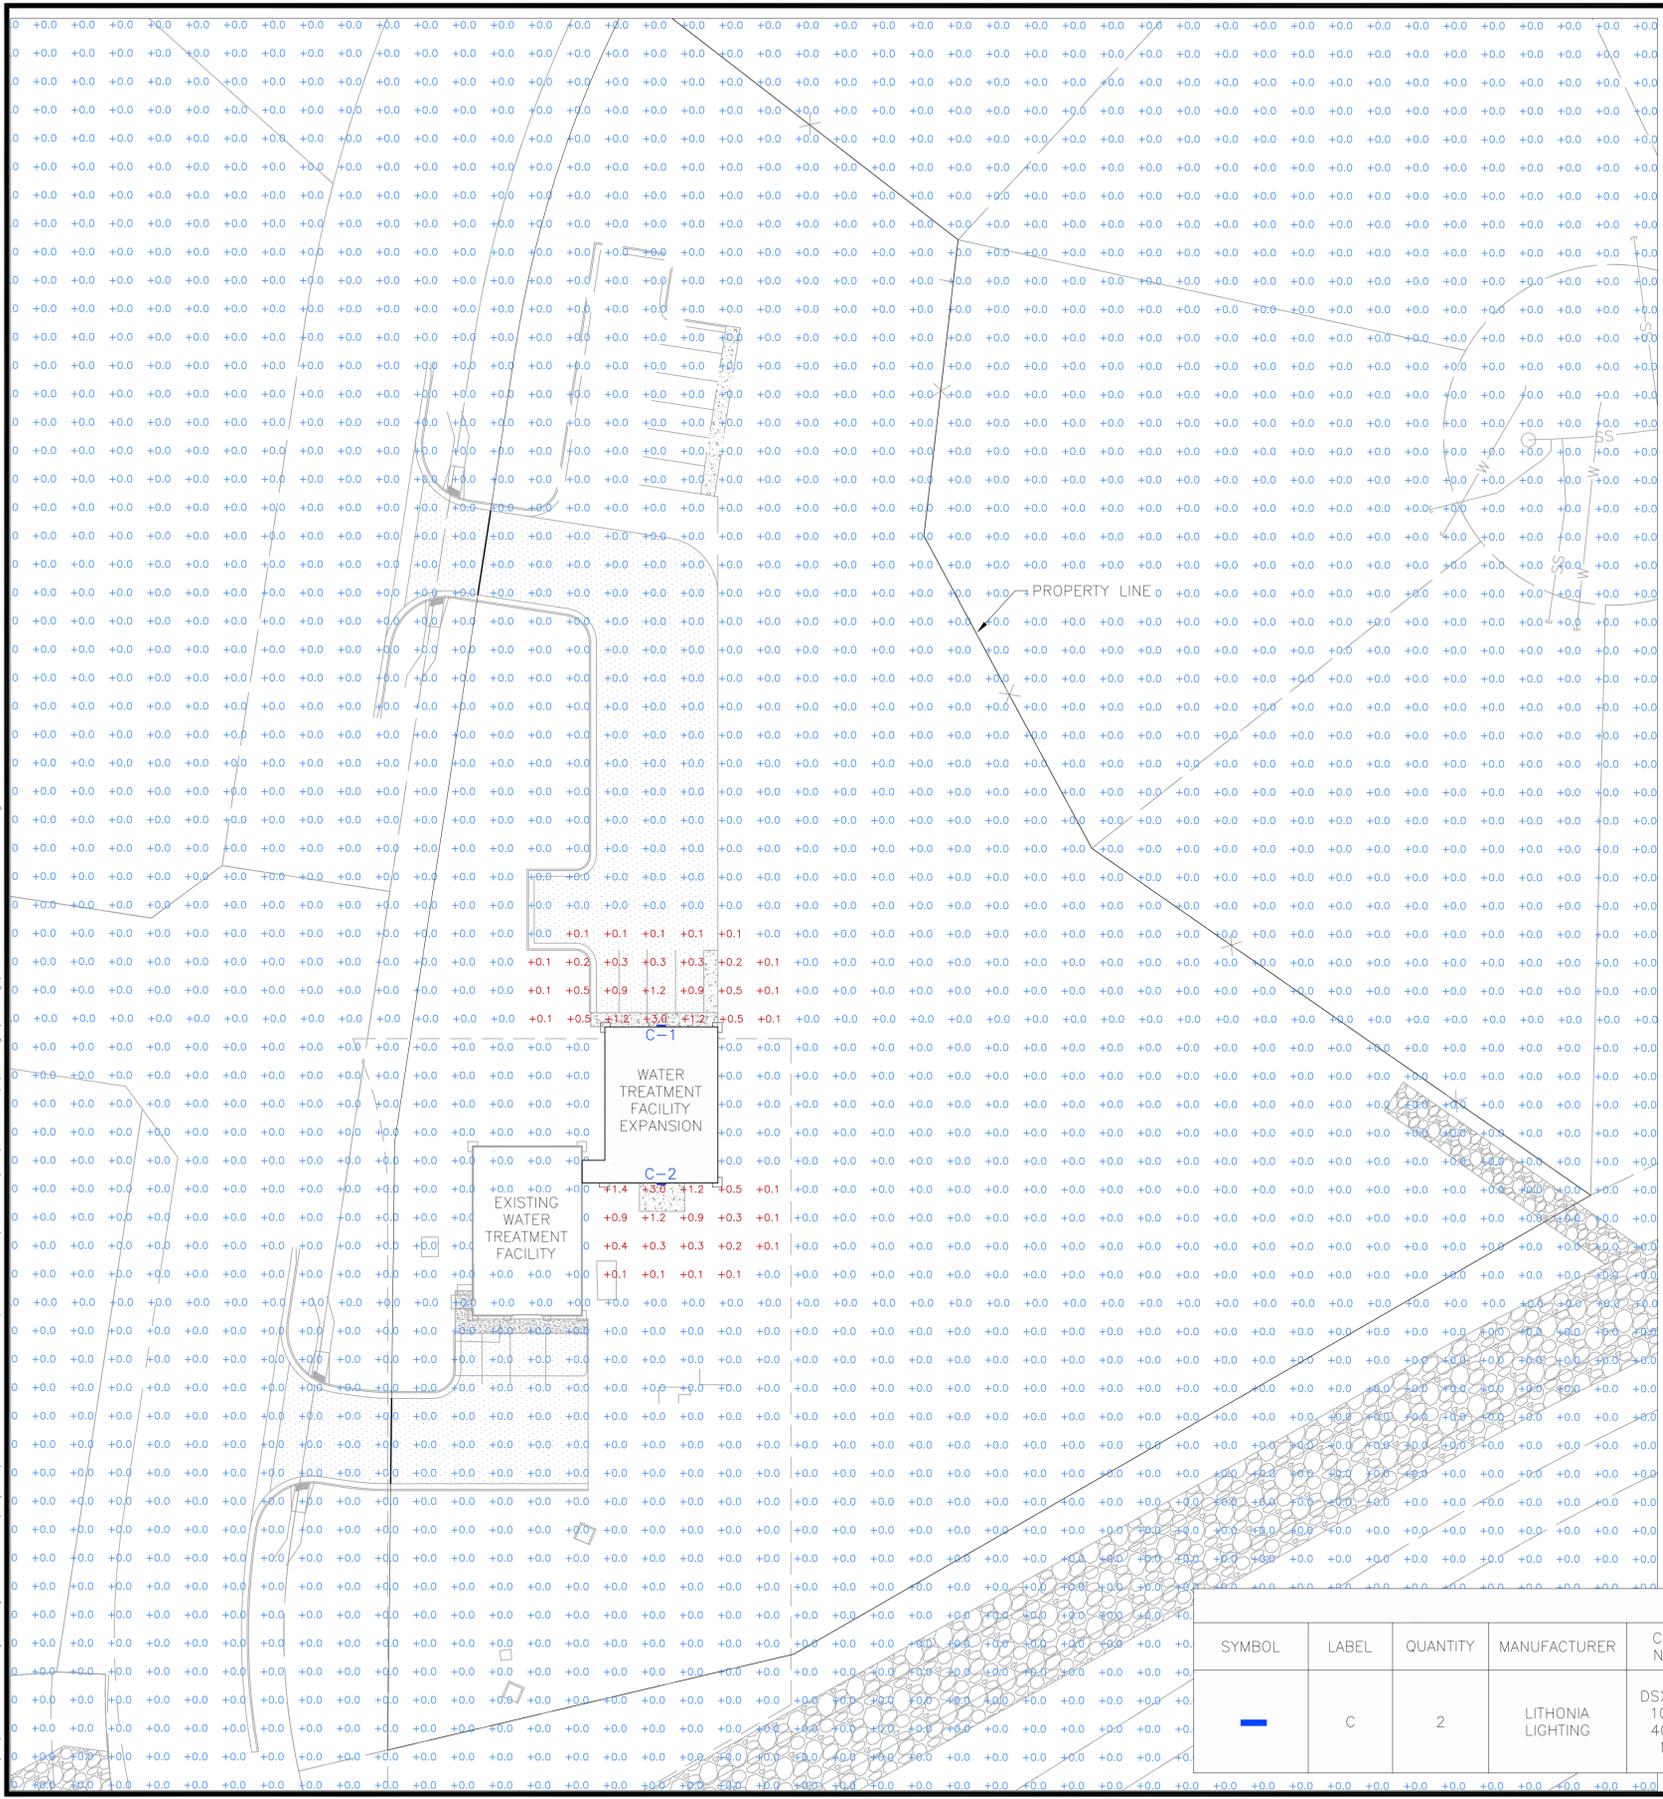

d^{series}


Specifications Luminaire

Width: 13-3/4" (34.9 cm)
Depth: 10" (25.4 cm)
Height: 6-3/8" (16.2 cm)

Weight: 12 lbs (5.4 kg)

Back Box (BBW, ELCW)

Width: 13-3/4" (34.9 cm) **BBW Weight:** 5 lbs (2.3 kg)
Depth: 4" (10.2 cm) **ELCW Weight:** 10 lbs (4.5 kg)
Height: 6-3/8" (16.2 cm)

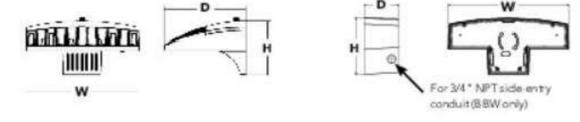

Catalog Number	DSWX1-10C-350-40K-T3M-120-DBLXD-PE
Notes	
Type	C

Introduction
 The D-Series Wall Luminaire is a stylish, fully integrated LED solution for building-mount applications. It features a sleek, modern design and is carefully engineered to provide long-lasting, energy-efficient lighting with a variety of optical and control options for customized performance.
 With an expected service life of over 20 years of nighttime use and up to 74% in energy savings over comparable 250W metal halide luminaires, the D-Series Wall is a reliable, low-maintenance lighting solution that produces sites that are exceptionally illuminated.

STATISTICS						
DESCRIPTION	SYMBOL	AVG	MAX/MIN	AVG/MIN	MIN	MAX
CALC ZONE #7		0.0 fc	N/A	N/A	0.0 fc	3.0 fc

SCHEDULE											
SYMBOL	LABEL	QUANTITY	MANUFACTURER	CATALOG NUMBER	LAMP	NUMBER LAMPS	FILENAME	LUMENS PER LAMP	LIGHT LOSS FACTOR	WATTAGE	DESCRIPTION
■	C	2	LITHONIA LIGHTING	DSWX1 LED 10C 350 40K T3M MVOLT	LED	1	DSWX1_LED_10C_350_40K_T3M_MVOLT.ies	1488	0.9	13.3	DSWX1 LED WITH (1) 10 LED LIGHT ENGINES, TYPE T3M OPTIC, 4000K, @ 350mA.

JDS-HYDRO CONSULTANTS, INC.
 5540 TECH CENTER DR., SUITE 100
 COLORADO SPRINGS, COLORADO 80919
 (719) 227-0072
UNLESS THE CONTRACTOR SHALL VERIFY ALL DIMENSIONS, ANY ERRORS OR OMISSIONS SHALL BE REPORTED TO JDS-HYDRO CONSULTANTS, INC. JDS-HYDRO ASSUMES NO LIABILITY FOR UNAUTHORIZED CHANGES AND/OR REVISIONS MADE TO PLANS.

MERIDIAN SERVICE METROPOLITAN DISTRICT
 WATER TREATMENT PLANT EXPANSION
 LIGHTING PLAN

NO.	DESCRIPTION	BY	APP.	DATE
1				
2				
3				
4				
5				
6				
7				

FOR REVIEW

Project No.: 151.52
 Date: 02/23/22
 Design: RMM
 Drawn: SKG
 Check: RMM

C4
 SHEET OF