



2022/11/04 3:13 PM By: Gina Mangino N:\Projects\224 Triview Metro District\224.29 Northern Regional Water Delivery Project - Phase 2\Drawings\Working\Segment A - Pump Station\06_Architectural\224029_Arch.dwg

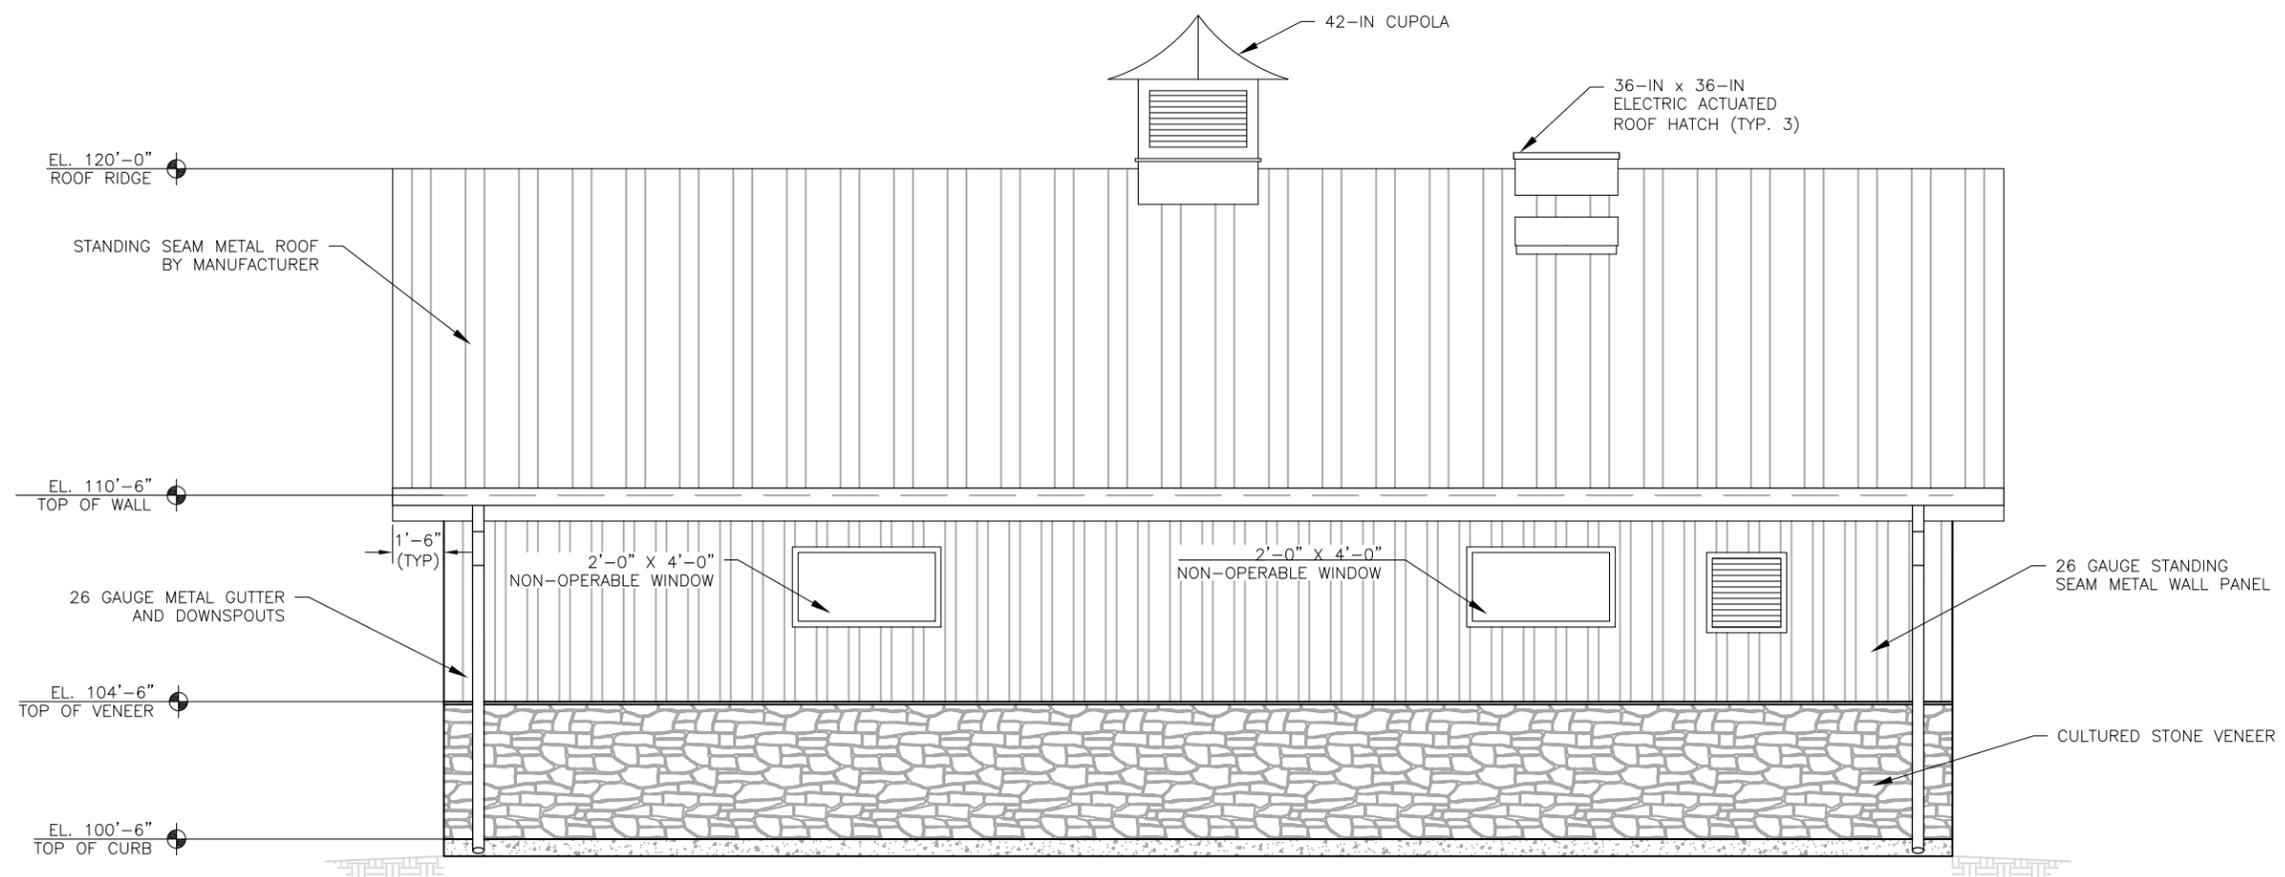

EAST ELEVATION
SCALE: 3/16" = 1'-0"

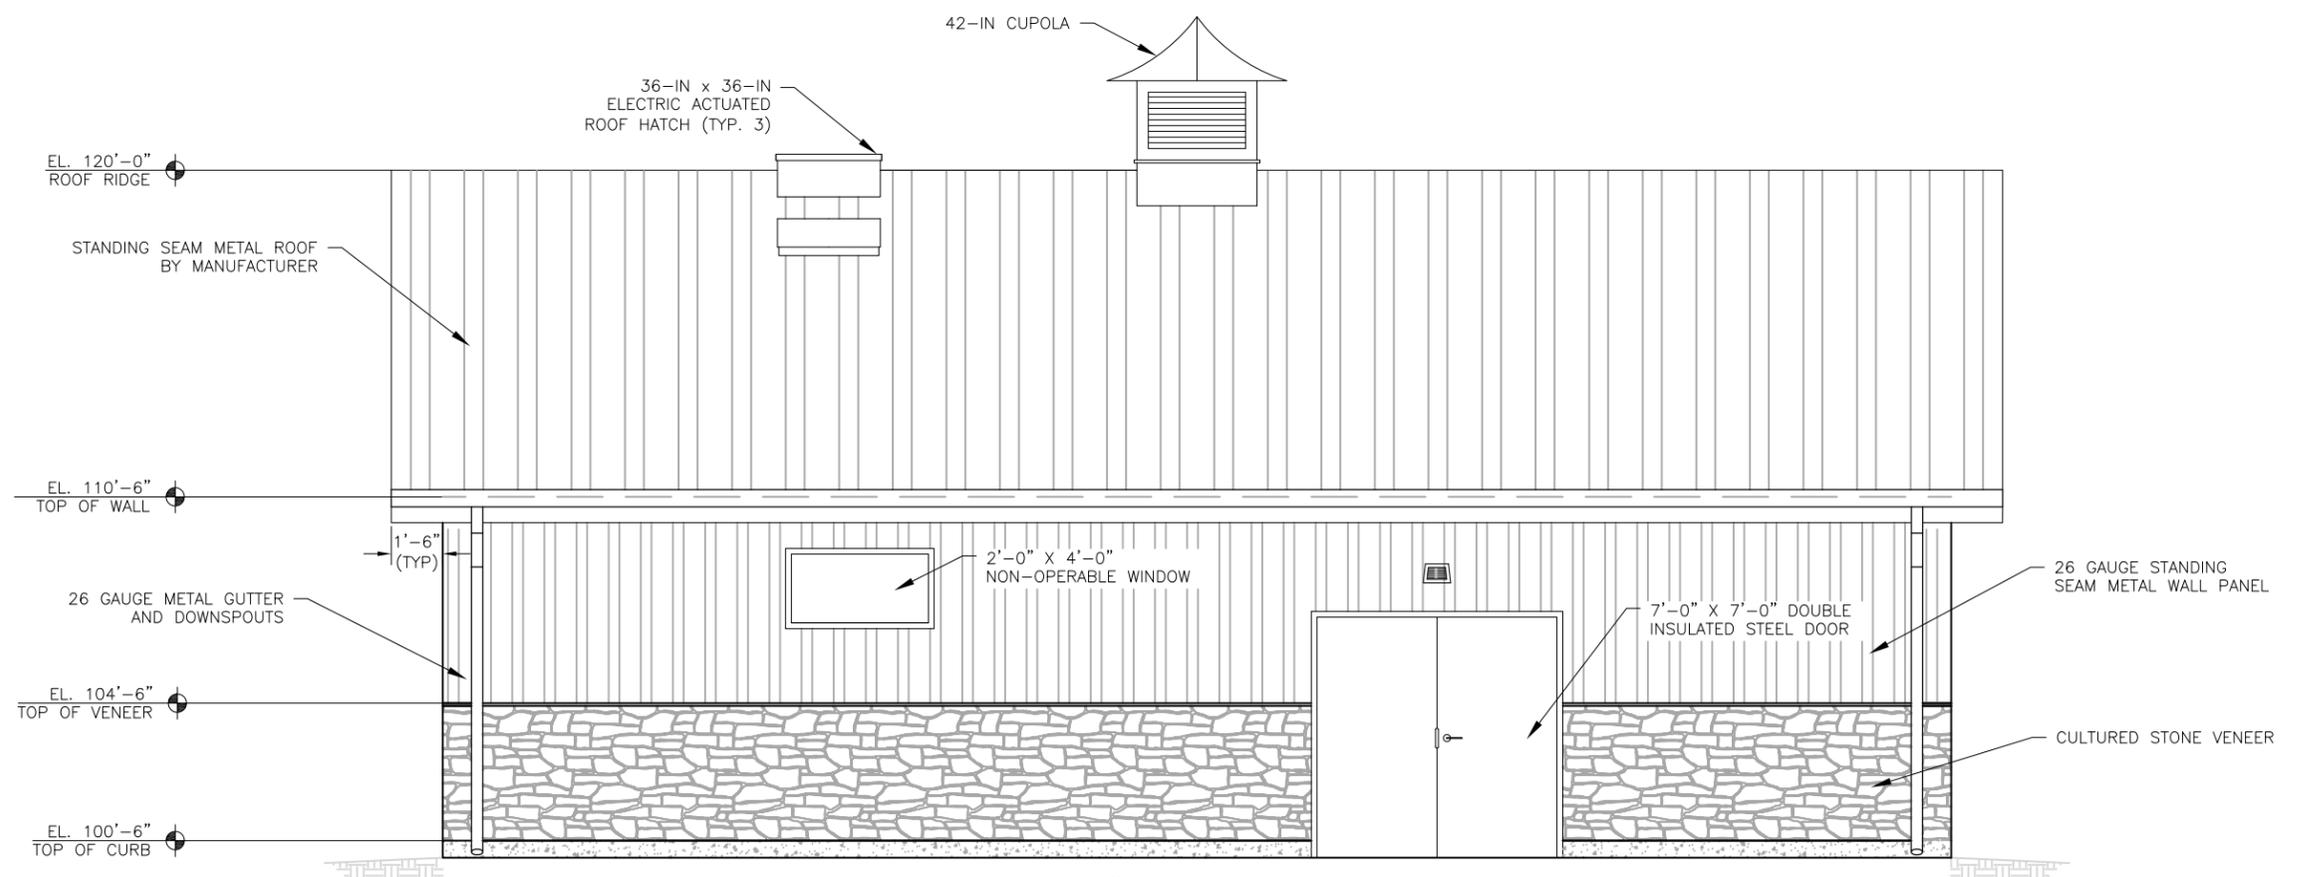

WEST ELEVATION
SCALE: 3/16" = 1'-0"

JDS-HYDRO a Division of **RESPEC**
5540 TECH CENTER DR., SUITE 100
COLORADO SPRINGS, COLORADO 80919
(719) 227-0072
DISCLAIMER: THE CONTRACTOR SHALL VERIFY ALL DIMENSIONS. ANY ERRORS OR OMISSIONS SHALL BE REPORTED TO JDS-HYDRO, A DIVISION OF RESPEC. JDS-HYDRO ASSUMES NO LIABILITY FOR UNAUTHORIZED CHANGES AND/OR REVISIONS MADE TO PLANS.

TRIVIEW METROPOLITAN DISTRICT
NORTHERN DELIVERY SYSTEM - BOOSTER PUMP STATION
EAST & WEST BUILDING ELEVATIONS

NO.	DESCRIPTION	BY	APP.	DATE
1				
2				
3				
4				
5				
6				
7				


FOR REVIEW

Project No.: W224.21029
Date: 09/12/22
Design: MLD
Drawn: AMY
Check: MLD


PCD File No. **PPR-XX-XXX**

A3
SHEET --- OF ---

2022/11/04 3:14 PM By: Gina Mangino N:\Projects\224 Triview Metro District\224.29 Northern Regional Water Delivery Project - Phase 2\Drawings\Working\Segment A - Pump Station\06_Architectural\224029_Arch.dwg

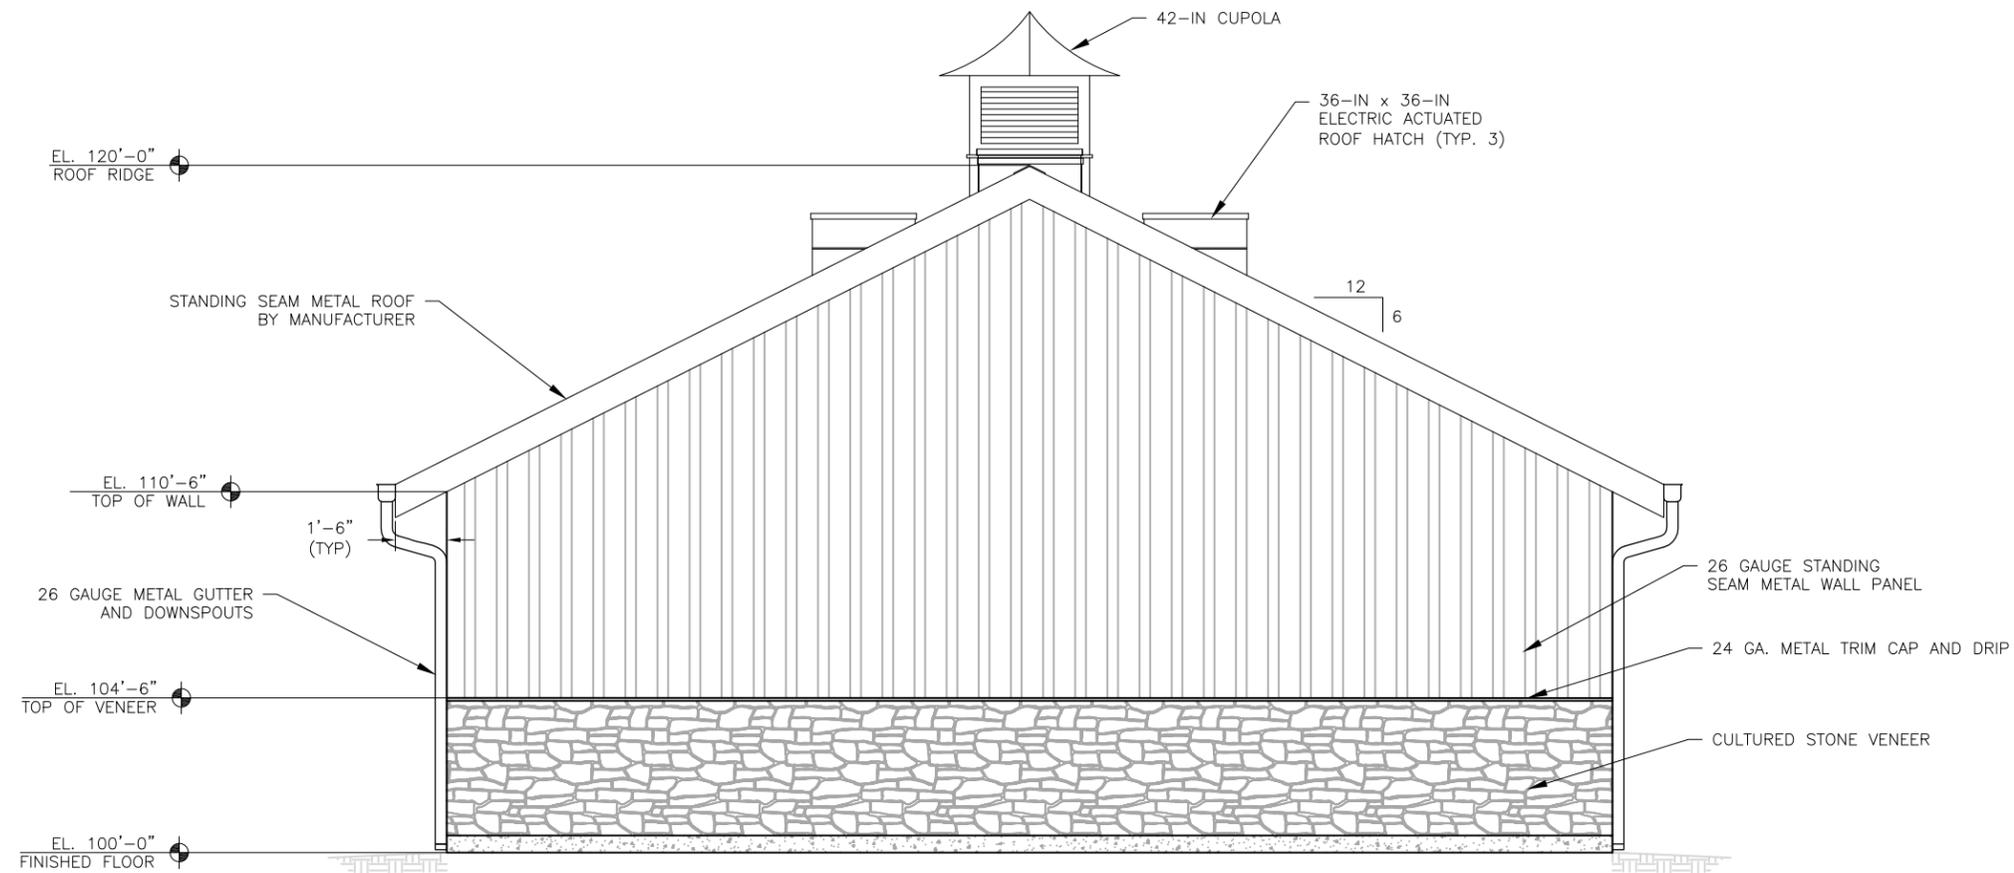

NORTH ELEVATION
SCALE: 3/16" = 1'0"

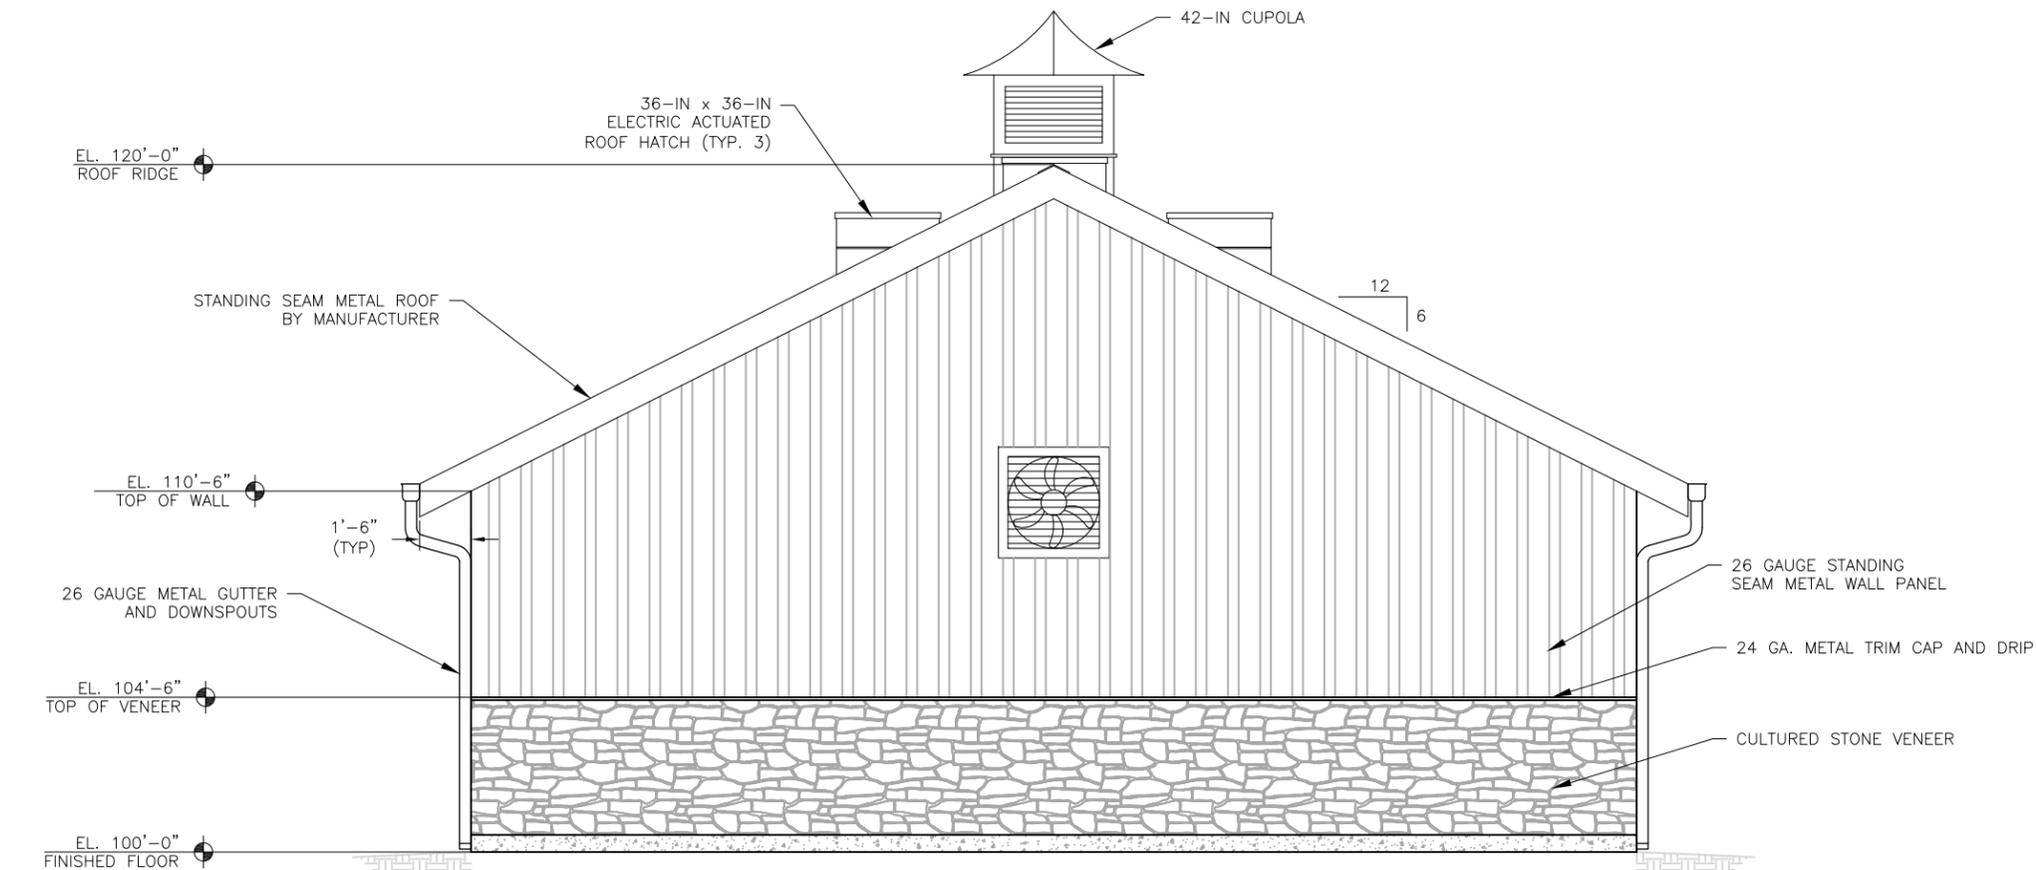

SOUTH ELEVATION
SCALE: 3/16" = 1'0"

JDS-HYDRO a Division of **RESPEC**
5540 TECH CENTER DR., SUITE 100
COLORADO SPRINGS, COLORADO 80919
(719) 227-0072
DISCLAIMER: THE CONTRACTOR SHALL VERIFY ALL DIMENSIONS. ANY ERRORS OR OMISSIONS SHALL BE REPORTED TO JDS-HYDRO, A DIVISION OF RESPEC. JDS-HYDRO ASSUMES NO LIABILITY FOR UNAUTHORIZED CHANGES AND/OR REVISIONS MADE TO PLANS.

TRIVIEW METROPOLITAN DISTRICT
NORTHERN DELIVERY SYSTEM - BOOSTER PUMP STATION
NORTH & SOUTH BUILDING ELEVATIONS

NO.	DESCRIPTION	BY	APP.	DATE
1				
2				
3				
4				
5				
6				
7				

FOR REVIEW

Project No.: W224.21029
Date: 09/12/22
Design: MLD
Drawn: AMY
Check: MLD

PCD File No. **PPR-XX-XXX**

A4
SHEET --- OF ---