


Statistics						
Description	Symbol	Avg	Max	Min	Max/Min	Avg/Min
ENTRANCE CANOPY	+	48.2 fc	61.5 fc	15.5 fc	4.0:1	3.0:1
PROPERTY BOUNDARY	+	0.0 fc	0.0 fc	0.0 fc	N/A	N/A
SITE	+	1.3 fc	27.2 fc	0.0 fc	N/A	N/A

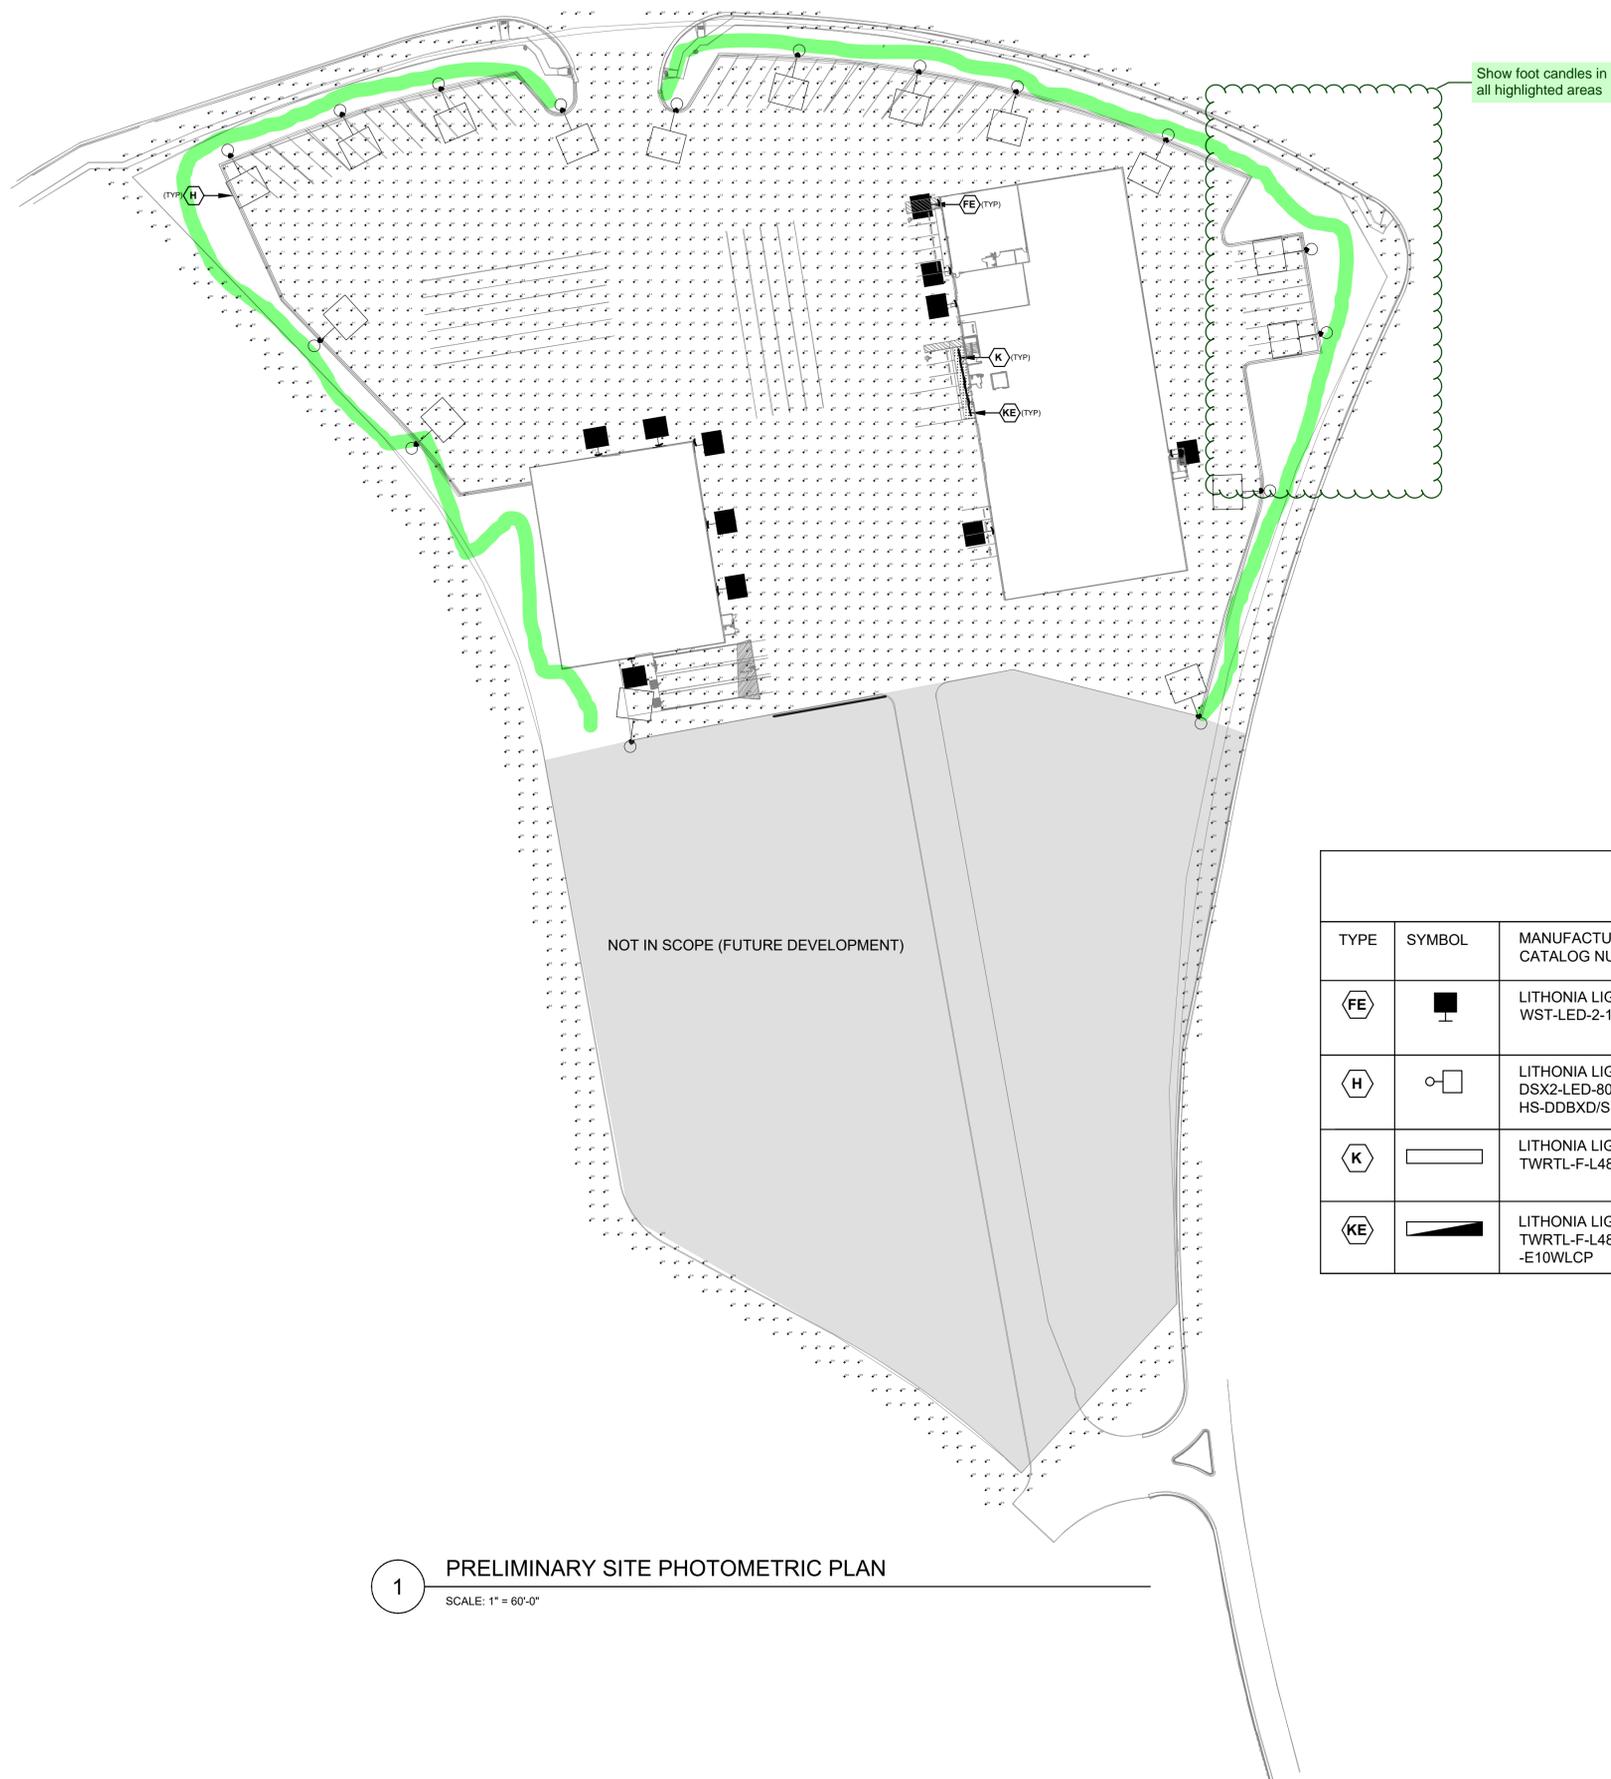

LIGHTING FIXTURE SCHEDULE

TYPE	SYMBOL	MANUFACTURER CATALOG NUMBER	FIXTURE WATTS	VOLTS	DESCRIPTION	LOCATION	MOUNTING HEIGHT
FE	■	LITHONIA LIGHTING # WST-LED-2-10A700/40K-SR4-MVOLT-ELCW-DDBXD	47	MULTI	EXTERIOR WALLPACK FULL CUTOFF TYPE 4 OPTIC WITH EMERGENCY BATTERY	BUILDING FACADE ABOVE DOORS	8'-0" AFG TO BOTTOM OF FIXTURE OR LANDING
H	□	LITHONIA LIGHTING # DSX2-LED-80C-1000-30K-T4M-MVOLT-SPA-HS-DDBXD/SSS-17.5' WITH 2.5' BASE	275	MULTI	POLE MOUNTED AREA TYPE T4M OPTICS WITH HOUSE SIDE SHIELD.	SITE GENERAL	20'-0" AFG TO BOTTOM OF FIXTURE
K	▬	LITHONIA LIGHTING # TWRTL-F-L48-3000LM-AFL-MVOLT-GZ1-30K-80CRI	27	MULTI	TANDEM 4' LED LUMINIARE.	BUILDING FRONT AND STORAGE CANOPIES	RECESSED IN ENTRANCE CANOPY
KE	▬	LITHONIA LIGHTING # TWRTL-F-L48-3000LM-AFL-MVOLT-GZ1-30K-80CRI -E10WLCP	27	MULTI	TANDEM 4' LED LUMINIARE WITH EMERGENCY BATTERY PACK.	BUILDING FRONT AND STORAGE CANOPIES	RECESSED IN ENTRANCE CANOPY

1 PRELIMINARY SITE PHOTOMETRIC PLAN
SCALE: 1" = 60'-0"

REVISIONS:

NO.	DATE	INITIALS	NOTES
1			
2			
3			
4			
5			
6			
7			
8			

PROFESSIONAL SEAL:

FOR REFERENCE ONLY

ARCHITECT LOGO:

AESUS
designgroup
Architecture, Engineering,
and Sustainable Design
1050 E. Southern Ave, Suite #D,
Tempe, Arizona 85282
(480) 454-2861

U-HAUL

U-HAUL INTERNATIONAL
CONSTRUCTION DEPARTMENT
2727 NORTH CENTRAL AVENUE
PHOENIX, ARIZONA 85004
PH: (602) 263-6502

SITE ADDRESS:

U-Haul at Falcon
Rolling Thunder Way
Falcon, CO 80831

SHEET CONTENTS:

PRELIMINARY SITE
PHOTOMETRIC
PLAN

866077

DRAWN:	AESUS
CHECKED:	AESUS
DATE:	07/22/22

866077_PRELIMINARY SITE PHOTOMETRICS

© 2022 AMERCO REAL ESTATE COMPANY