




**TANK PROFILE**  
SCALE: 1" = 10'

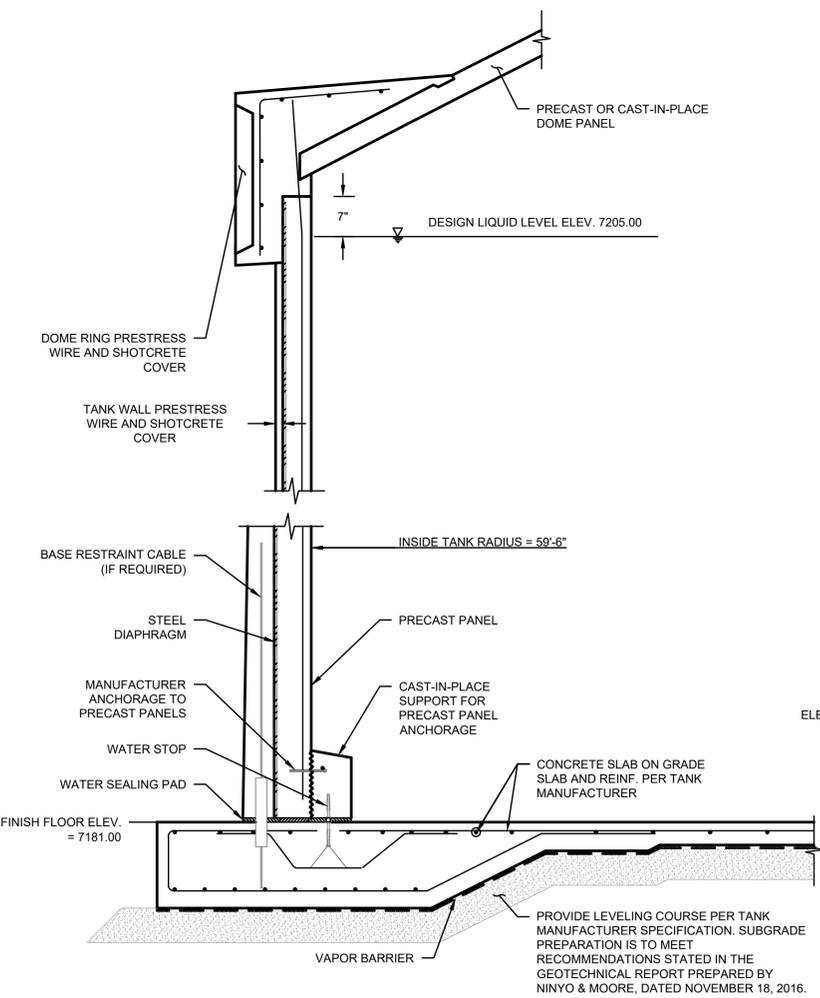


**TANK WALL SECTION**  
SCALE: 3/4" = 1'-0"

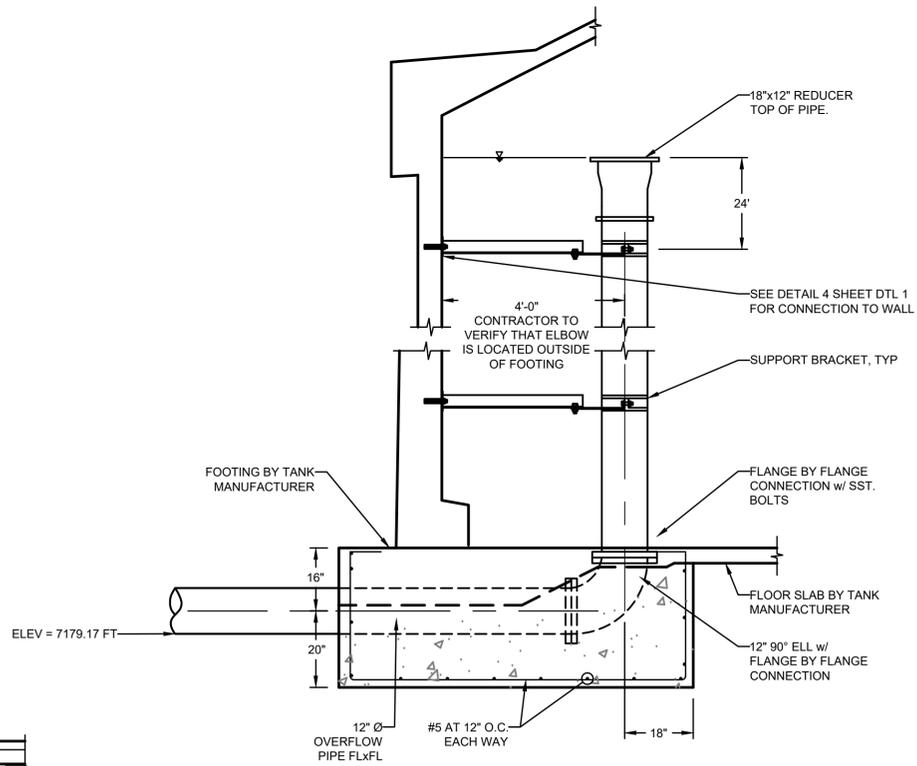

**TANK OVERFLOW PIPE**  
SCALE: 1/2" = 1'-0"

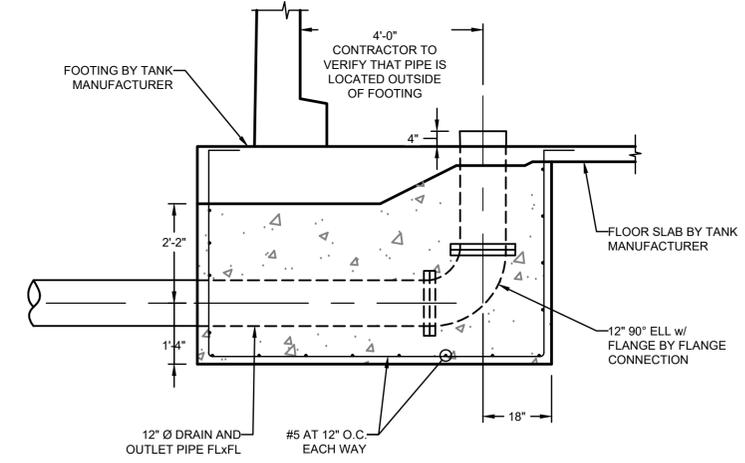

**TANK OUTLET PIPE**  
SCALE: 1/2" = 1'-0"

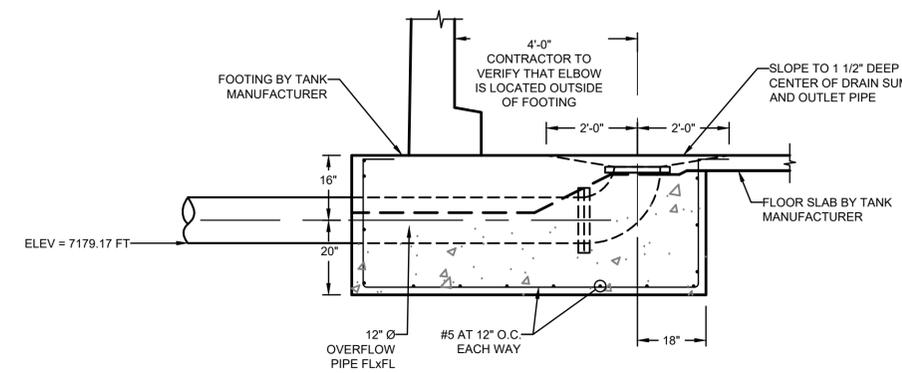

**TANK DRAIN PIPE**  
SCALE: 1/2" = 1'-0"

G:\Projects 2004-20-0153 Monument Tank\CAD\Sheets\UPDATED TANK SITE PLAN\_1.dwg - 5/24/2021 11:25 AM

NO.	REVISIONS	BY	DATE

**FORSGREN Associates, Inc.**  
56 INVERNESS DRIVE EAST #112, ENGLEWOOD, CO 80112  
PH: 720.232.6644

**PRELIMINARY DRAWING NOT FOR CONSTRUCTION**

PROJECT NO.	DRAWN	DESIGNED	APPROVED	DATE
04-20-0153	DLE	DLE	CLR	



**2.0M GALLON TANK**  
**TANK PROFILE**

SHEET NO: **TS 102**  
DATE: FEBRUARY 2021  
PAGE NO: OF

**90% SUBMITTAL**