

## LILLYWOOD SHOW STABLES RIDING ACADEMY


A PORTION OF THE SOUTHWEST QUARTER OF SECTION 15, TOWNSHIP 11 SOUTH, RANGE 65 WEST OF THE 6TH P.M., EL PASO COUNTY, COLORADO EL PASO COUNTY, COLORADO

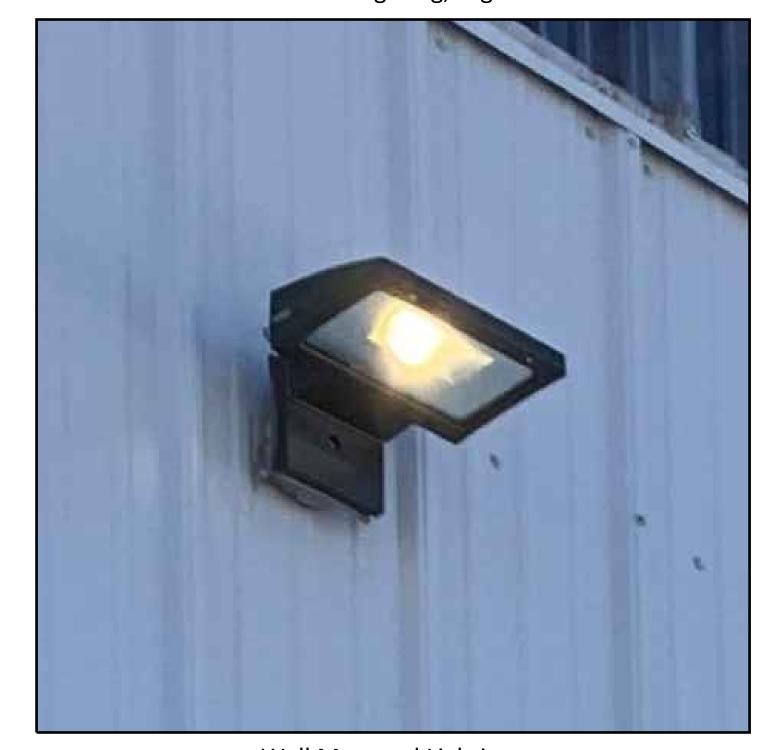

Wall Mounted Lighting, Night Exhibit

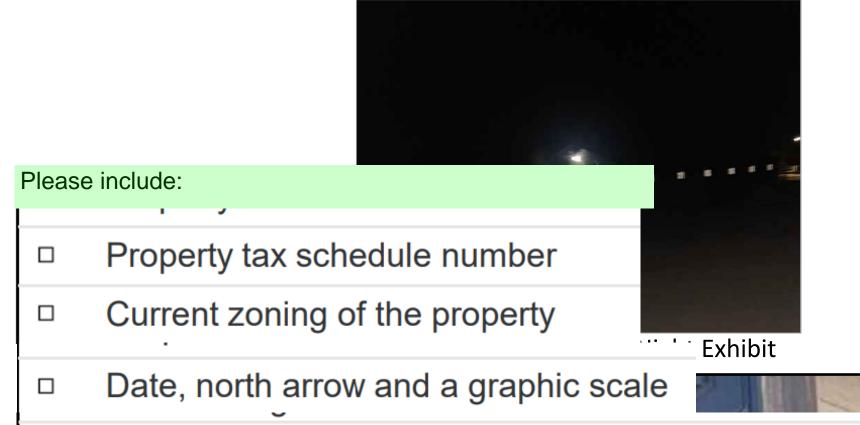



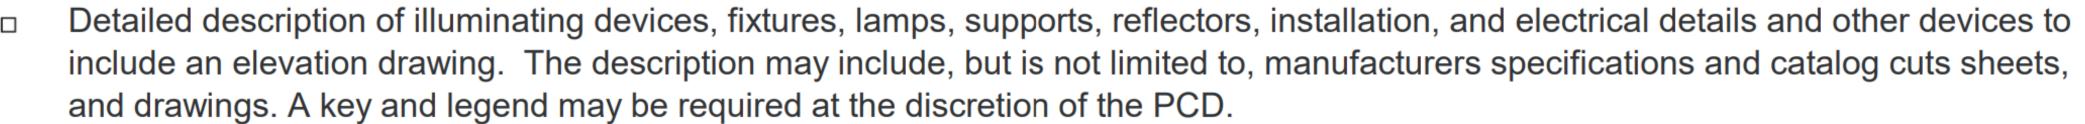

Photometric data and plan, including maps and diagrams furnished by manufacturers or similar showing the angle of the cut off or light emission.

Photometric plan depicting the lighting levels (foot candles) throughout the property, at property lines, and along any adjacent rights-ofway.

SCALE: 1" = 50'





emanates beyond the property boundary.



LILLYWOOD SHOW STABLES RIDING **ACADEMY** SITE DEVELOPMENT PLAN 9210 MORGAN RD COLORADO SPRINGS CO, 80908 3/14/24 E. TROLLER PROJECT MGR: A. ROMAN LIGHTING PLAN

N.E.S. Inc. 619 N. Cascade Avenue, Suite 200

Colorado Springs, CO 80903

Tel. 719.471.0073

Fax 719.471.0267

www.nescolorado.com

© 2012. All Rights Reserved.

Wall Mounted Lighting 0 0 0 0 0 0 0 RIDING SCHOOL STABLES STABLES Note: All lights can be considered low impact and downward facing. No light