
LILLYWOOD SHOW STABLES RIDING ACADEMY

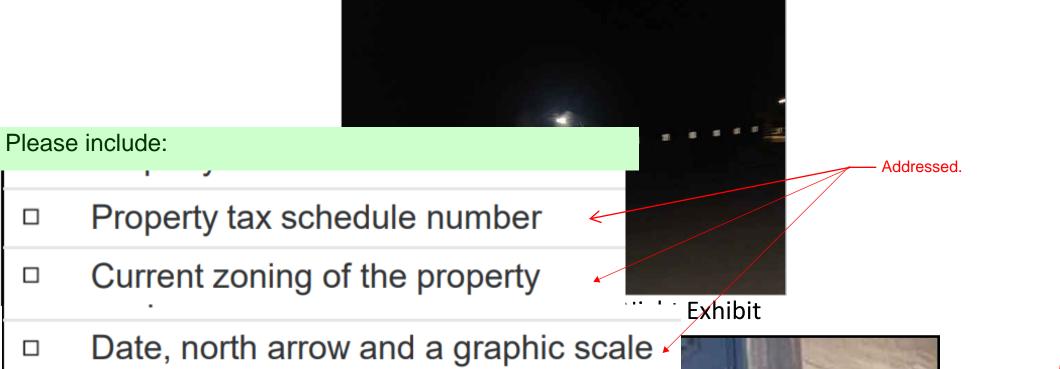

Wall Mounted Lighting, Night Exhibit




Wall Mounted Lighting



- Detailed description of illuminating devices, fixtures, lamps, supports, reflectors, installation, and electrical details and other devices to include an elevation drawing. The description may include, but is not limited to, manufacturers specifications and catalog cuts sheets, and drawings. A key and legend may be required at the discretion of the PCD.
- Photometric data and plan, including maps and diagrams furnished by manufacturers or similar showing the angle of the cut off or light emission.

Photometric plan depicting the lighting levels (foot candles) throughout the property, at property lines, and along any adjacent rights-ofway.

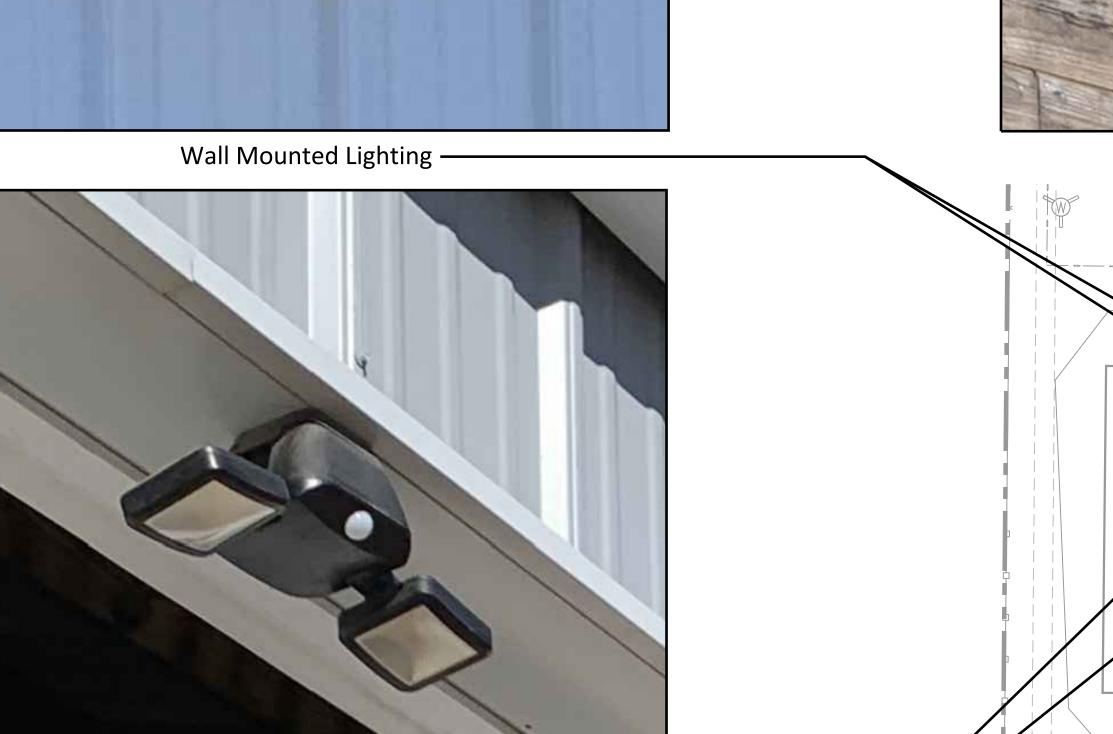


0 0 0 0 0 0 0 RIDING SCHOOL STABLES STABLES Note: All lights can be considered low impact and downward facing. No light emanates beyond the property boundary. SCALE: 1" = 50'

Wall Mounted Lighting



- Light Pole

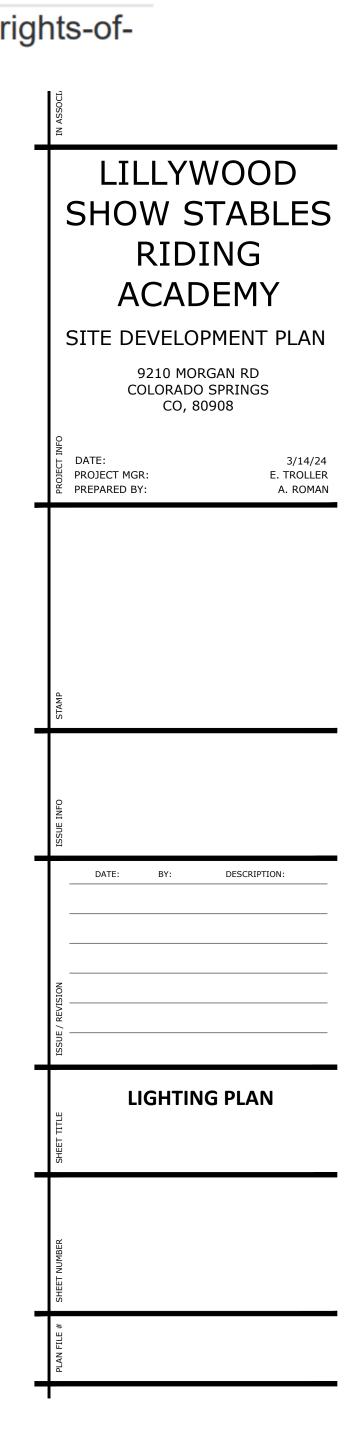

N.E.S. Inc. 619 N. Cascade Avenue, Suite 200

Colorado Springs, CO 80903

Tel. 719.471.0073

Fax 719.471.0267

www.nescolorado.com

© 2012. All Rights Reserved.

A PORTION OF THE SOUTHWEST QUARTER OF SECTION 15, TOWNSHIP 11 SOUTH, RANGE 65 WEST OF THE 6TH P.M., EL PASO COUNTY, COLORADO EL PASO COUNTY, COLORADO

